
1 ROUTE CONDENSATE TO NEAREST SINK DRAIN AIR GAP FITTING. SEE 3/M5.04

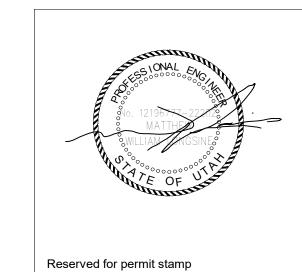

159 South Jackson St, Suite 600
Seattle, Washington 98104 USA
+1 206 624 5670 olsonkundig.com

ASPEN GROUP

Aspen Group USA, LLC
PO Box 980022
Park City, Utah 84098

Pool Consultant
Cloward H20
2696 N University Ave, Suite 290
Provo, UT 84604

Landscape Architect

EPG Design
6949 South High Tech Drive, Suite 100
Midvale, Utah 84047

Specifications Writer
Eriday Group

Specifications Writer
Friday Group
88 Mainelli Road
Middlebury, VT

Code Consultant
Holmes
600 1st Avenue, Suite 200A
Seattle, WA 98104

Seattle, WA 98104

Fire Protection Engineer

Jensen Hughes

One Research Drive, Suite 305C

Westborough, MA 01581

Vertical Transportation Consulatant
Lerch Bates
19515 North Creek Parkway, Suite 304
Bothell, WA 98011

Structural Engineer
Magnusson Klemencic Associates
1301 5th Ave, Suite 3200
Seattle, WA 98101

Lighting Designer
O1319 SE MLK Blvd, Suite 210
Portland, Oregon 97219

Building Envelope Consultant
RDH
2101 N 34th St
Seattle, WA 98103

Accessibility Consultant
Studio Pacifica
2144 Westlake Ave N, Suite F
Seattle, WA 98109

MEP Engineer
WSP USA
1001 Fourth Ave., Suite 3100
Seattle, WA 98154

project manager_____

drawn by_____

checked by <u>Checker</u>

job no.

principal architect_____

job no.


date 5/17/2
revisions:

no. date

IFC Set 2 of 3 5/17/2024

TOWER B - LVL B
MECHANICAL PIPING
PLAN

M3.2B.01

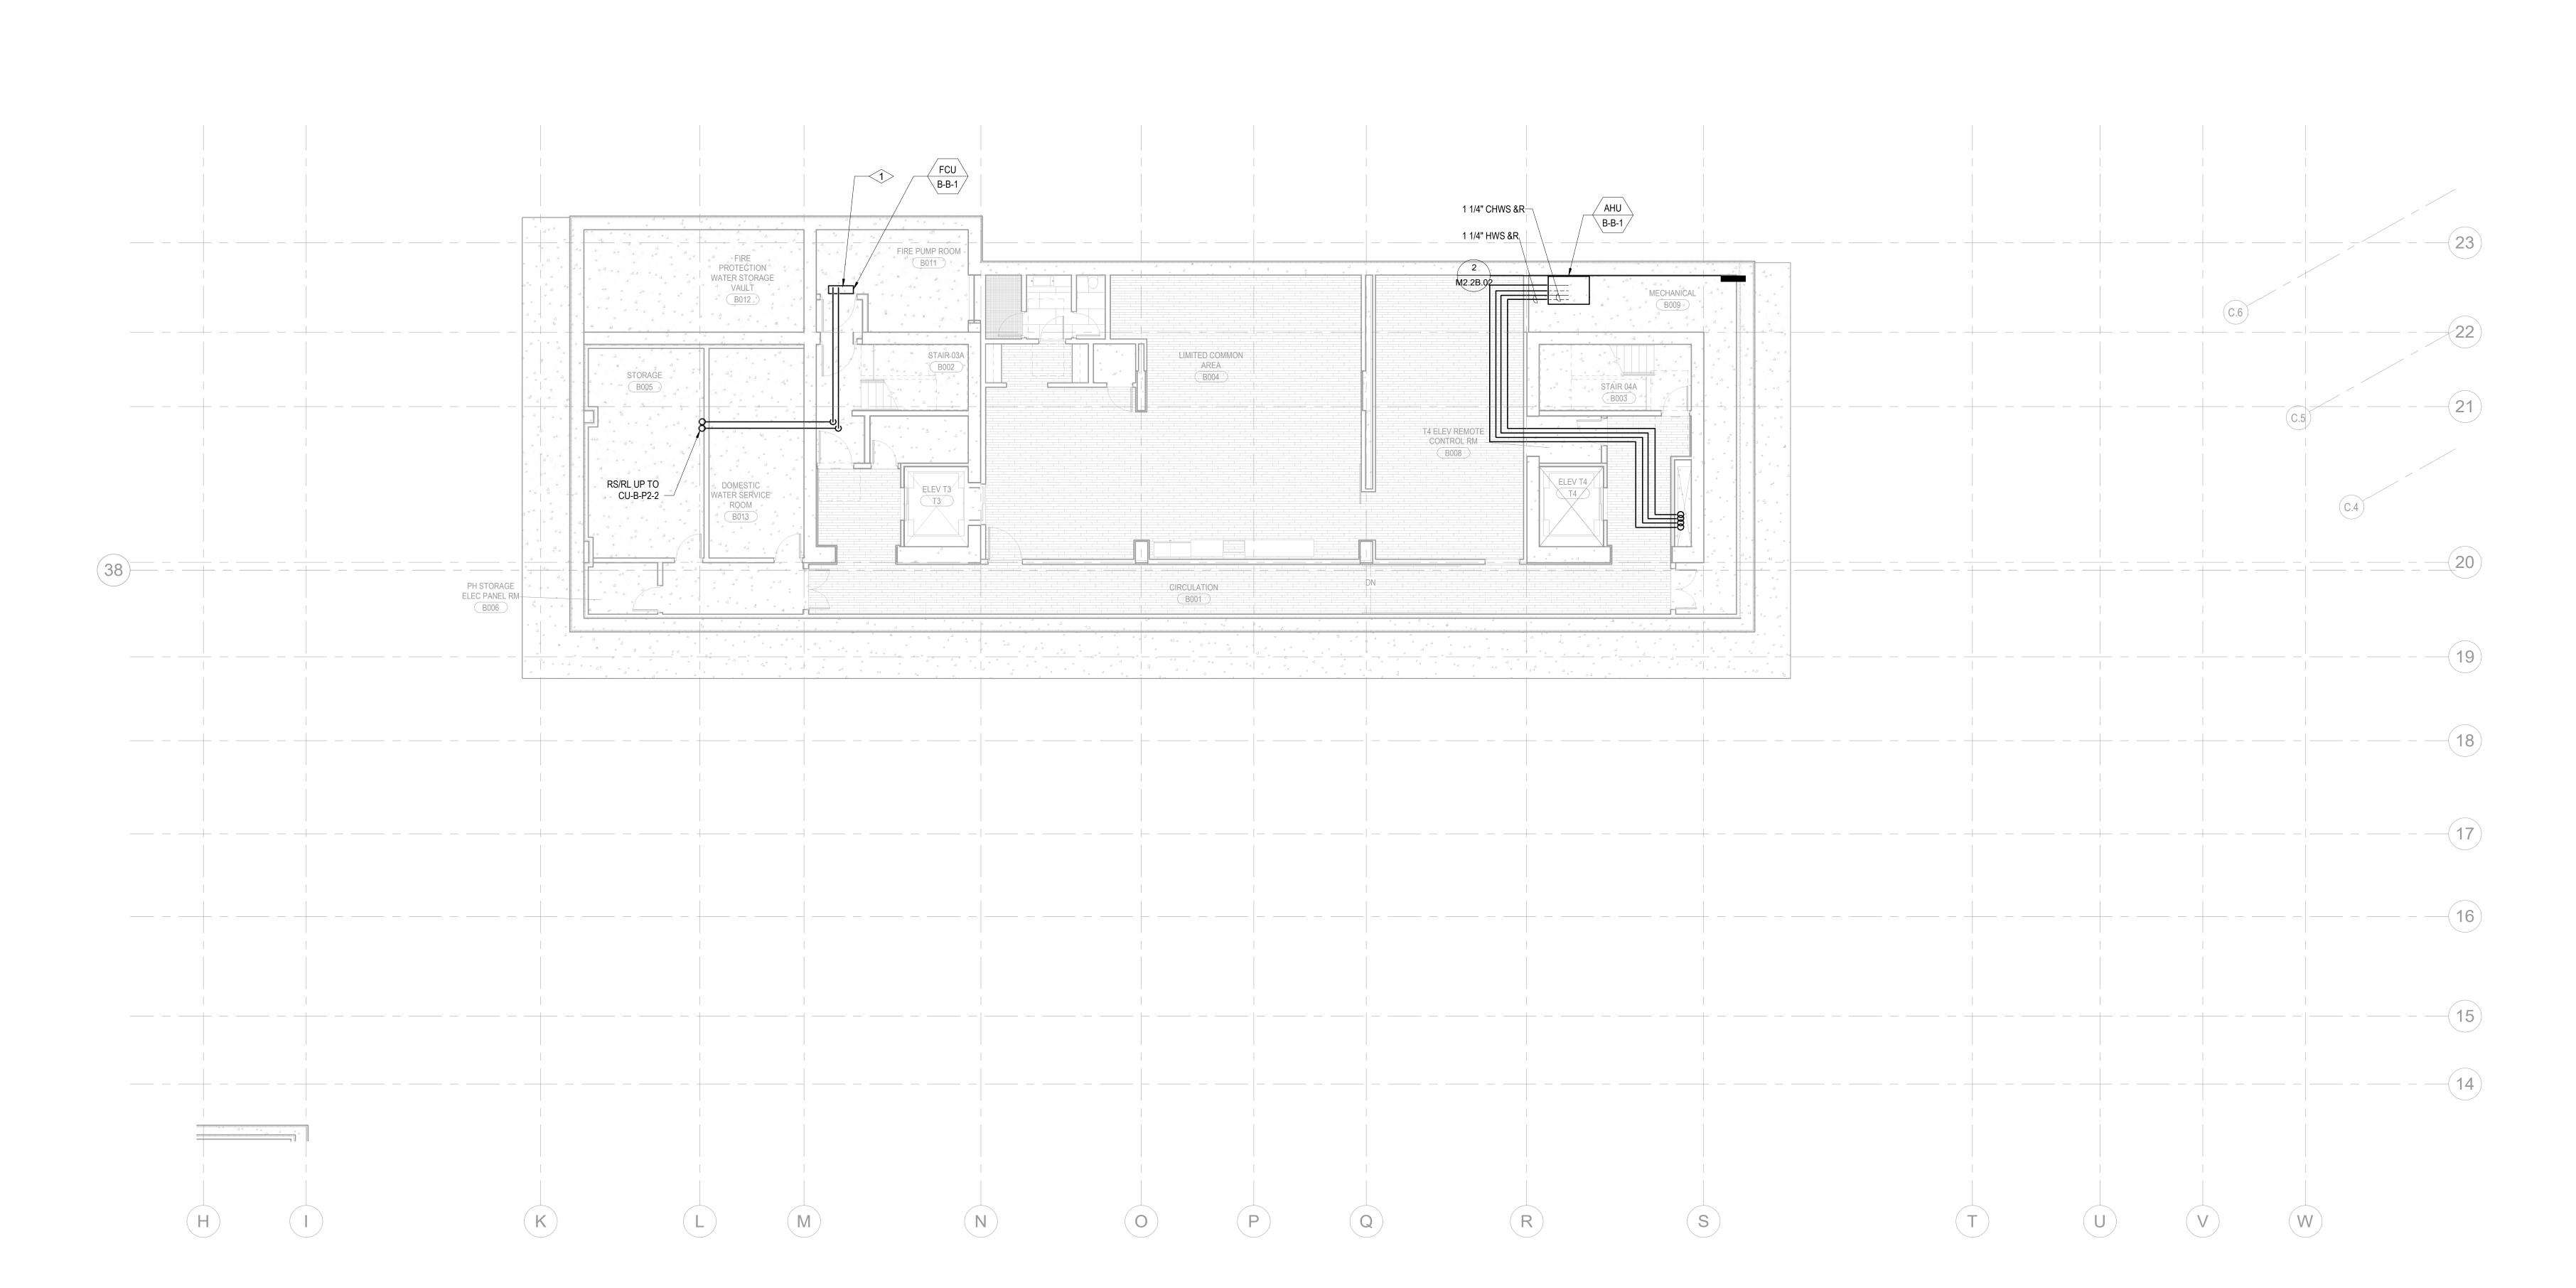

1 TOWER B - LEVEL B1 MECHANICAL PIPING PLAN

SCALE: 1/8" = 1'-0"

