


 
- OWNER OPTION: PROVIDE 1/2" CW TO DUCT HUMIDIFIERS. SEE MECHANICAL PLANS FOR LOCATIONS. CONFIRM WITH OWNER PRIOR TO PROVIDING.
- 2 ROUTE 1/2" DRAIN TUBING FROM WINE COOLER UNIT EVAPORATOR TO ADJACENT SINK TAILPIECE.

 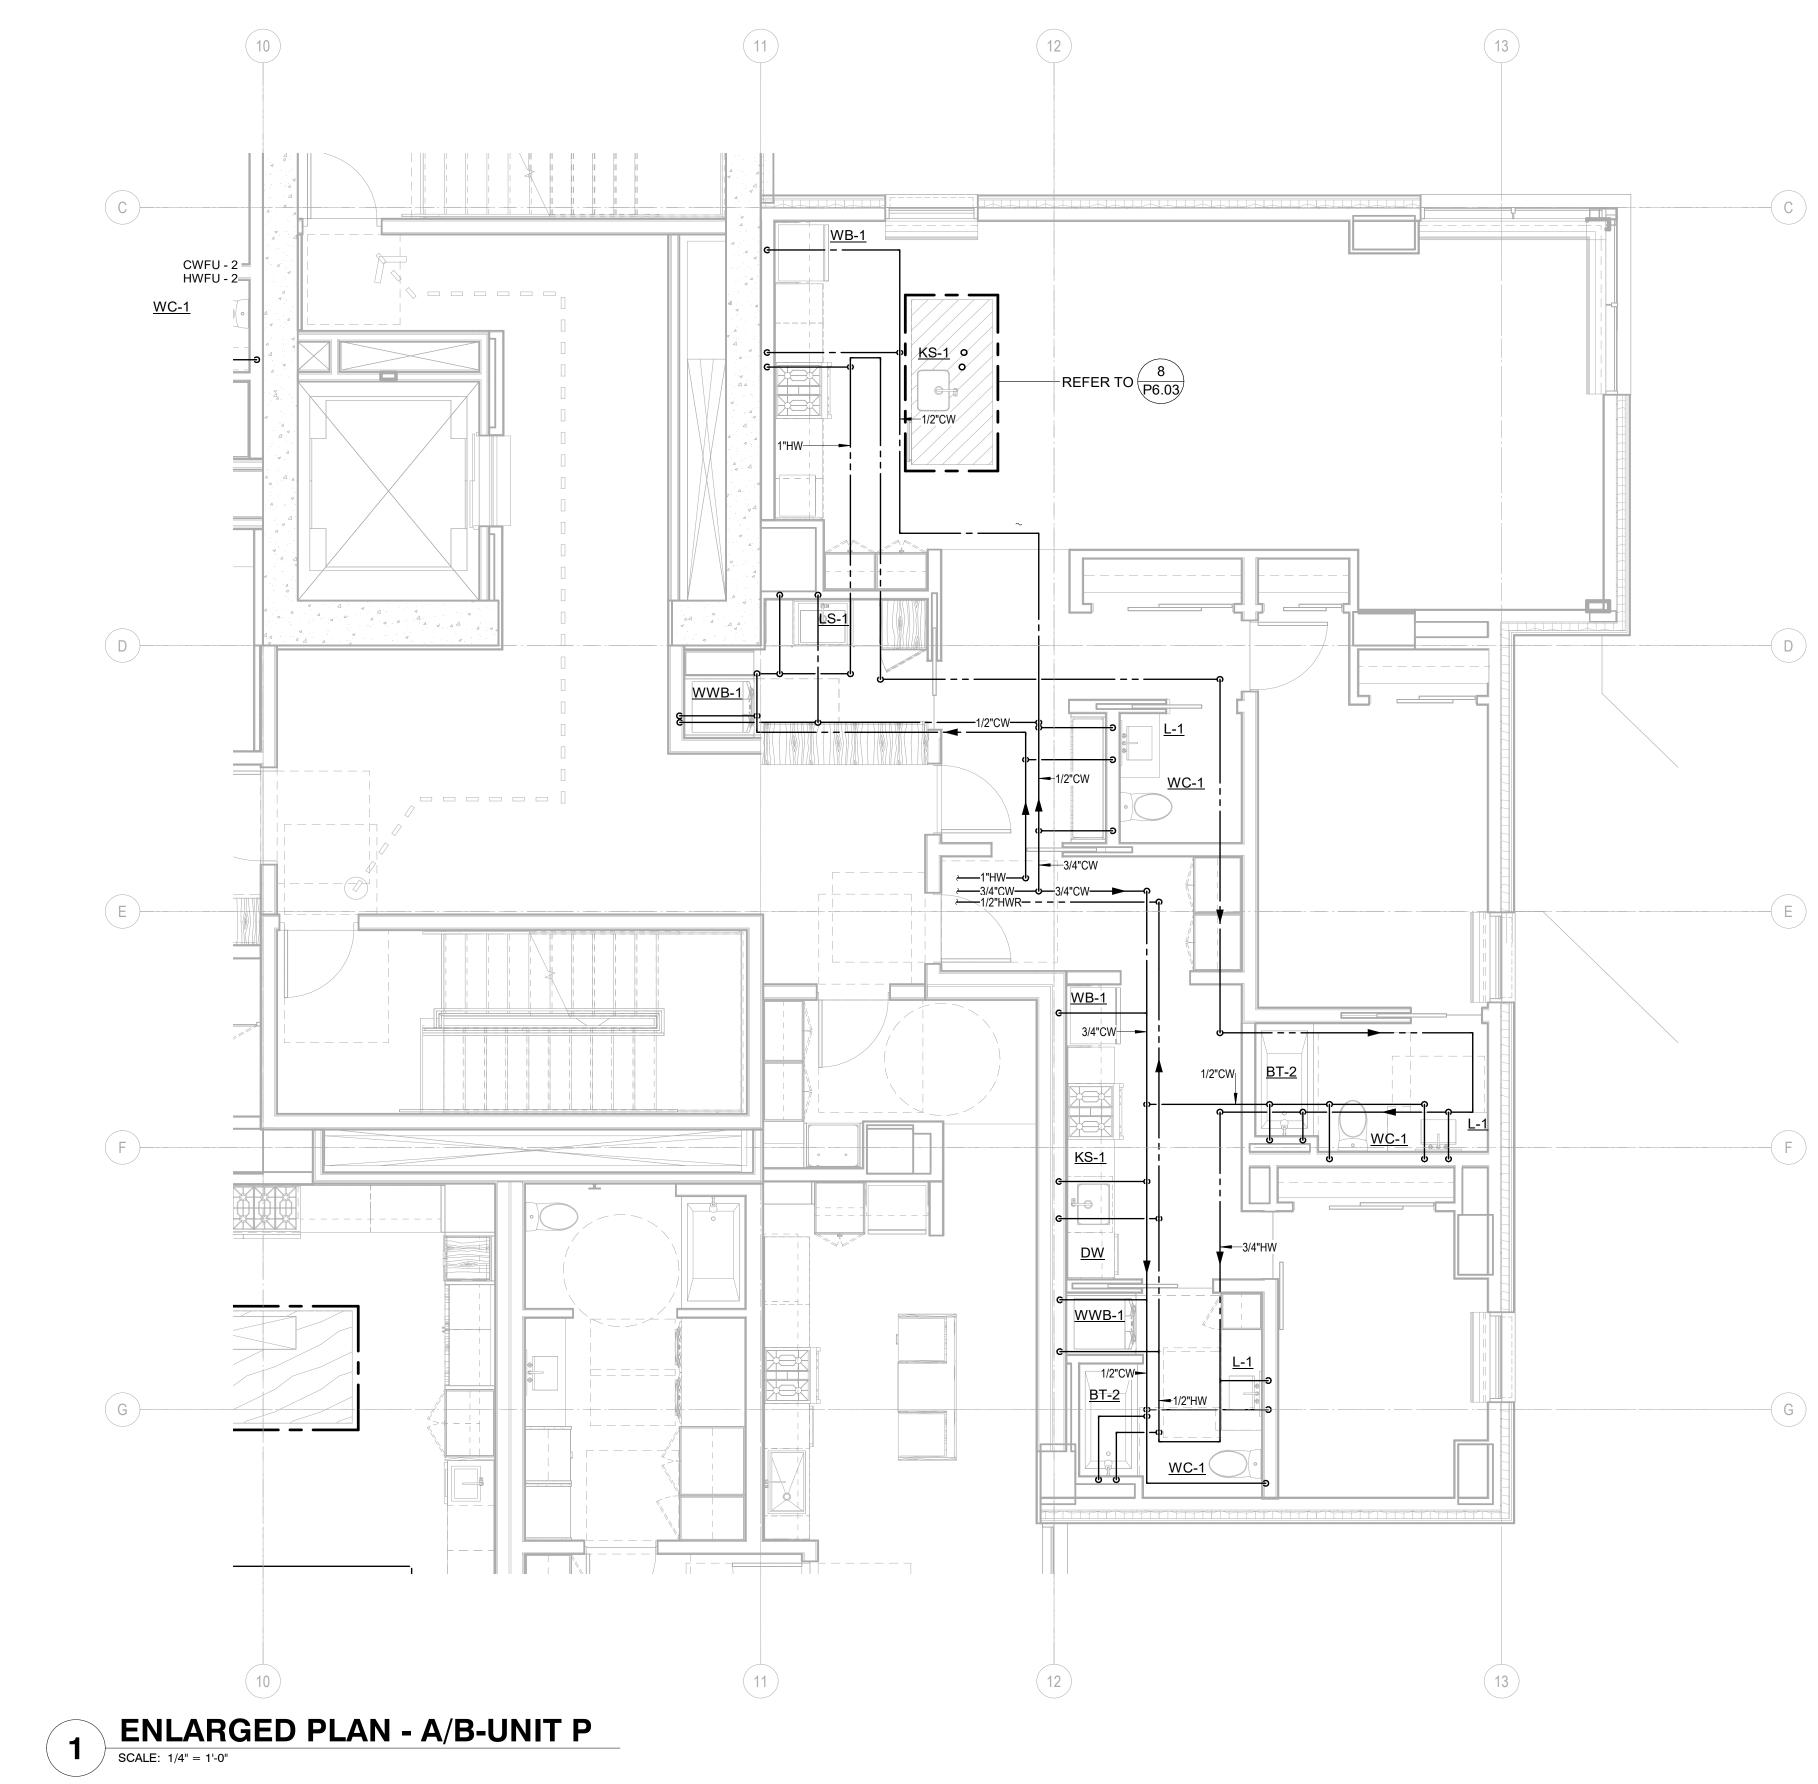


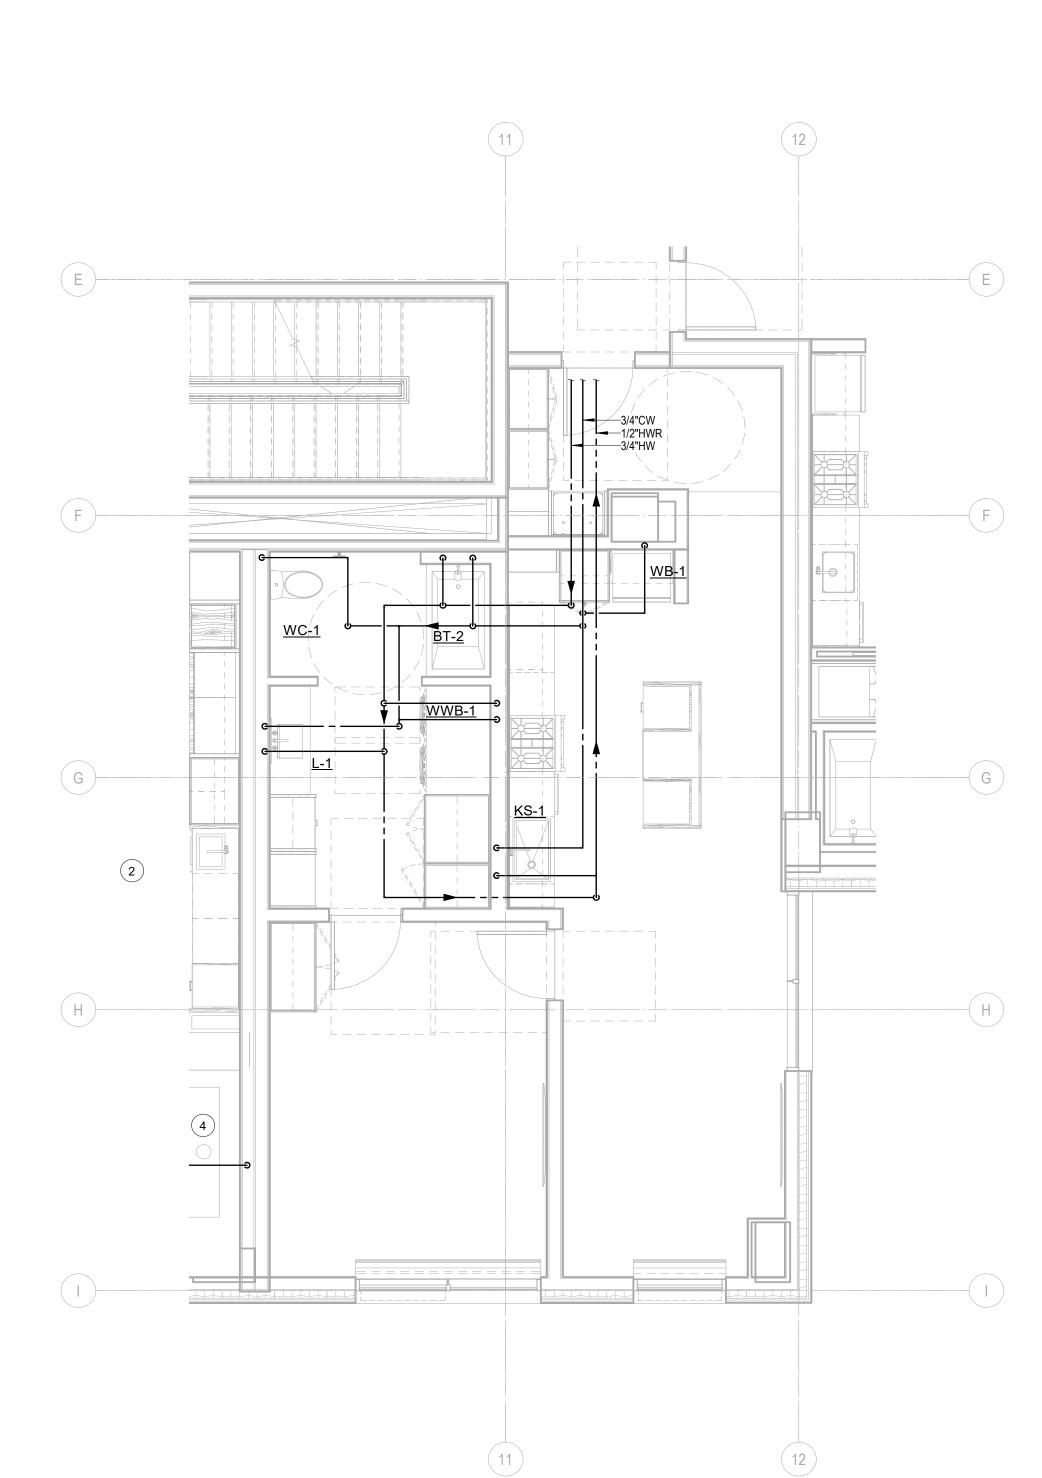


2 ENLARGED PLAN - A/B-UNIT Q
SCALE: 1/4" = 1'-0"

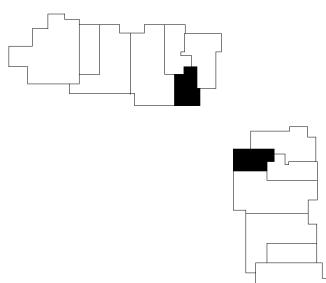





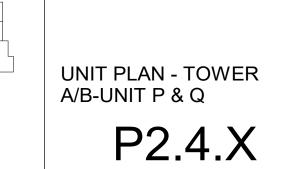



Structural Engineer
Magnusson Klemencic Associates
1301 5th Ave, Suite 3200
Seattle, WA 98101

Lighting Designer
O1319 SE MLK Blvd, Suite 210
Portland, Oregon 97219

Building Envelope Consultant
RDH
2101 N 34th St
Seattle, WA 98103

Accessibility Consultant
Studio Pacifica
2144 Westlake Ave N, Suite F
Seattle, WA 98109

ASPEN GROUP

Aspen Group USA, LLC PO Box 980022 Park City, Utah 84098

Pool Consultant
Cloward H20
2696 N University Ave, Suite 290
Provo, UT 84604

<u>Landscape Architect</u> **EPG Design**6949 South High Tech Drive, Suite 100
Midvale, Utah 84047

Specifications Writer Friday Group 88 Mainelli Road Middlebury, VT

Code Consultant
Holmes
600 1st Avenue, Suite 200A
Seattle, WA 98104

<u>Fire Protection Engineer</u> **Jensen Hughes**One Research Drive, Suite 305C

Westborough, MA 01581

Vertical Transportation Consulatant Lerch Bates 19515 North Creek Parkway, Suite 304 Bothell, WA 98011

Reserved for permit stamp

MEP Engineer
WSP USA
1001 Fourth Ave., Suite 3100
Seattle, WA 98154

principal architect

revisions:

1 10/05/2022 PERMIT RESUBMITTAL
no. date by

IFC Set 2 of 3 5/17/2024