

PIPE MATERIAL

1. SANITARY SEWER, VENT AND STORM DRAIN PIPING ABOVE GROUND	NH-CB CAST IRON PIPE & FITTINGS WITH STAINLESS STEEL NH-CB COUPLER, WRAP ALU LINED COUPLER & 5' SPLICER
2. SANITARY SEWER, VENT & STORM DRAIN PIPING ABOVE GROUND	SERVICE WEIGHT NH-CB CAST IRON PIPE & FITTINGS CONFORMING TO THE REQUIREMENTS OF: CSD STANDARD 301, ASTM A889 OR ASTM A824 WITH TYPE 304 STAINLESS STEEL STANDARD DUTY NH-CB COUPLINGS.
3. DOMESTIC WATER BELOW GROUND	TYPE 'C' COPPER WITH BRAZED JOINTS.
4. DOMESTIC WATER ABOVE GROUND: OUTSIDE BUILDING	TYPE 'C' COPPER TUBING WITH SOLDERED JOINTS. DOMESTIC WATER PIPING SHALL UTILIZE LEAD-FREE WATER AND SOLDER.
5. DOMESTIC WATER ABOVE GROUND: INSIDE OF TYPICAL UNITS	FCX TUBING
6. CONDENSATE AND INDIRECT DRAIN PIPING:	TYPE 'M' COPPER PIPE & FITTINGS WITH SOLDERED JOINTS.
7. NATURAL GAS PIPING ABOVE GROUND	CONDENSATE DRAIN PIPING ABOVE CEILING SHALL BE INSULATED WITH UP-MANUFACTURED CLOSED-CELL, GAS-IMPERMEABLE, PLAIN RATED FOAM INSULATION, PLANE-SPEED INDEX OF 25 OR LESS & A SMOKE-DEVELOPED INDEX OF 50 OR LESS. 1" THICK FOR PIPING UP TO 1" AND 1" THICK FOR PIPING 1 1/4" AND LARGER.
8. NATURAL GAS PIPING BELOW GROUND	SCHEDULE 40 BLACK STEEL PIPE WITH IRON SCREWED FITTING.
9. INSULATION OF HOT WATER SUPPLY & RETURN PIPING	APPROVED POLYETHYLENE (PE) PIPE WITH FUSION JOINTS. SPIRAL WRAP ALU UNDERGROUND PIPE W/ALUM & ELECTRIC TRACER WIRE.
10. ALL OF THE ABOVE SHALL COMPLY WITH THE SPECIFICATIONS	GLASS FIBER PIPE INSULATION WITH FACTORY APPLIED WHITE JACKET: 1" MIN. MICRO-LOK (MSAP) HOT WATER INSULATION SHALL HAVE A MINIMUM R-VAL. THICK 2.5 IN. FOR PIPES WITH 1/2" TO 1" IN P.I.D. 1/2 IN. FOR 1" TO 1 1/8" IN. P.I.D. AND NOT LESS THAN 2 IN. FOR PIPE 2" O.D. AND LARGER.

LEAD-FREE NOTE:

 
ALL PIPE, FITTINGS, FIXTURES, ETC. THAT CONTACT POTABLE WATER FOR HUMAN CONSUMPTION SHALL SHOW APPROVAL TO NSF 61, ANNEX C10, EFFECTIVE JANUARY 1, 2010. THE LEAD CONTENT OF THE WETTED SURFACE AREA OF THE PIPE, FITTINGS AND FIXTURES CONSTITUTES POTENTIALLY LEADY MATERIAL CONSUMPTION, OF NOT MORE THAN 0.01% LEAD BY DRY WEIGHT. A PRESCRIBED FORMULA AS DETERMINED BY THIRD PARTY CERTIFIERS TO NSF STANDARD 61, PART 301, FOR SOLID AND FLEX, THE LEAD CONTENT SHALL BE NOT MORE THAN 1.0% LEAD BY WEIGHT WHEN USED IN PIPING SYSTEMS THAT CONVEY OR DISPERSE WATER FOR HUMAN CONSUMPTION.

PLUMBING GENERAL NOTES

1. SEE ARCHITECTURAL DRAWINGS FOR EXACT LOCATION OF ALL PLUMBING FUTURES, DRAINS AND EQUIPMENT.
2. COORDINATE ALL LOCATIONS, SIZES AND ELEVATIONS OF ALL SLEEVES THROUGH BEAMS, SLABS AND FOOTINGS WITH STRUCTURAL AND ELECTRICAL DRAWINGS.
3. ALL 1/2" OR SMALLER HORIZONTAL WASTE LINES SHALL BE RUN AT A MINIMUM SLOPE OF 1/4" PER FOOT. ALL 1/2" TO 1" HORIZONTAL WASTE LINES SHALL BE RUN AT A MINIMUM SLOPE OF 1/8" PER FOOT. ALL 1" OR LARGER HORIZONTAL WASTE LINES SHALL BE RUN AT A MINIMUM SLOPE OF 1/4" PER FOOT.
4. ALL HORIZONTAL STORM DRAINS AND OVERFLOW DRAIN LINES SHALL BE RUN AT A SLOPE OF 1/8" PER FOOT UNLESS OTHERWISE NOTED ON PLAN.
5. COORDINATE AND VERIFY EXACT LOCATION, SIZE, POINTS OF CONNECTION AND INVERT ELEVATIONS OF UTILITY SERVICE PIPING BEFORE TRECHING OR INSTALLATION.
6. COORDINATE WITH ARCHITECTURAL DRAWINGS FOR WALL AND PARTITION CONSTRUCTION AND THICKNESS WHERE PLUMBING PIPING OR EQUIPMENT IS INDICATED.
7. THE LOCATION AND ELEVATION OF ALL PLUMBING PIPES SHALL BE VERIFIED AND COORDINATED WITH ALL OTHER TRADES, STRUCTURAL, CONDITIONS AND BUILDING CONSTRUCTION PRIOR TO START OF INSTALLATION.
8. ALL VALVES AND COCKS SHALL BE LOCATED TO BE EASILY ACCESSIBLE, WHERE VALVES ARE INSTALLED WITHIN OR BEHIND WALLS, PARTITIONS OR CEILINGS, IN ACCESS PANELS SHALL BE INSTALLED.
9. ALL OUTLETS FOR FUTURE CONNECTIONS SHALL BE INSTALLED SO AS TO PERMIT EASY CONNECTION - COORDINATE WITH DWG WORK, STRUCTURAL CONDITIONS AND ARCHITECTURAL LAYOUT.
10. ALL PLUGGED OR CAPPED WASTE OUTLETS FOR FUTURE CONNECTIONS SHALL BE INSTALLED ABOVE CEILING WITH PIPE INVERT + 4" ABOVE THE FINE CEILING.
11. ALL PLUGGED OR CAPPED VENT OUTLETS FOR FUTURE CONNECTIONS SHALL BE INSTALLED ABOVE CEILING WITH PIPE INVERT 12" FROM BOTTOM OF SLAB.
12. SEE RISER DIAGRAMS FOR ALL PIPE SIZING FOR ALL PLUMBING SYSTEMS.
13. FIRE PROTECTION PIPING AND EQUIPMENT SHOWN IS FOR REFERENCE ONLY. FOR FIRE PROTECTION PIPING SEE FIRE SPRINKLER SHOP DRAWINGS. FIRE SPRINKLER DETAILING CONTRACTOR SHALL COORDINATE THE WORK WITH SHOP DRAWING PAPER, WITH ROOF DRAINS AND LINES AS SHOWN AND SHALL MAKE PROVISIONS FOR FUTURE DOWNDRAIN AND PASSED CEILING.
14. FIRE RISERS SHOULD BE FIRE-RESISTANT APPROVAL.
15. ALL UNMOUNTED ACCESS PANELS AND WALL CLEANSOUTS SHALL BE MOUNTED AS LOW AS POSSIBLE UNLESS NOTED OTHERWISE OR AS INDICATED IN ARCHITECTURAL PLANS OR AS REQUIRED. CONTRACTOR SHALL GET ARCHITECT AND ENGINEER APPROVAL FOR ALL LOCATIONS PRIOR TO THE START OF WORK OF WALL, FLOOR OR ROOF.
16. THESE DRAWINGS ARE DIAGNOSTIC. THE LOCATION & ELEVATION OF ALL PLUMBING PIPES IS APPROXIMATE AND SHALL BE VERIFIED AND COORDINATED WITH ALL OTHER TRADES, STRUCTURAL CONDITIONS AND BUILDING CONSTRUCTION PRIOR TO START OF INSTALLATION.
17. PENETRATIONS OF PIPES, ETC. IN WALLS REQUIRING PROTECTED OPENINGS SHALL BE FIRE STOPPED. FIRE STOP MATERIAL SHALL BE A TESTED ASSEMBLY APPROVED BY THE STATE FIRE MARSHAL.
18. ALL HOT AND COLD WATER PIPE SHALL BE INSULATED INCLUDING PIPING IN THE WALLS.
19. ALL REQUIRED CLEANOUTS SHALL BE INSTALLED AS PER SECTION 707.0 OF THE PLUMBING CODE.
20. ROOF DRAIN AND OVERFLOW PIPING WITHIN THE BUILDINGS WALLS TYPE APPROVED DRAIN FITTINGS.
21. CLEANOUTS FOR BUILDING STORM DRAINS SHALL COMPLY WITH THE REQUIREMENTS OF SECTION 719.0 OF THE PLUMBING CODE.
22. NEW BUILDING STORM DRAINAGE SYSTEM AND PARTS OF EXISTING SYSTEMS THAT HAVE BEEN ALTERED, EXTENDED OR REPAIRED SHALL BE TESTED AS DESCRIBED IN SECTION 1109.0 OF THE PLUMBING CODE.
23. DIELECTRIC UNITS SHALL BE USED AT ALL POINTS OF CONNECTION WHERE THERE IS A DISSIMILARITY OF MATERIALS.
24. ALL VENTS THROUGH ROOF SHALL MAINTAIN A MINIMUM OF 2 FT. CLEARANCE AND 3 FEET ABOVE ANY WINDY, DOOR, OPENING, AIR INTAKE OR VENT SHAFT.

LEGEND		
LEGEND	ABBR.	DESCRIPTION
	S OR W	SOIL OR WASTE ABOVE FLOOR OR GRADE
	S OR W	SOIL OR WASTE BELOW FLOOR OR GRADE
	SD	STORM DRAIN ABOVE FLOOR OR GRADE
	SD	STORM DRAIN BELOW FLOOR OR GRADE
	OD	OVERFLOW DRAIN ABOVE FLOOR OR GRADE
	SPD	SUMP PUMP DISCHARGE
	SED	SEWAGE EJECTOR DISCHARGE
	SEV	SEWAGE EJECTOR VENT
	V	SANITARY VENT
	CW	DOMESTIC COLD WATER
	NPW	NON-POTABLE WATER
	HW	DOMESTIC HOT WATER
	HWR	DOMESTIC HOT WATER RETURN
	F	FIRE MAIN
	D	INDIRECT DRAIN
	CD	CONDENSATE DRAIN
	PCD	PUMPED CONDENSATE DRAIN
	MG	MEDIUM PRESSURE FUEL GAS
	G	FUEL GAS
	TP	TRAP PRIMER
		DIRECTION OF FLOW
	P.G.	PRESSURE GAUGE WIPETE COCK
	G.C.	GAS COCK
	P.R.V.	PRESSURE REDUCING VALVE
	C.V.	CHECK VALVE
	L.B.V.	LOCKING BALL VALVE
	B.V.	BALL VALVE
	G.V.	GATE VALVE
	FCO	FLOOR CLEANOUT
	WCO	WALL CLEANOUT
		DOWN
		RISE
		UNION
		SLOPE IN DIRECTION OF FLOW
	WHA	WATER HAMMER ARRESTOR
	P.O.C.	POINT OF CONNECTION
	RBPB	REDUCED PRESSURE BACKFLOW PREVENTER
	ABV	ABOVE
	AFF	ABOVE FINISHED FLOOR
	AP	ACCESS PANEL
	BEH	BEHIND
	BEL	BELOW

PLUMBING SHEET INDEX	
P.001	PLUMBING LEGEND AND ABBREVIATIONS
P.002	PLUMBING SPECIFICATIONS
P.22A.01U	PLAN - TOWER A - LVL. BU
P.22A.01	PLAN - TOWER A - LVL. B
P.22A.02	PLAN - TOWER A - LVL. P2
P.22A.11	PLAN - TOWER A - LVL. 1
P.22A.12	PLAN - TOWER A - LVL. 2
P.22A.13	PLAN - TOWER A - LVL. 3
P.22A.14	PLAN - TOWER A - LVL. 4
P.22A.15	PLAN - TOWER A - LVL. 5
P.22A.16	PLAN - TOWER A - LVL. 6
P.22A.18	PLAN - TOWER A - ROOF
P.22A.111	PLAN - LOBBY
P.22B.01U	PLAN - TOWER B - LVL. BU
P.22B.01	PLAN - TOWER B - LVL. B1
P.22B.02	PLAN - TOWER B - LVL. P2
P.22B.11	PLAN - TOWER B - LVL. 1
P.22B.12	PLAN - TOWER B - LVL. 2
P.22B.13	PLAN - TOWER B - LVL. 3
P.22B.14	PLAN - TOWER B - LVL. 4
P.22B.15	PLAN - TOWER B - LVL. 5
P.22B.16	PLAN - TOWER B - LVL. 6
P.22B.17	PLAN - TOWER B - LVL. 7
P.22B.18	PLAN - TOWER B - ROOF
P.22C.111	PLAN - TOWER C-B CONNECTOR
P.22C.01U	PLAN - TOWER C-B. PIU
P.22C.01	PLAN - TOWER C - LVL. BU
P.22C.11	PLAN - TOWER C - LVL. 1
P.22C.12	PLAN - TOWER C - LVL. 2
P.22C.13	PLAN - TOWER C - LVL. 3
P.22C.14	PLAN - TOWER C - LVL. 4
P.22C.15	PLAN - TOWER C - LVL. 5
P.22C.16	PLAN - TOWER C - LVL. 6
P.22C.17	PLAN - TOWER C - LVL. 7
P.22C.18	PLAN - TOWER C - LVL. 8
P.22C.19	PLAN - TOWER C - ROOF
P.4.A	UNIT PLAN - TOWER AB-UNIT A
P.4.B	UNIT PLAN - TOWER AB-UNIT B
P.4.C	UNIT PLAN - TOWER AB-UNIT C
P.4.D	UNIT PLAN - TOWER AB-UNIT D
P.4.E	UNIT PLAN - TOWER AB-UNIT E
P.4.F	UNIT PLAN - TOWER AB-UNIT F
P.4.G	UNIT PLAN - TOWER AB-UNIT G
P.4.H	UNIT PLAN - TOWER AB-UNIT H
P.4.J	UNIT PLAN - TOWER AB-UNIT J
P.4.K	UNIT PLAN - TOWER AB-UNIT K
P.4.LX	UNIT PLAN - TOWER AB-UNIT P & Q
P.4.L	UNIT PLAN - TOWER C-UNIT L
P.4.M	UNIT PLAN - TOWER C-UNIT M
P.4.N	UNIT PLAN - TOWER C-UNIT N
P.4.O	UNIT PLAN - TOWER C-UNIT O
P.4.P	UNIT PLAN - TOWER C - UNIT R
P.001	PLUMBING ENLARGED PLANS
P.002	PLUMBING ENLARGED PLANS
P.001	DETAILS
P.002	DETAILS
P.003	DETAILS
P.001	DOMESTIC WATER RISER DIAGRAM
P.002	SANITARY RISER DIAGRAM
P.003	STORM RISER DIAGRAM - TOWER AB
P.004	STORM RISER DIAGRAM - TOWER C
P.001	GAS RISER DIAGRAM
P.002	SANITARY RISER DIAGRAM - TOWER C
P.003	SANITARY RISER DIAGRAM - TOWER C
P.004	SANITARY RISER DIAGRAM - TOWER C
P.005	SANITARY RISER DIAGRAM - TOWER C
P.006	SANITARY RISER DIAGRAM - TOWER C
P.007	SANITARY RISER DIAGRAM - TOWER C
P.008	SANITARY RISER DIAGRAM - TOWER C



Olson Kundig



ASPEN GROUP

Pool Consultant
Cloward H2O
2896 N University Ave, Suite 290
Provo, UT 84604

Landscape Architect
EPG Design
6949 South High Tech Drive, Suite 100
Midvale, Utah 84047

Specifications Writer
Friday Group
88 Mainelli Road
Middlebury, VT

Code Consultant
Holmes
600 1st Avenue, Suite 200A
Seattle, WA 98104

Fire Protection Engineer
Jensen Hughes
One Research Drive, Suite 305C
Westborough, MA 01581

Vertical Transportation Consultant
Lerch Bates
19515 North Creek Parkway, Suite 300
Bothell, WA 98011

Structural Engineer
Magnusson Klemencic Associates
1301 5th Ave, Suite 3200
Seattle, WA 98101

Lighting Designer
O-
1319 SE MLK Blvd, Suite 210
Portland, Oregon 97219

Building Envelope Consultant
RDH
2101 N 34th St
Seattle, WA 98103

Accessibility Consultant
Studio Pacifica
2144 Westlake Ave N, Suite F
Seattle, WA 98109

MEP Engineer
WSP USA
1001 Fourth Ave., Suite 3100
Seattle, WA 98154

principal architect _____
project manager _____
drawn by _____
checked by GM
job no. 2021-0595
date 5/31/2024

revisions:


B	5/31/2024	IFC 3
1	10/05/2022	PERMIT RESUBMITTAL

no.	date	b
-----	------	---

IFC Set 3 of 3
5/31/2024

PLUMBING LEGEND & ABBREVIATIONS

 
P0.01



159 South Jackson St., Suite 600
Seattle, Washington 98104 USA
+1 206 624 5870 olsonkundig.com

Olson Kundig

Sommet Blanc - Bldg AB
DEER VALLEY, UTAH

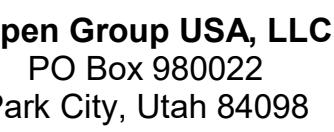

Edward H2O
16 N University Ave, Suite 290
Provo, UT 84604

3 Design
9 South High Tech Drive, Suite 100
Pleasantville, Utah 84047

Play Group
Mainelli Road
Middlebury, VT

Lead Consultant
James
1st Avenue, Suite 200A
Seattle, WA 98104

Protection Engineer
sen Hughes
Research Drive, Suite 305
Storborough, MA 01581

Michael Bates
15 North Creek Parkway, Suite 304
Seattle, WA 98011

Structural Engineer
Knudson Klemencic Associates
115th Ave, Suite 3200
Seattle, WA 98101

9 SE MLK Blvd, Suite 210
Portland, Oregon 97219

1 N 34th St
Seattle, WA 98103

Feasibility Consultant
Radio Pacifica
4 Westlake Ave N, Suite 1
Seattle, WA 98109

P Engineer
P USA
1 Fourth Ave., Suite 3100
Seattle, WA 98154

principal architect _____
project manager _____
drawn by _____
checked by GM
job no. 2021-0595
date 5/31/2024

ns:


26/2024	ASI 2
31/2024	IFC 3
05/2022	PERMIT RESUBMITTAL

date by

Set 3 of 3
31/2024

AN - TOWER A - I VI B

 2.2A.01



159 South Jackson St, Suite 600
Seattle, Washington 98104 USA
+1 206 624 5670 cl@orkundig.com

Olson Kundig

Project: **Sommet Blanc - Bldg AB**
DEER VALLEY, UTAH



Aspen Group USA, LLC
PO Box 980022
Park City, Utah 84098

Pool Consultant
Cloward H20
2896 N University Ave, Suite 290
Provo, UT 84604

Landscape Architect
EPG Design
6949 South High Tech Drive, Suite 100
Midvale, Utah 84047

Specifications Writer
Friday Group
88 Mainelli Road
Middlebury, VT

Code Consultant
Holmes
600 1st Avenue, Suite 200A
Seattle, WA 98104

Fire Protection Engineer
Jensen Hughes
One Research Drive, Suite 305C
Westborough, MA 01581

Vertical Transportation Consultant
Lerch Bates
19515 North Creek Parkway, Suite 304
Bothell, WA 98011

Structural Engineer
Magnusson Klemencic Associates
1301 5th Ave, Suite 3200
Seattle, WA 98101

Lighting Designer
O-
1319 SE MLK Blvd, Suite 210
Portland, Oregon 97219

Building Envelope Consultant
RDH
2101 N 34th St
Seattle, WA 98103

Accessibility Consultant
Studio Pacifica
2144 Westlake Ave N, Suite F
Seattle, WA 98109

MFP Engineer
WSP USA
1001 Fourth Ave., Suite 3100
Seattle, WA 98154

principal architect _____
project manager _____
drawn by _____
checked by GM
job no. 2021-0696
date 5/31/2024

revisions:


B 5/31/2024 IFC 3

no.	date	by
-----	------	----


IFC Set 3 of 3
5/31/2024

PLAN - TOWER A - LVL
P2

P2.2A.02

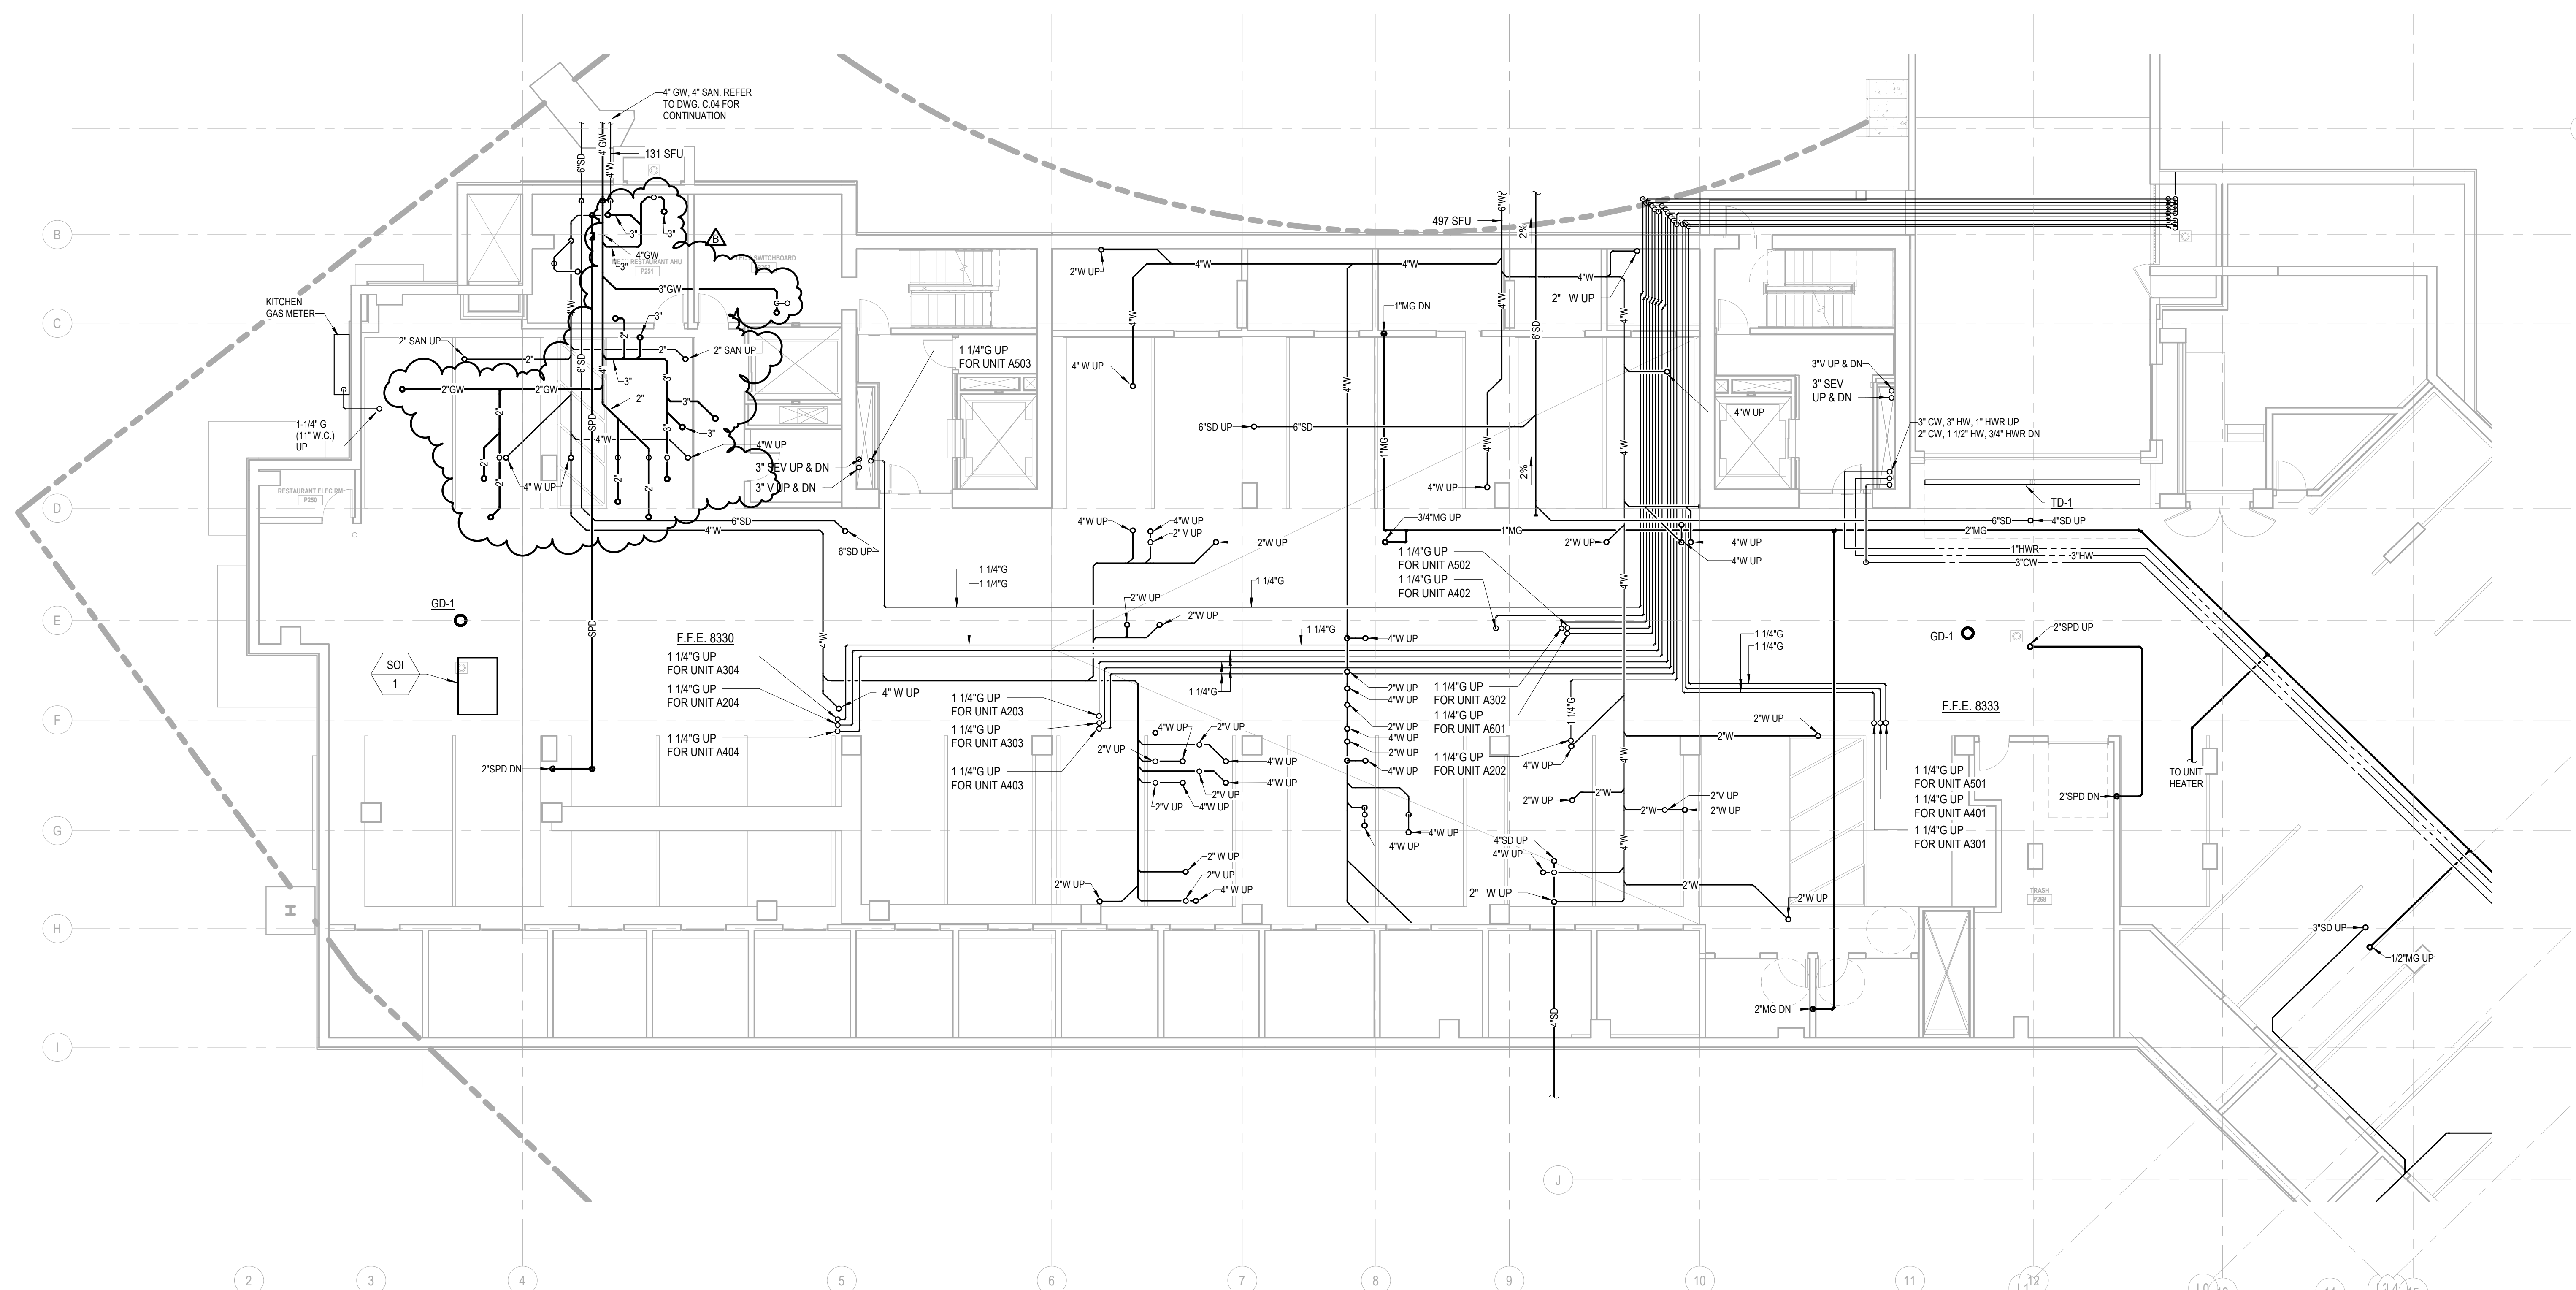

 
1 PLAN - TOWER A - LVL P2
SCALE: 1/8" = 1'-0"



159 South Jackson St, Suite 600
Seattle, Washington 98104 USA
+1 206 624 5670 olsonkundig.com

Olson Kundig

Project: **Sommet Blanc - Bldg AB**
DEER VALLEY, UTAH

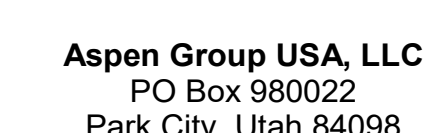

Pool Consultant
Cloward H2O
2896 N University Ave, Suite 290
Brown, UT 84604

Landscape Architect
EPG Design
6949 South High Tech Drive, Suite 100
Midvale, Utah 84047

Specifications Writer
Friday Group
88 Mainelli Road
Middlebury, VT

Code Consultant
Holmes
600 1st Avenue, Suite 200A
Seattle, WA 98104

Fire Protection Engineer
Jensen Hughes
One Research Drive, Suite 305C
Westborough, MA 01581

Vertical Transportation Consultant
Lorch Bates
19515 North Creek Parkway, Suite 304
Bothell, WA 98011

Structural Engineer
Magnusson Klemencic Associates
1301 5th Ave, Suite 3200
Seattle, WA 98101

Lighting Designer
O-
1319 SE MLK Blvd, Suite 210
Portland, Oregon 97219

Building Envelope Consultant
RDH
2101 N 34th St
Seattle, WA 98103

Accessibility Consultant
Studio Pacifica
2144 Westlake Ave N, Suite F
Seattle, WA 98109

MEP Engineer
WSP USA
1001 Fourth Ave., Suite 3100
Seattle, WA 98154

principal architect _____
project manager _____
drawn by _____
checked by BWY _____
job no. 2021-0595
date 5/31/2024

revisions:


1	10/05/2022	PERMIT RESUBMITTAL
no	date	by

no.	date	by
-----	------	----


IFC Set 3 of 3
5/31/2024

PLAN - TOWER A - LVL 1

P2.2A.11

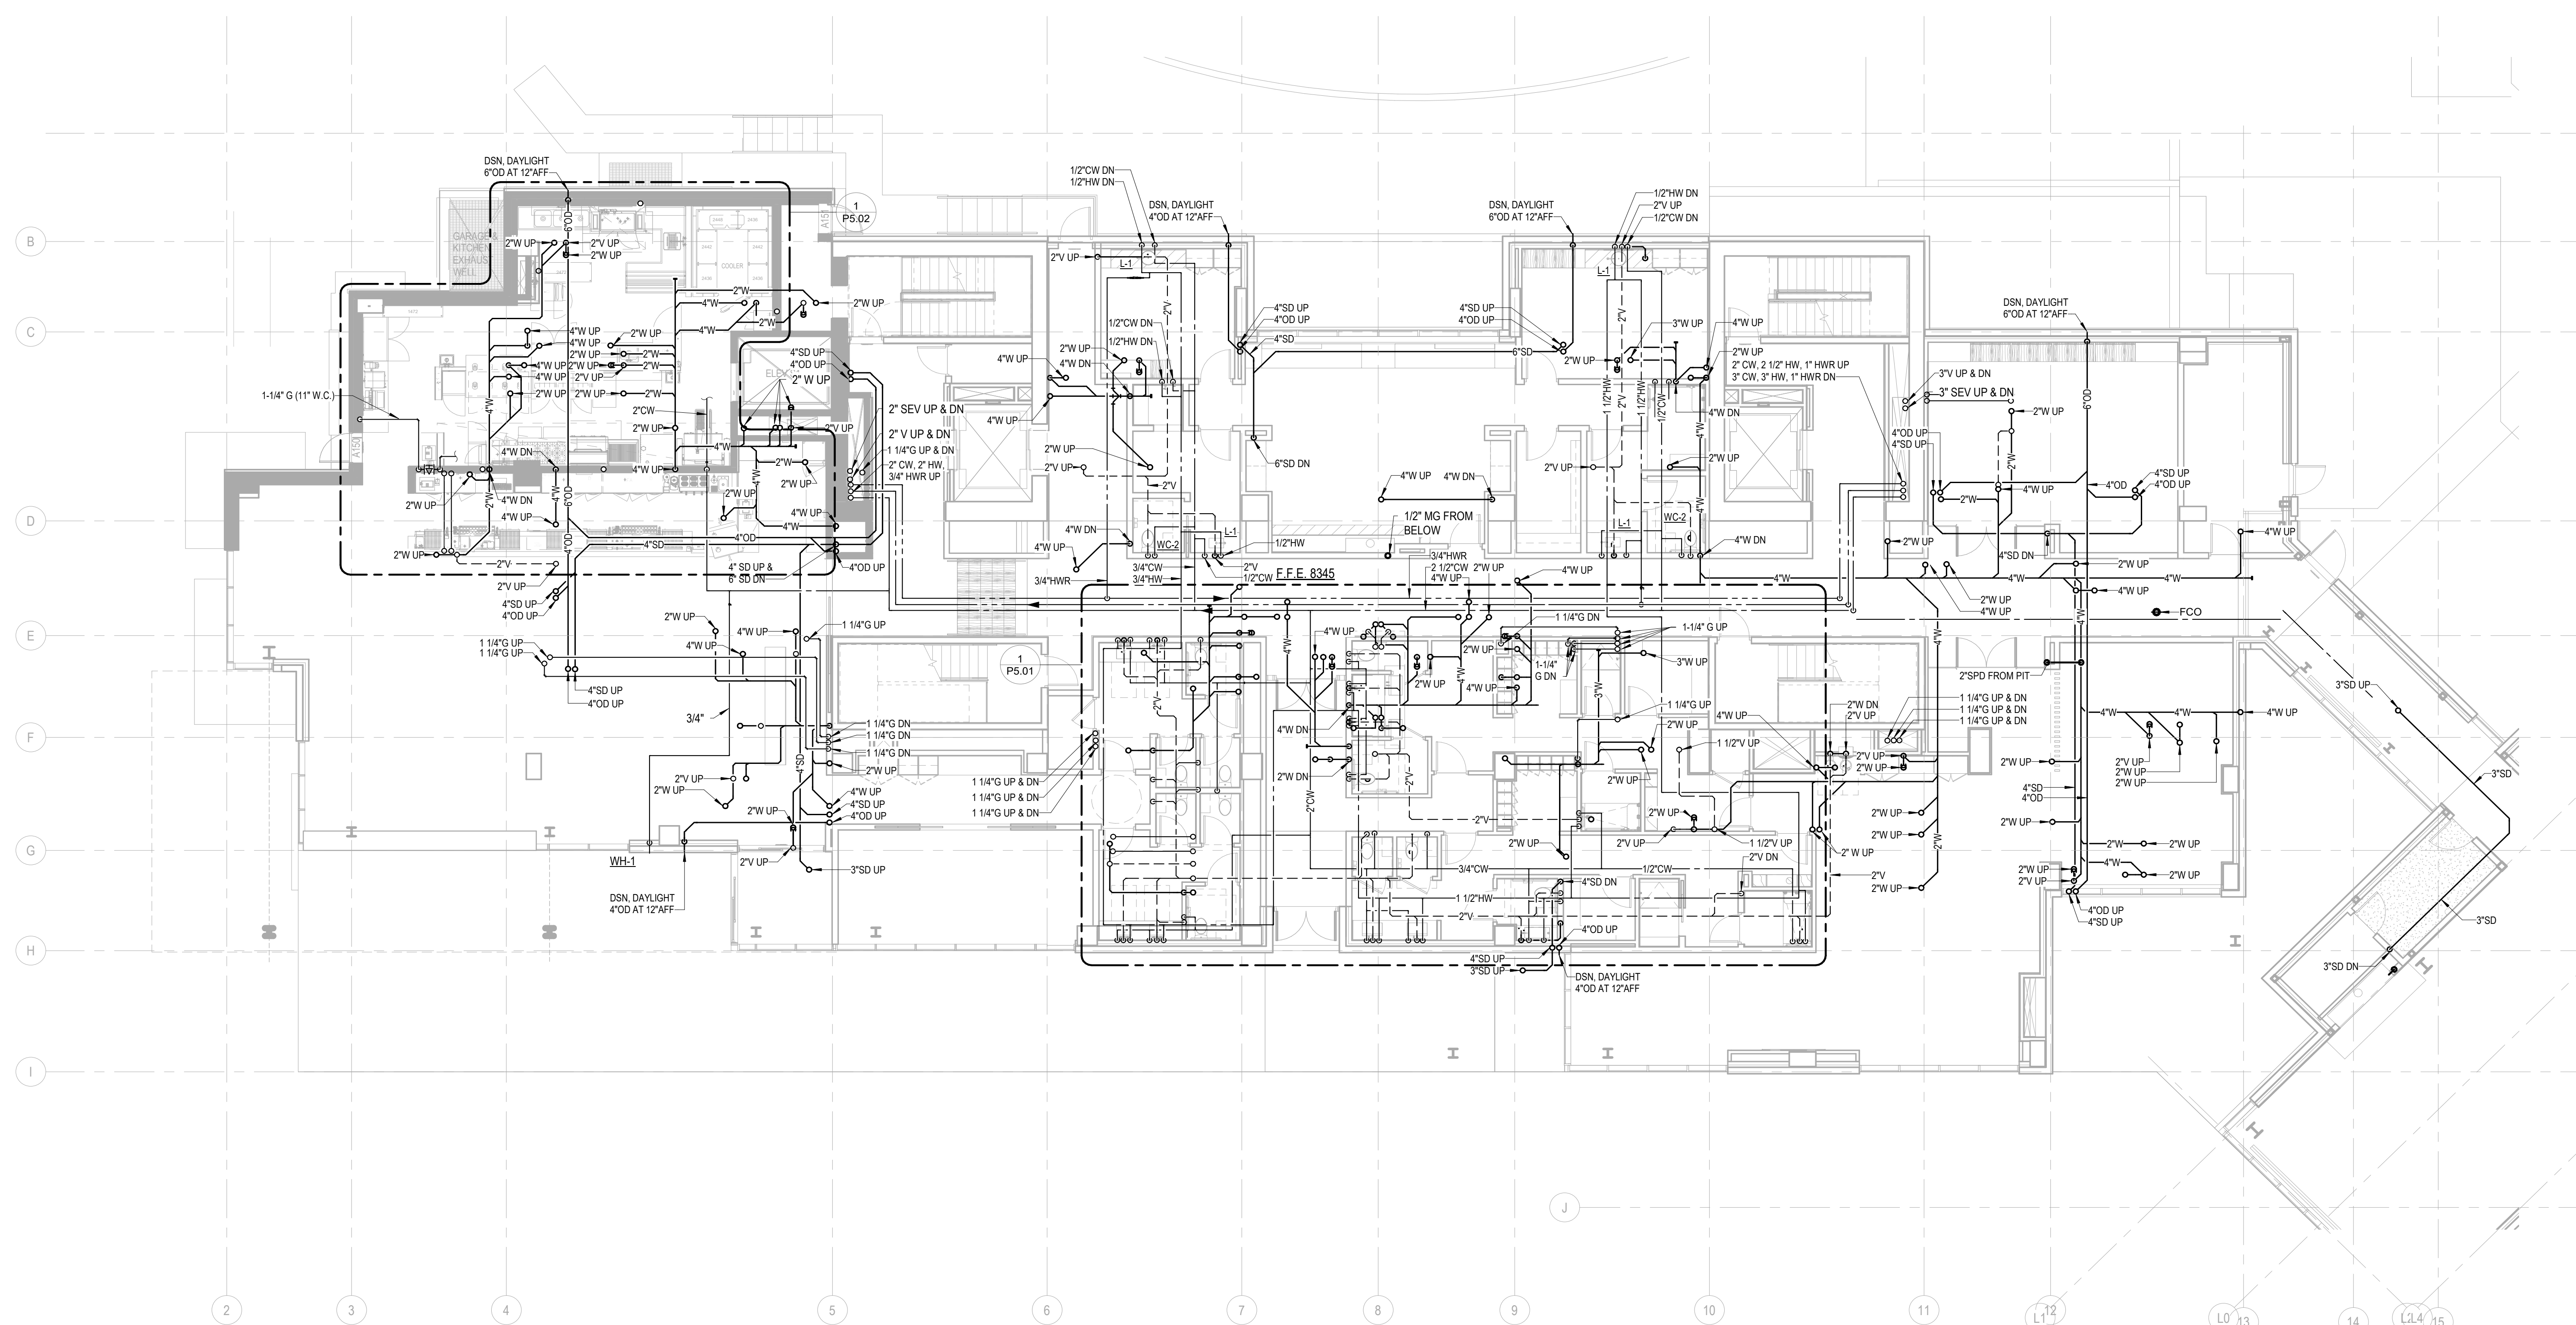

 
1 PLAN - TOWER A - LVL 1
SCALE: 1/8" = 1'-0"



159 South Jackson St, Suite 600
Seattle, Washington 98104 USA
+1 206 624 5670 olsorkundig.com

Olson Kundig

Project: **Sommet Blanc - Bldg AB**
DEER VALLEY, UTAH

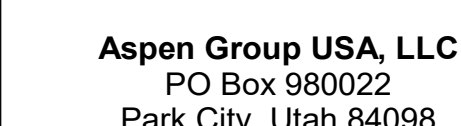

Pool Consultant
Cloward H20
2896 N University Ave., Suite 290
Provo, UT 84604

Landscape Architect
EPG Design
6949 South High Tech Drive, Suite 101
Midvale, Utah 84047

Specifications Writer
Friday Group
88 Mainelli Road
Middlebury, VT

Code Consultant
Holmes
600 1st Avenue, Suite 200
Seattle, WA 98104

Fire Protection Engineer
Jensen Hughes
One Research Drive, Suite 305C
Westborough, MA 01581

Vertical Transportation Consultant
Lorch Bates
19515 North Creek Parkway, Suite 300
Bothell, WA 98011

Structural Engineer
Magnusson Klemencic Associates
1301 5th Ave, Suite 3200
Seattle, WA 98101

Lighting Designer
O-
1319 SE MLK Blvd, Suite 210
Portland, Oregon 97219

Building Envelope Consultant
RDH
2101 N 34th St
Seattle, WA 98103

Accessibility Consultant
Studio Pacifica
2144 Westlake Ave N, Suite F
Seattle, WA 98109

MEP Engineer
WSP USA
1001 Fourth Ave., Suite 3100
Seattle, WA 98154

principal architect _____
project manager _____
drawn by _____
checked by GM
job no. 2021-0595
date 5/31/2024

revisions:


B	5/31/2024	IFC 3
1	10/05/2022	PERMIT RESUBMITTAL

no.	date	b
-----	------	---

IFC Set 3 of 3
5/31/2024


PLAN - TOWER A - LVL 2

P2.2A.12

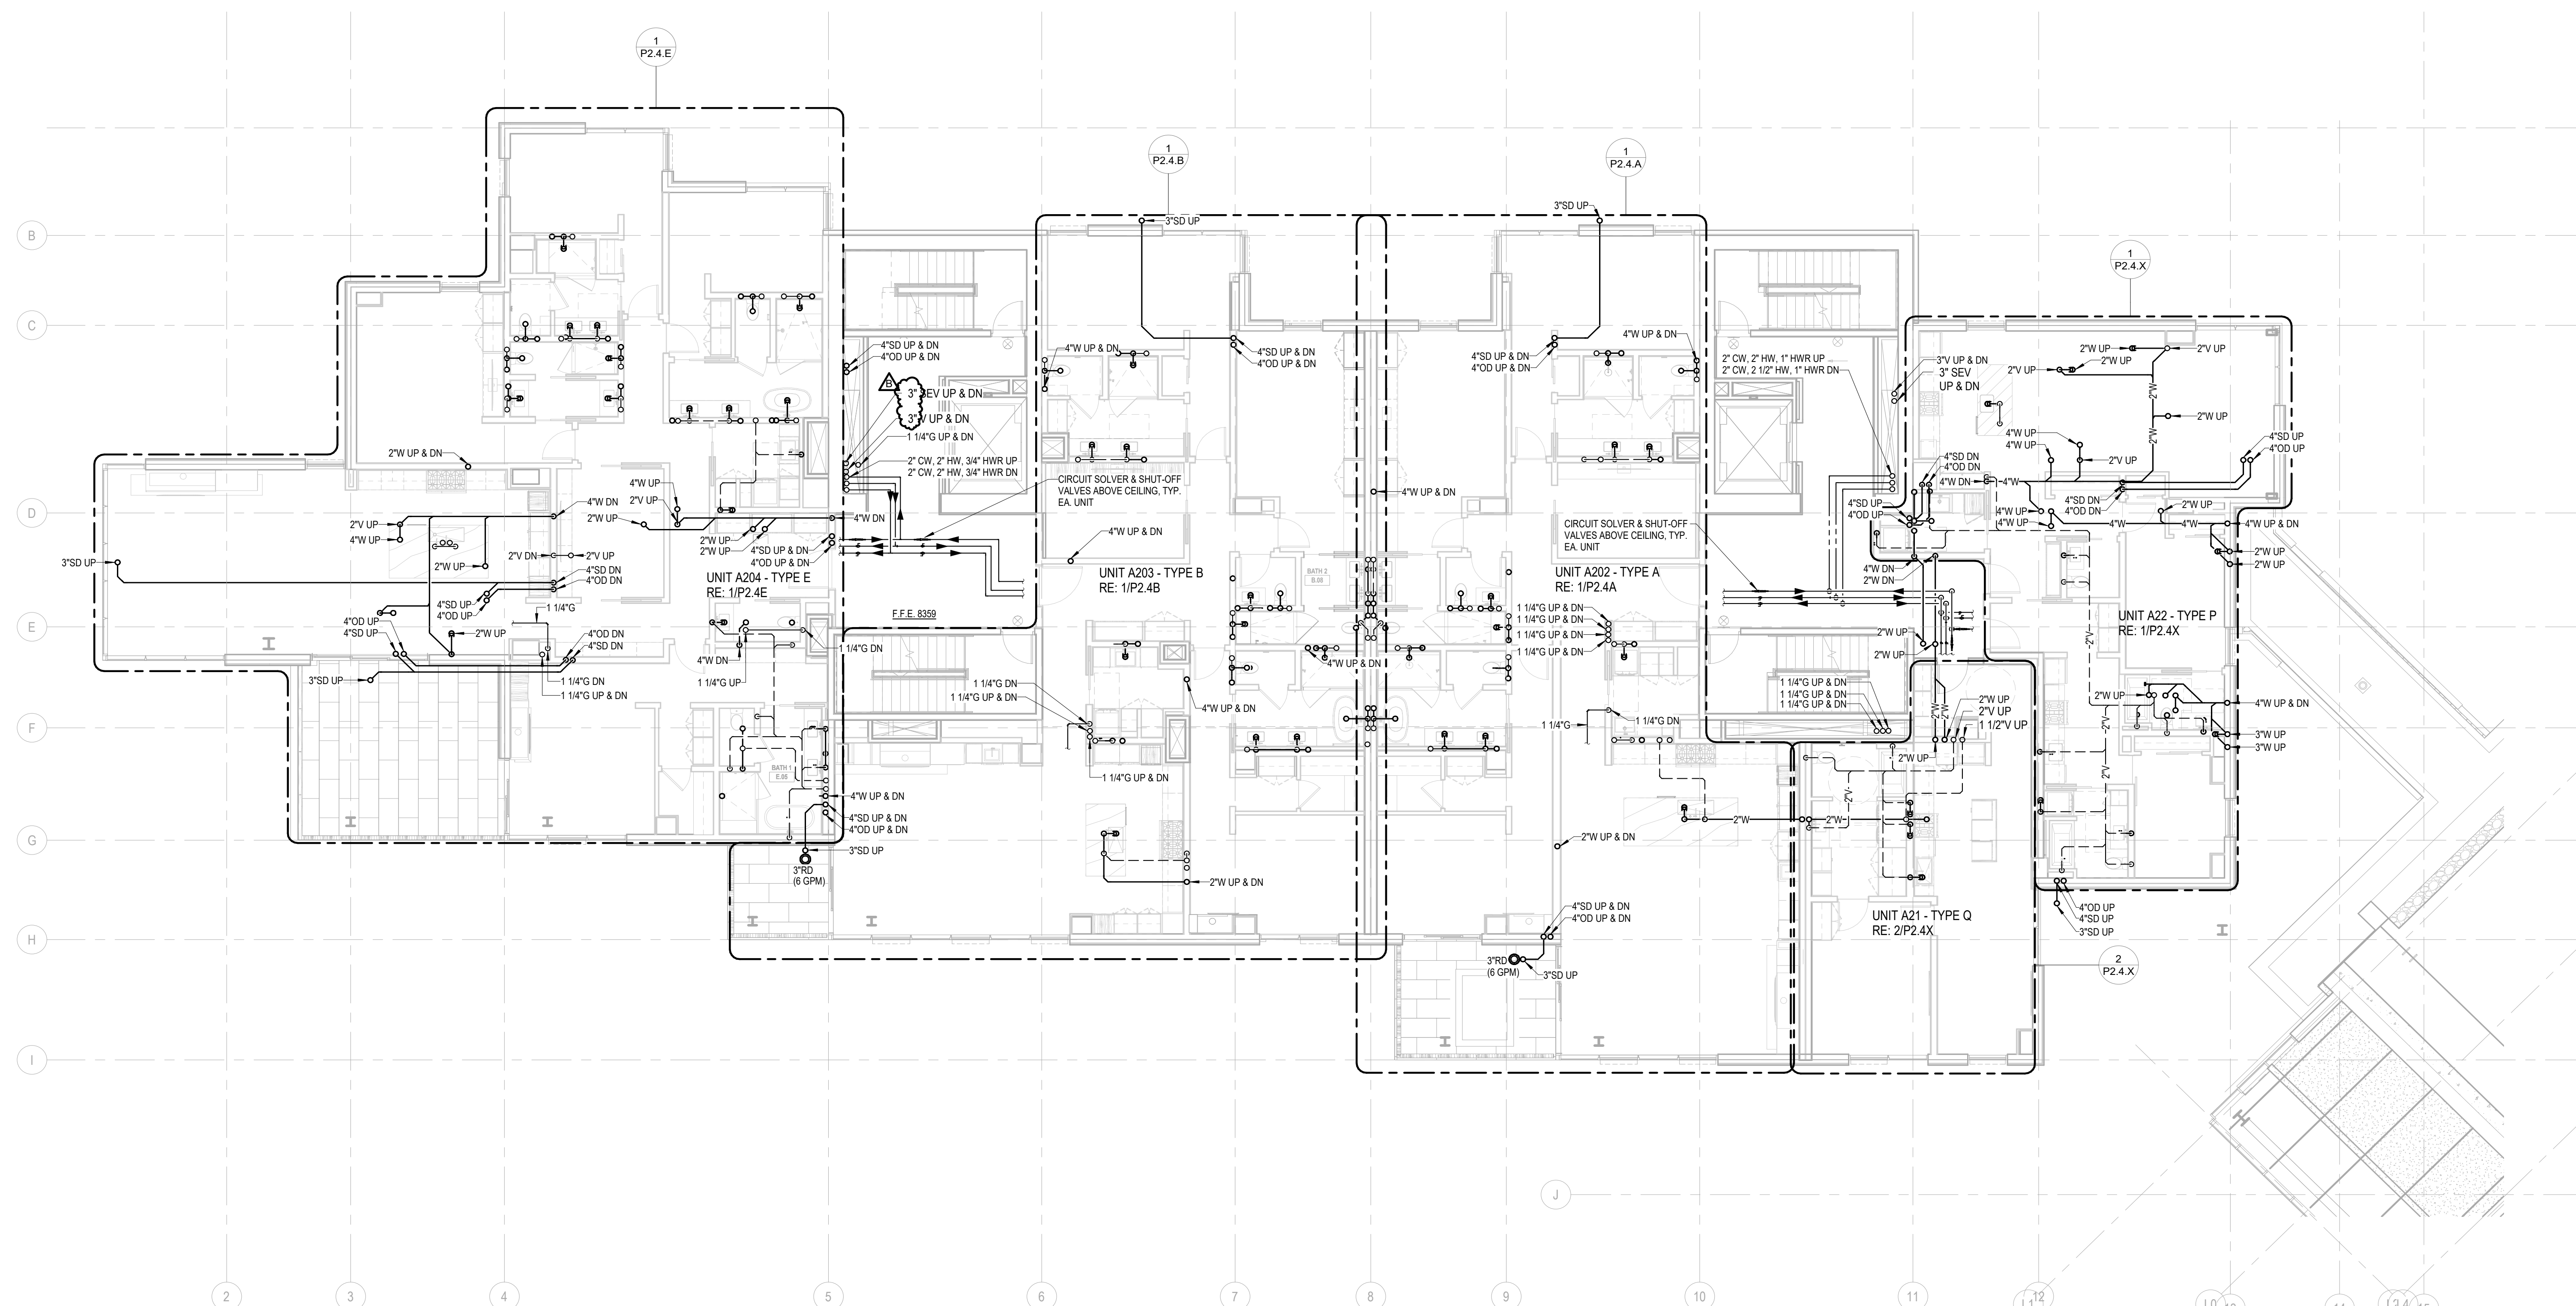


1 PLAN - TOWER A - LVL 2
SCALE: 1/8" = 1'-0"

 SCALE: 1/8" = 1' 0"



Olson Kundig

Project: **Sommet Blanc - Bldg AB**
DEER VALLEY, UTAH

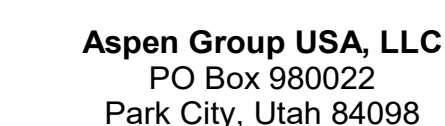

principal architect _____
project manager _____
drawn by _____
checked by GM
job no. 2021-0595
date 5/31/2024

revisions:


B	5/31/2024	IFC 3
1	10/05/2022	PERMIT RESUBMITTAL

no.	date	b
-----	------	---

IFC Set 3 of 3
5/31/2024


PLAN - TOWER A - LVL 3

P2.2A.13

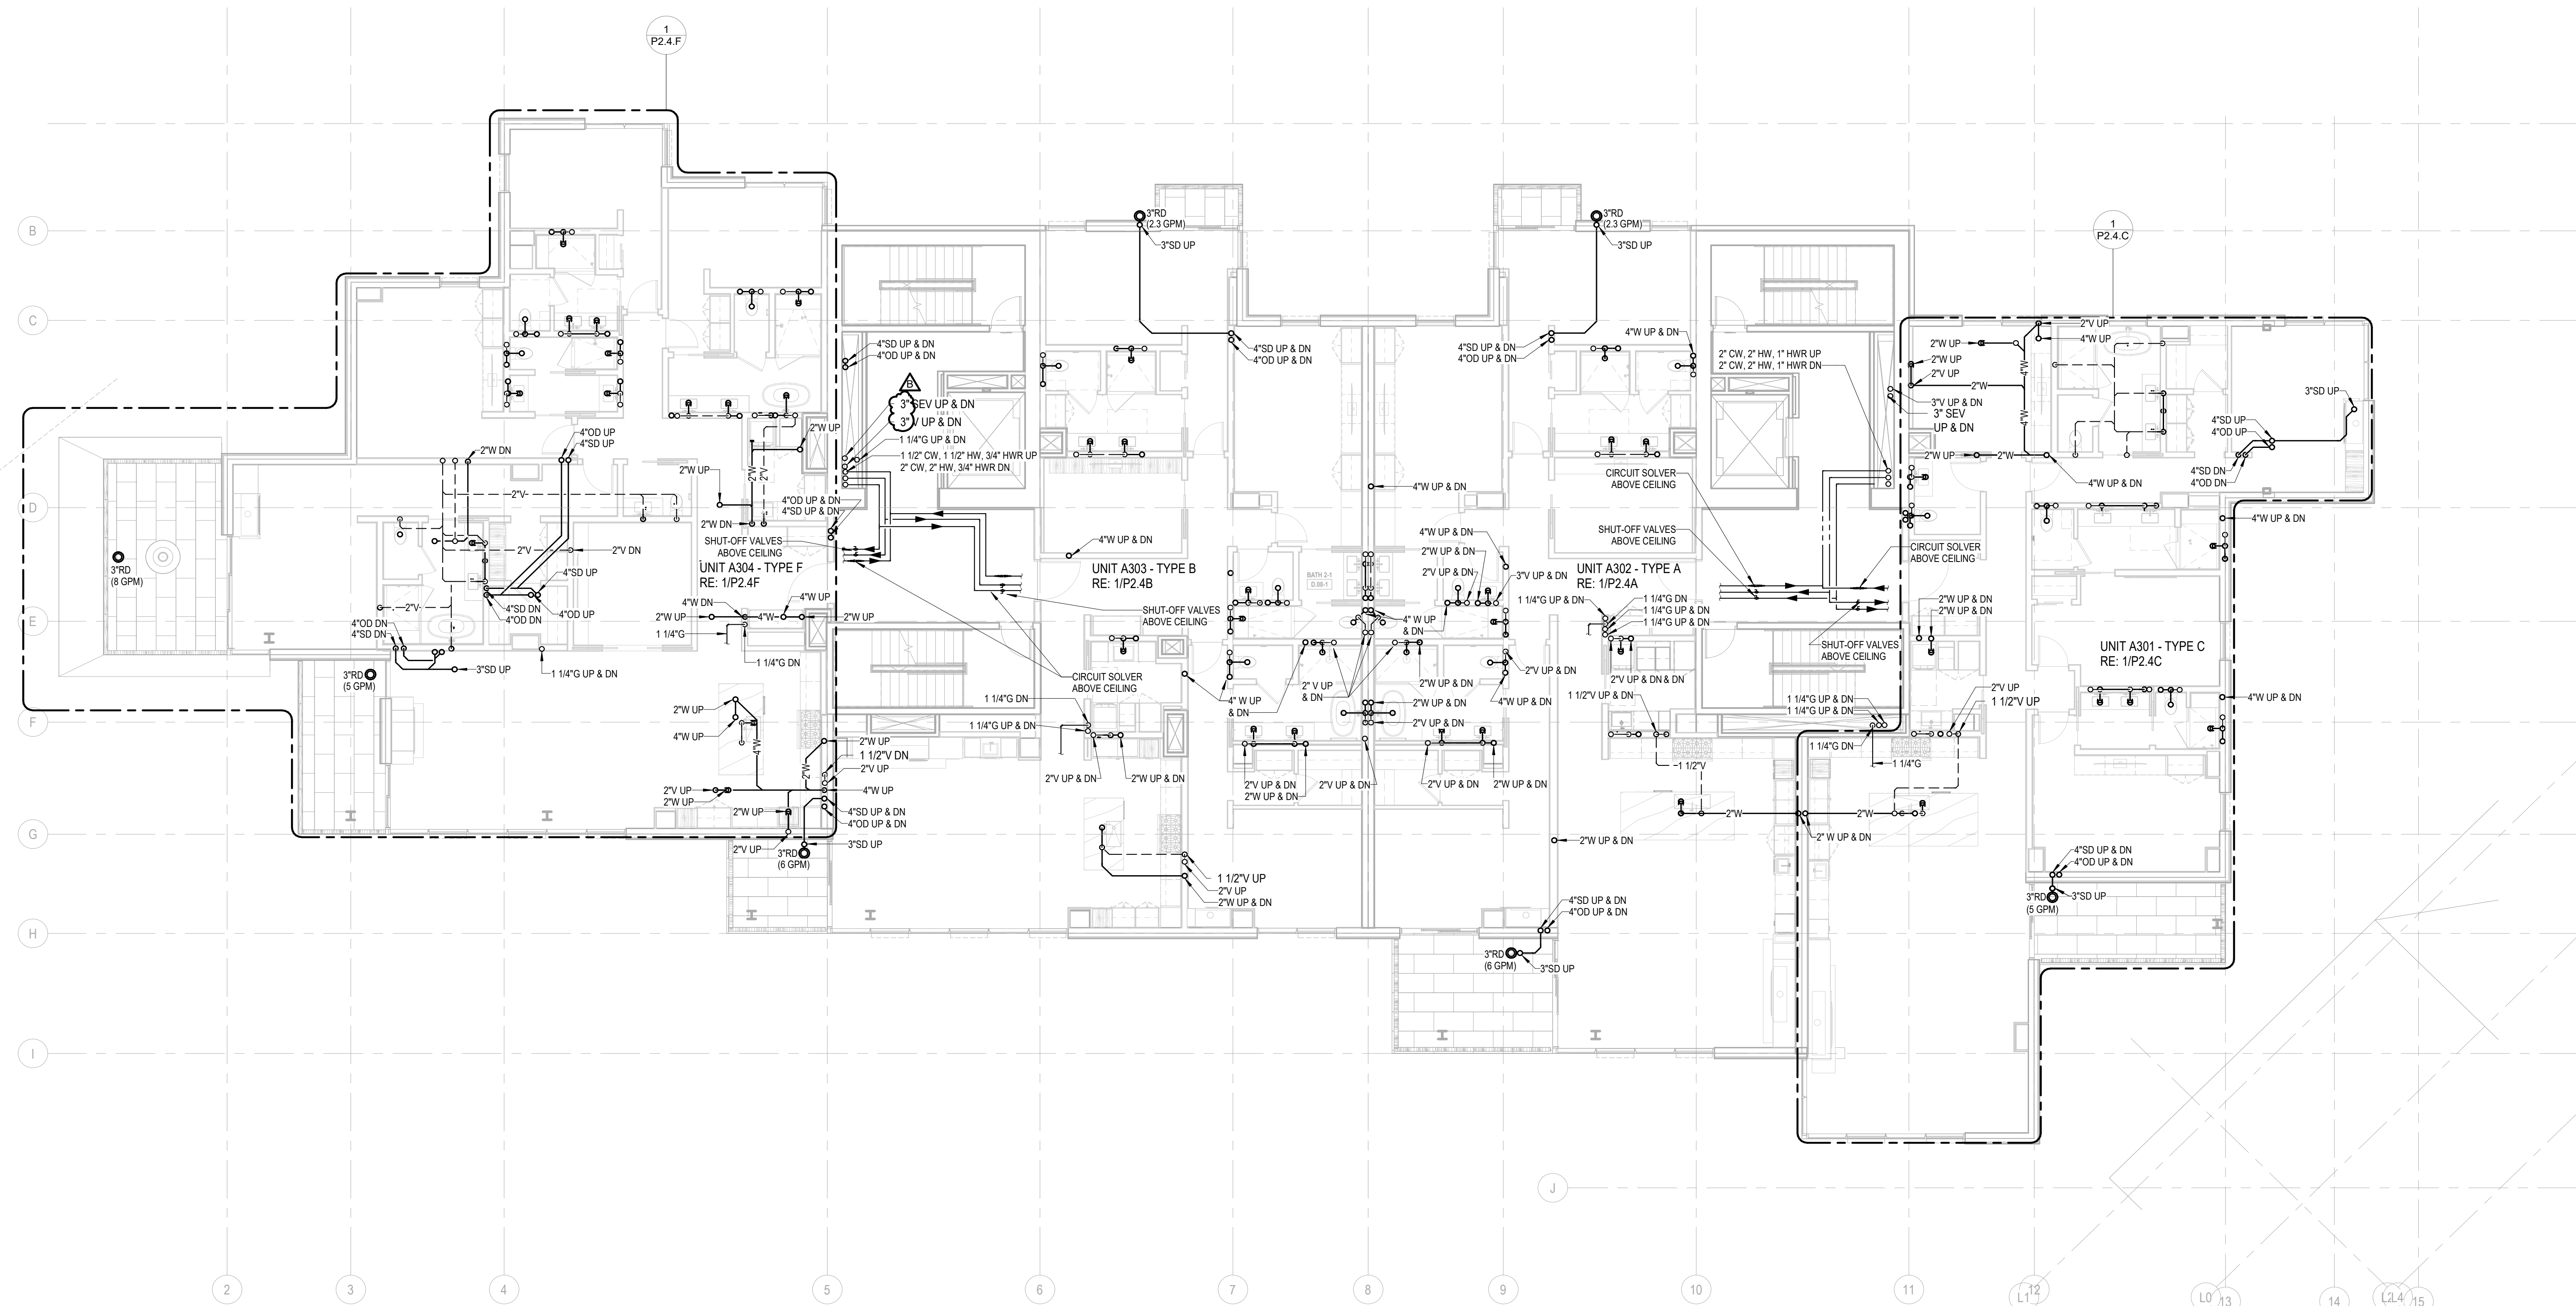

1 PLAN - TOWER A - LVL 3
SCALE: 1/8" = 1'-0"

 
SCALE: 1/8" = 1'-0"



159 South Jackson St, Suite 600
Seattle, Washington 98104 USA
+1 206 624 5670 olsorkundig.com

Olson Kundig

Project: **Sommet Blanc - Bldg AB**
DEER VALLEY, UTAH

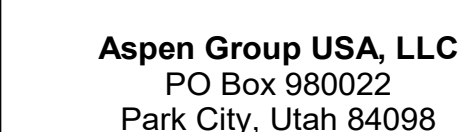

Pool Consultant
Cloward H20
2896 N University Ave., Suite 290
Provo, UT 84604

Landscape Architect
EPG Design
6949 South High Tech Drive, Suite 101
Midvale, Utah 84047

Friday Group
88 Mainelli Road
Middlebury, VT

Code Consultant
Holmes
600 1st Avenue, Suite 200A
Seattle, WA 98104

Fire Protection Engineer
Jensen Hughes
One Research Drive, Suite 305C
Westborough, MA 01581

Vertical Transportation Consultant
Lerch Bates
19515 North Creek Parkway, Suite 300
Bothell, WA 98011

Structural Engineer
Magnusson Klemencic Associates
1301 5th Ave, Suite 3200
Seattle, WA 98101

Lighting Designer
O-
1319 SE MLK Blvd, Suite 210
Portland, Oregon 97219

Building Envelope Consultant
RDH
2101 N 34th St
Seattle, WA 98103

Accessibility Consultant
Studio Pacifica
2144 Westlake Ave N, Suite F
Seattle, WA 98109

MFP Engineer
WSP USA
1001 Fourth Ave., Suite 3100
Seattle, WA 98154

principal architect _____
project manager _____
drawn by _____
checked by GM _____
job no. 2021-0696
date 5/31/2024

revisions:


B	5/31/2024	IFC 3
1	10/06/2022	PERMIT RESUBMITTAL

no.	date	b
-----	------	---


IFC Set 3 of 3
5/31/2024

PLAN - TOWER A - LVL 4

P2.2A.14

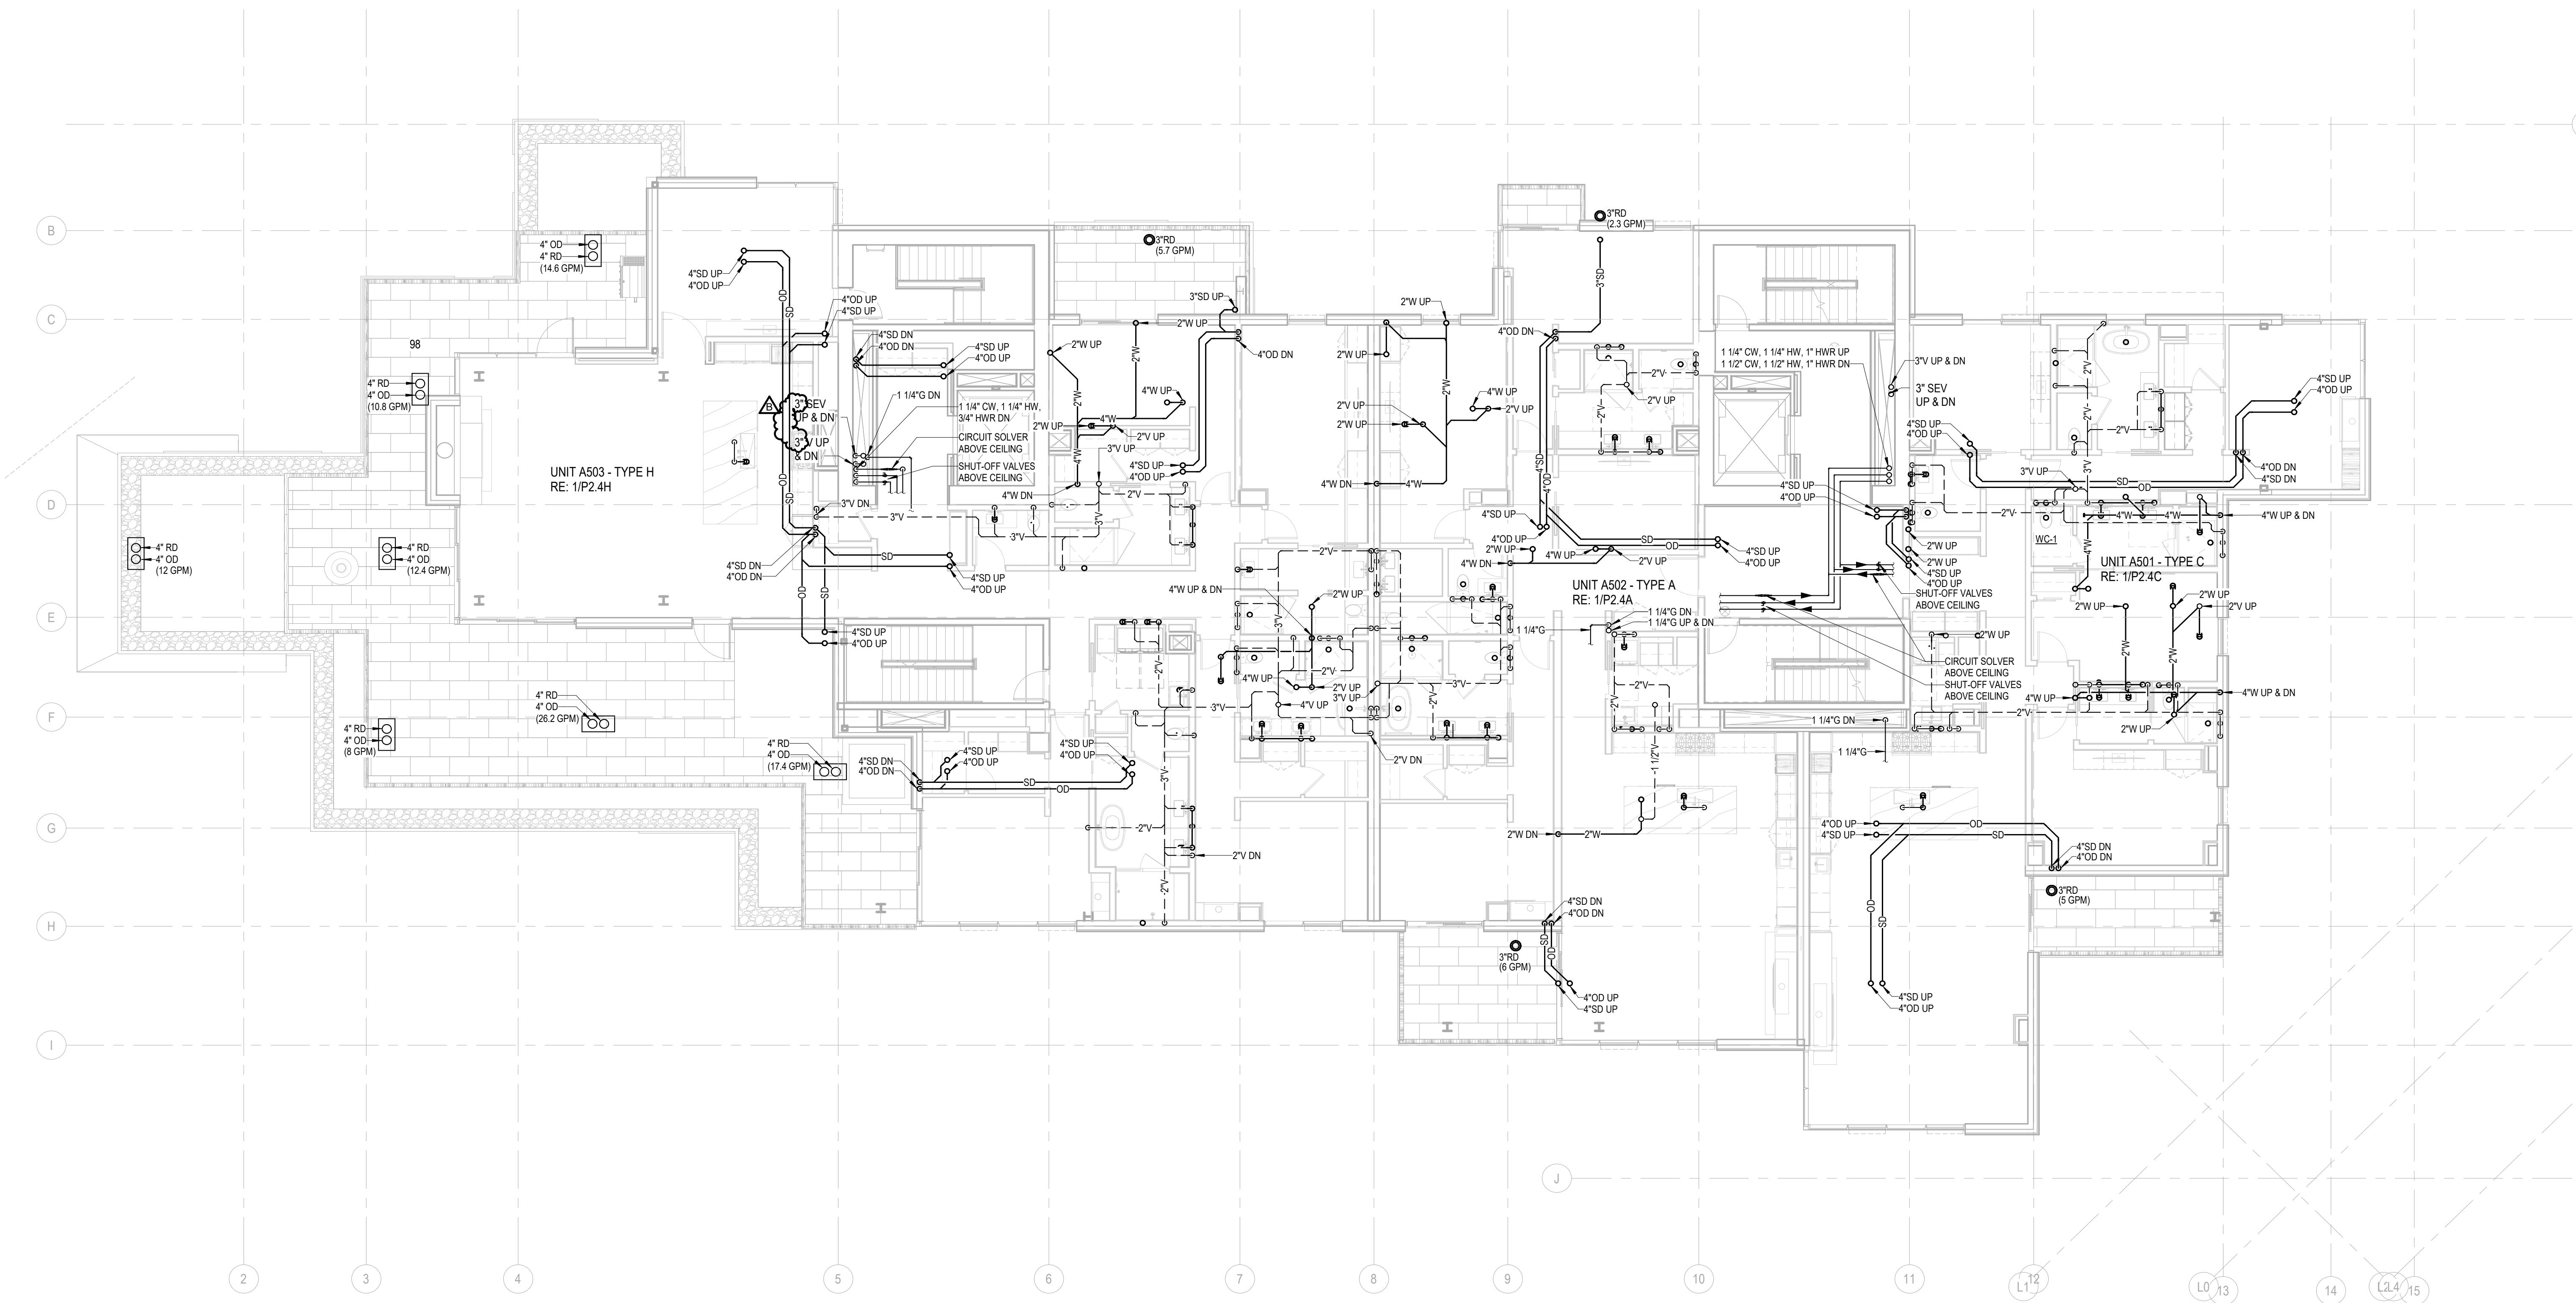

1 PLAN - TOWER A - LVL 5
SCALE: 1/8" = 1'-0"

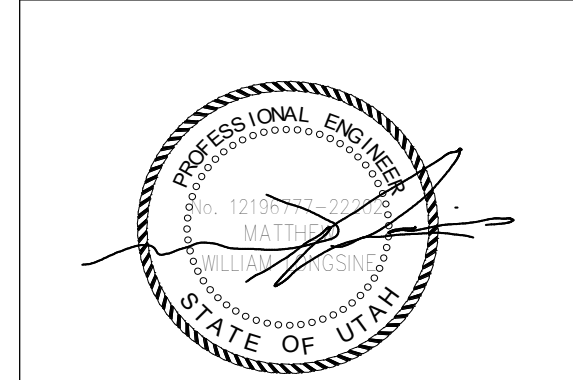

Reserved for permit stamp

100 South Jackson St. Suite 600
Seattle, Washington 98101 USA
+1 206 804 6870 olsonkundig.com

Olson Kundig

Project
Sommet Blanc - Bldg AB
DER VALLEY, UTAH

ASPEN GROUP

Aspen Group USA, LLC
PO Box 980022
Park City, Utah 84098


- Pool Consultant
Cloward H2O
2006 N University Ave, Suite 290
Provo, UT 84604
- Landscape Architect
EPG Design
6949 South High Tech Drive, Suite 100
Midvale, Utah 84047
- Specifications Writer
Friday Group
88 Marsh Road
Middlebury, VT
- Code Consultant
Holmes
800 1st Avenue, Suite 200A
Seattle, WA 98104
- Fire Protection Engineer
Jensen Hughes
One Research Drive, Suite 305C
Westborough, MA 01581
- Vertical Transportation Consultant
Lerch Bates
19515 North Creek Parkway, Suite 304
Bellevue, WA 98011
- Structural Engineer
Magnusson Klemencic Associates
1301 6th Ave, Suite 3200
Seattle, WA 98101
- Lighting Designer
O-
1319 SE MLK Blvd, Suite 210
Portland, Oregon 97219
- Building Envelope Consultant
RDM
2101 N 34th St
Seattle, WA 98103
- Accessibility Consultant
Studio Pacifica
2144 Westlake Ave N, Suite F
Seattle, WA 98109
- MEP Engineer
WSP USA
1001 Fourth Ave., Suite 3100
Seattle, WA 98154

principal architect _____
project manager _____
drawn by _____
checked by _____
job no. 2021-0595
date 5/31/2024

revisions:

B	5/31/2024	FC3
T	10/25/2022	PERMIT RESUBMITTAL

 
no. date by



159 South Jackson St, Suite 600
Seattle, Washington 98104 USA
+1 206 624 5670 clsonkundig.com

Olson Kundig

Project: **Sommet Blanc - Bldg AB**
DEER VALLEY, UTAH

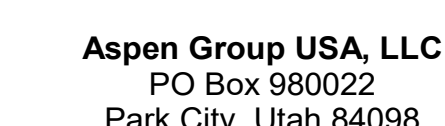

Pool Consultant
Cloward H20
2896 N University Ave, Suite 290
Provo, UT 84604

Landscape Architect
EPG Design
6949 South High Tech Drive, Suite 100
Midvale, Utah 84047

Specifications Writer
Friday Group
88 Mainelli Road
Middlebury, VT

Code Consultant
Holmes
600 1st Avenue, Suite 200A
Seattle, WA 98104

Fire Protection Engineer
Jensen Hughes
One Research Drive, Suite 305C
Westborough, MA 01581

Vertical Transportation Consultant
Lerch Bates
19515 North Creek Parkway, Suite 300
Bothell, WA 98011

Structural Engineer
Magnusson Klemencic Associates
1301 5th Ave, Suite 3200
Seattle, WA 98101

Lighting Designer
O-
1319 SE MLK Blvd, Suite 210
Portland, Oregon 97219

Building Envelope Consultant
RDH
2101 N 34th St
Seattle, WA 98103

Accessibility Consultant
Studio Pacifica
2144 Westlake Ave N, Suite F
Seattle, WA 98109

MEP Engineer
WSP USA
1001 Fourth Ave., Suite 3100
Seattle, WA 98154

principal architect _____
project manager _____
drawn by _____
checked by GM _____
job no. 2021-0595
date 5/31/2024

revisions:


B	5/31/2024	IFC 3
1	10/05/2022	PERMIT RESUBMITTAL

no.	date	b
-----	------	---


IFC Set 3 of 3
5/31/2024

PLAN - TOWER A - LVL 6

P2.2A.16

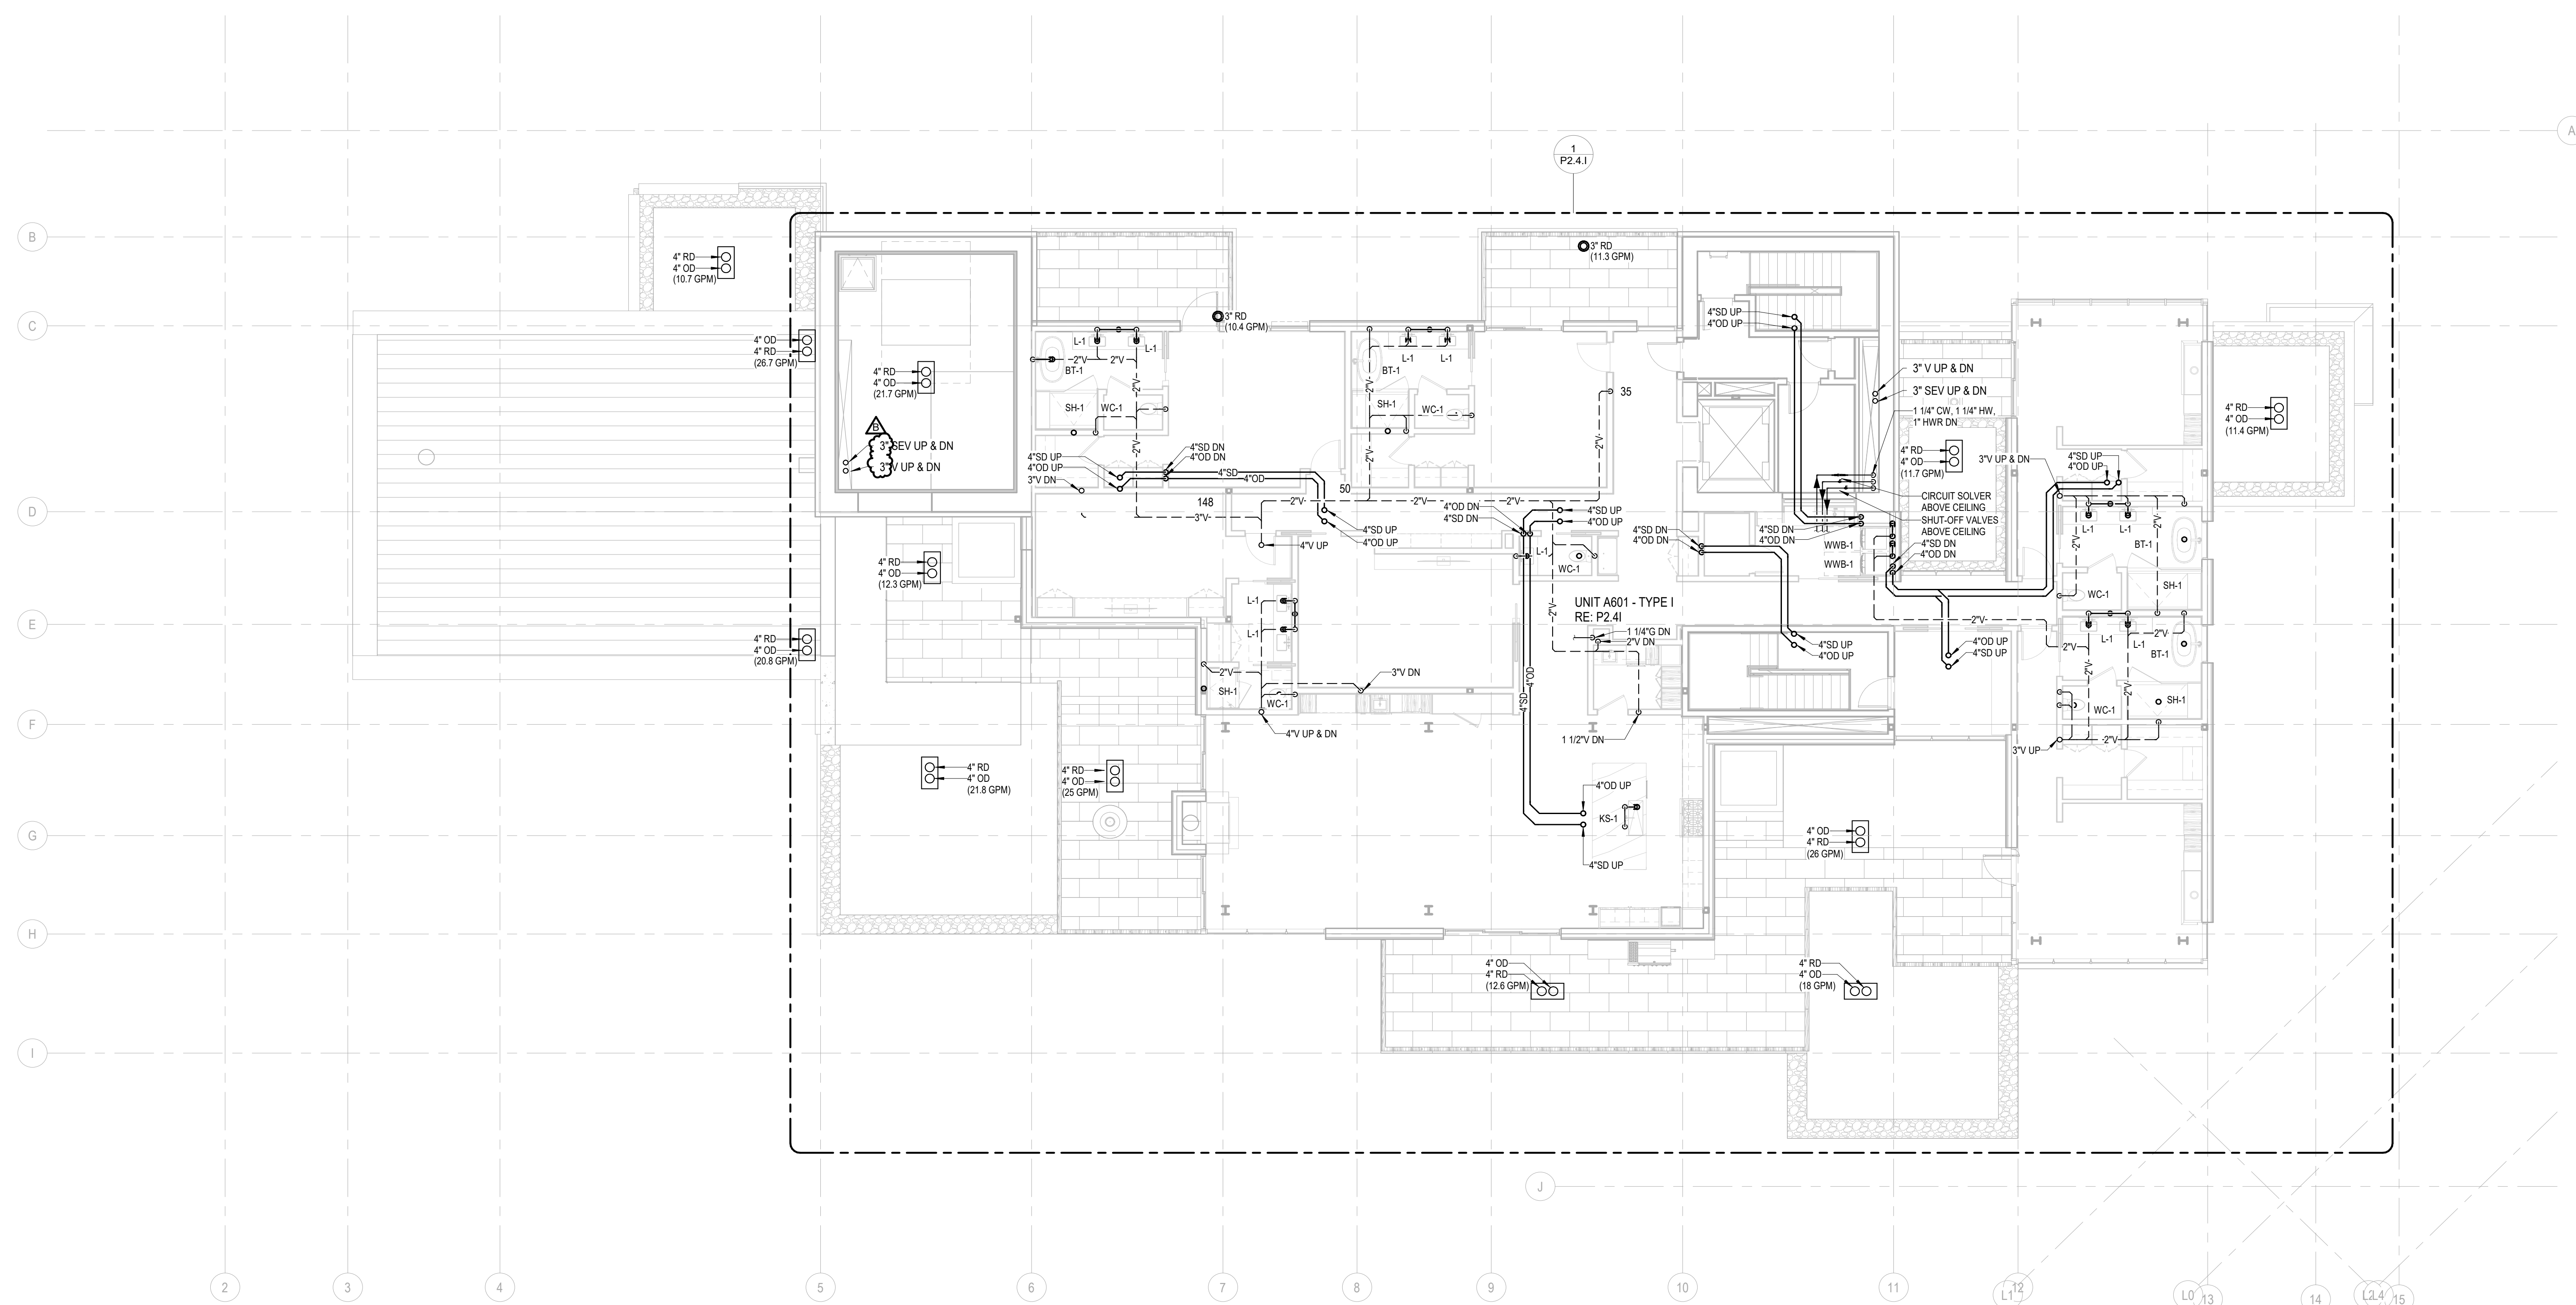

 
1 PLAN - TOWER A - LVL 6
SCALE: 1/8" = 1'-0"



159 South Jackson St, Suite 600
Seattle, Washington 98104 USA
+1 206 624 5670 dsorkundg.com

Olson Kundig

Project: **Sommet Blanc - Bldg AB**
DEER VALLEY, UTAH

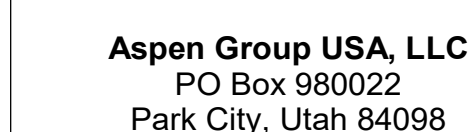

Pool Consultant
Cloward H20
2896 N University Ave, Suite 290
Provo, UT 84604

Landscape Architect
EPG Design
6949 South High Tech Drive, Suite 101
Midvale, Utah 84047

Specifications Writer
Friday Group
88 Mainelli Road
Middlebury, VT

Code Consultant
Holmes
600 1st Avenue, Suite 200
Seattle, WA 98104

Fire Protection Engineer
Jensen Hughes
One Research Drive, Suite 305C
Westborough, MA 01581

Vertical Transportation Consultant
Lerch Bates
19515 North Creek Parkway, Suite 300
Bothell, WA 98011

Structural Engineer
Magnusson Klemencic Associates
1301 5th Ave, Suite 3200
Seattle, WA 98101

Lighting Designer
O-
1319 SE MLK Blvd, Suite 210
Portland, Oregon 97219

Building Envelope Consultant
RDH
2101 N 34th St
Seattle, WA 98103

Accessibility Consultant
Studio Pacifica
2144 Westlake Ave N, Suite F
Seattle, WA 98109

MFP Engineer
WSP USA
1001 Fourth Ave., Suite 3100
Seattle, WA 98154

principal architect _____
project manager _____
drawn by _____
checked by GM
job no. 2021-0696
date 5/17/2024

revisions:


1 10/06/2022 PERMIT RESUBMITTAL

no.	date	b
-----	------	---

IFC Set 2 of 3
5/17/2024

PLAN - TOWER A - ROOF

 
P2.2A.R



159 South Jackson St, Suite 600
Seattle, Washington 98104 USA
+1 206 624 5670 olsonkundig.com

Olson Kundig

Project: **Sommet Blanc - Bldg AB**
DEER VALLEY, UTAH

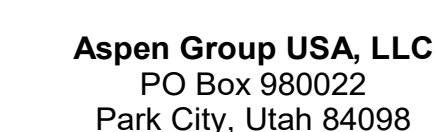

Pool Consultant
Cloward H20
2896 N University Ave, Suite 290
Provo, UT 84604

Landscape Architect
EPG Design
6949 South High Tech Drive, Suite 100
Midvale, Utah 84047

Specifications Writer
Friday Group
88 Mainelli Road
Middletown, CT

Code Consultant
Holmes
600 1st Avenue, Suite 200A
Seattle, WA 98104

Fire Protection Engineer
Jensen Hughes
One Research Drive, Suite 305C
Westborough, MA 01581

Vertical Transportation Consultant
Lerch Bates
19515 North Creek Parkway, Suite 304
Bothell, WA 98011

Structural Engineer
Magnusson Klemencic Associates
1301 5th Ave, Suite 3200
Seattle, WA 98101

Lighting Designer
O-
1319 SE MLK Blvd, Suite 210
Portland, Oregon 97219

Building Envelope Consultants
RDH
2101 N 34th St
Seattle, WA 98103

Accessibility Consultant
Studio Pacifica
2144 Westlake Ave N, Suite F
Seattle, WA 98109

MEP Engineer
WSP USA
1001 Fourth Ave., Suite 3100
Seattle, WA 98154

principal architect _____
project manager _____
drawn by _____
checked by GM
job no. 2021-0595
date 5/17/2024

revisions:


no.	date	by
-----	------	----

IFC Set 2 of 3
5/17/2024

PLAN - LOBBY

 P2.2AB.11






159 South Jackson St, Suite 600
Seattle, Washington 98104 USA
+1 206 624 5670 olsonkundig.com

Olson Kundaig

Sommet Blanc - Bldg AB
DEER VALLEY, UTAH

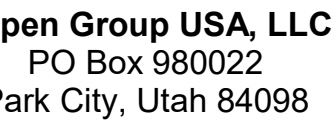

PE Engineer
SP USA
101 Fourth Ave., Suite 3100
Seattle, WA 98154

principal architect _____
project manager _____
drawn by _____
checked by GM
job no. 2021-0595
date 5/31/2024

ns:

26/2024	ASI 2
10/6/2022	PERMIT RESUBMITTAL

date by

 
C Set 3 of 3
5/31/2024

AN - TOWER B - LVL

P2.2B.01




P2.2B.01U



159 South Jackson St., Suite 600
Seattle, Washington 98104 USA
+1 206 624 5870 olsonkundig.com

Olson Kundaig

Sommet Blanc - Bldg AB
DEER VALLEY, UTAH

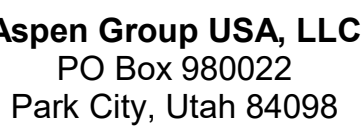

Edward H2O
16 N University Ave, Suite 290
Provo, UT 84604

3D Design
9 South High Tech Drive, Suite 100
Pleasantville, Utah 84047

Specifications Writer
Play Group
Mainelli Road
Middlebury, VT

le Consultant
mes
1st Avenue, Suite 200A
ttle, WA 98104

Protection Engineer
Ken Hughes
Research Drive, Suite 305C
Westborough, MA 01581

Michael Bates
15 North Creek Parkway, Suite 304
Seattle, WA 98011

Structural Engineer
Knudson Klemencic Associates
115th Ave, Suite 3200
Seattle, WA 98101

Marketing Designer
9 SE MLK Blvd, Suite 210
Portland, Oregon 97219

Envelope Consultant
H
1 N 34th St
Seattle, WA 98103

Feasibility Consultant
Radio Pacifica
4 Westlake Ave N, Suite F
Seattle, WA 98109

P Engineer
P USA
1 Fourth Ave., Suite 3100
Seattle, WA 98154

principal architect _____
project manager _____
drawn by _____
checked by GM _____
job no. 2021-0595
date 5/31/2024

visions:


7/26/2024	ASI 2
5/05/2023	PERMIT COMMENT RESPONSE
10/06/2022	PERMIT RESUBMITTAL

o. date _____ by _____

FC Set 3 of 3
5/31/2024

AN - TOWER B - LVL

 
P2.2B.02



159 South Jackson St, Suite 600
Seattle, Washington 98104 USA
+1 206 624 5670 olsorkundig.com

Olson Kundig

Project: **Sommet Blanc - Bldg AB**
DEER VALLEY, UTAH

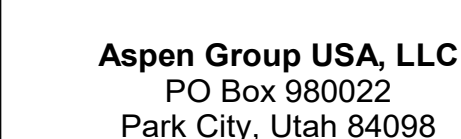

Pool Consultant
Cloward H20
2896 N University Ave., Suite 290
Provo, UT 84604

Landscape Architect
EPG Design
6949 South High Tech Drive, Suite 101
Midvale, Utah 84047

Specifications Writer
Friday Group
88 Mainelli Road
Middleboro, VT

Code Consultant
Holmes
600 1st Avenue, Suite 200A
Seattle, WA 98104

Fire Protection Engineer
Jensen Hughes
One Research Drive, Suite 305
Westborough, MA 01581

Vertical Transportation Consultant
Lorch Bates
19515 North Creek Parkway, Suite 300
Bothell, WA 98011

Structural Engineer
Magnusson Klemencic Associates
1301 5th Ave, Suite 3200
Seattle, WA 98101

Lighting Designer
O-
1319 SE MLK Blvd, Suite 210
Portland, Oregon 97219

Building Envelope Consultant
RDH
2101 N 34th St
Seattle, WA 98103

Accessibility Consultant
Studio Pacifica
2144 Westlake Ave N, Suite F
Seattle, WA 98109

MEP Engineer
WSP USA
1001 Fourth Ave., Suite 3100
Seattle, WA 98154

principal architect _____
project manager _____
drawn by _____
checked by GM
job no. 2021-0596
date 5/17/2024

revisions:


1 10/06/2022 PERMIT RESUBMITTAL

no.	date	b
-----	------	---

IFC Set 2 of 3
5/17/2024


PLAN - TOWER B - LVL
P1

 P2.2B.03



Olson Kundig

project: **Sommet Blanc - Bldg AB**
DEER VALLEY, UTAH

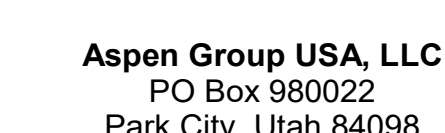

MEP Engineer
WSP USA
1001 Fourth Ave., Suite 3100
Seattle, WA 98154

principal architect _____
project manager _____
drawn by _____
checked by GM _____
job no. 2021-0666
date 5/17/2024


revisions:

1	10/05/2022	PERMIT RESUBMITTAL
no.	date	b

IFC Set 2 of 3
5/17/2024

PLAN TOWER B LVL 1

 
P2.2B.11



159 South Jackson St, Suite 600
Seattle, Washington 98104 USA
+1 206 624 5670 olsorkundig.com

Olson Kundig

Project: **Sommet Blanc - Bldg AB**
DEER VALLEY, UTAH

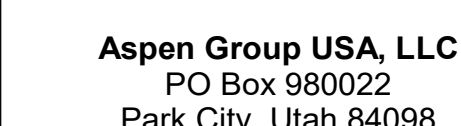

Pool Consultant
Cloward H2O
2896 N University Ave, Suite 290
Provo, UT 84604

Landscape Architect
EPG Design
6949 South High Tech Drive, Suite 101
Midvale, Utah 84047

Specifications Writer
Friday Group
88 Mainelli Road
Middlebury, VT

Code Consultant
Holmes
600 1st Avenue, Suite 200A
Seattle, WA 98104

Fire Protection Engineer
Jensen Hughes
One Research Drive, Suite 305C
Westborough, MA 01581

Vertical Transportation Consultant
Lorch Bates
19515 North Creek Parkway, Suite 300
Bothell, WA 98011

Structural Engineer
Magnusson Klemencic Associates
1301 5th Ave, Suite 3200
Seattle, WA 98101

Lighting Designer
O-
1319 SE MLK Blvd, Suite 210
Portland, Oregon 97219

Building Envelope Consultant
RDH
2101 N 34th St
Seattle, WA 98103

Accessibility Consultant
Studio Pacifica
2144 Westlake Ave N, Suite F
Seattle, WA 98109

MEP Engineer
WSP USA
1001 Fourth Ave., Suite 3100
Seattle, WA 98154

principal architect _____
project manager _____
drawn by _____
checked by GM
job no. 2021-0596
date 5/17/2024

revisions:


1 10/06/2022 PERMIT RESUBMITTAL

no.	date	b
-----	------	---

IFC Set 2 of 3
5/17/2024

PLAN - TOWER B - LVL 2

 
P2.2B.12



159 South Jackson St, Suite 600
Seattle, Washington 98104 USA
+1 206 624 5670 olsorkundig.com

Olson Kundig

Project: **Sommet Blanc - Bldg AB**
DEER VALLEY, UTAH

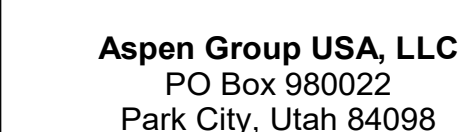

Pool Consultant
Cloward H20
2896 N University Ave., Suite 290
Provo, UT 84604

Landscape Architect
EPG Design
6949 South High Tech Drive, Suite 101
Midvale, Utah 84047

Specifications Write
Friday Group
88 Mainelli Road
Middlebury, VT

Code Consultant
Holmes
600 1st Avenue, Suite 200A
Seattle, WA 98104

Fire Protection Engineer
Jensen Hughes
One Research Drive, Suite 305C
Westborough, MA 01581

Vertical Transportation Consultant
Lerch Bates
19515 North Creek Parkway, Suite 300
Bothell, WA 98011

Structural Engineer
Magnusson Klemencic Associates
1301 5th Ave, Suite 3200
Seattle, WA 98101

Lighting Designer
O-
1319 SE MLK Blvd, Suite 210
Portland, Oregon 97219

Building Envelope Consultant
RDH
2101 N 34th St
Seattle, WA 98103

Accessibility Consultant
Studio Pacifica
2144 Westlake Ave N, Suite F
Seattle, WA 98109

MFP Engineer
WSP USA
1001 Fourth Ave., Suite 3100
Seattle, WA 98154

principal architect _____
project manager _____
drawn by _____
checked by GM
job no. 2021-0696
date 5/17/2024


revisions:

1	10/05/2022	PERMIT RESUBMITTAL
no.	date	b

IFC Set 2 of 3
5/17/2024


PLAN - TOWER B - I VI 3

 P2.2B.13



Olson Kundig

Project: **Sommet Blanc - Bldg AB**
DEER VALLEY, UTAH

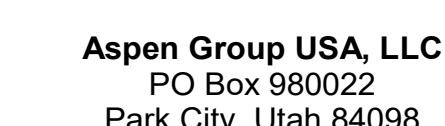

MFP Engineer
WSP USA
1001 Fourth Ave., Suite 3100
Seattle, WA 98154

principal architect _____
project manager _____
drawn by _____
checked by GM _____
job no. 2021-0595
date 5/17/2024

revisions:

1 10/05/2022 PERMIT RESUBMITTA


no.	date	from	to	amount	particulars
1	1/1/19				
2	2/1/19				
3	3/1/19				
84	84/1/19				
85	85				


IFC Set 2 of 3
5/17/2024

PLAN - TOWER B - LVL 4

 P2.2B.14



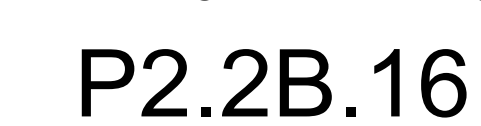




159 South Jackson St, Suite 600
Seattle, Washington 98104 USA
+1 206 624 5670 dsonkundig.com

Olson Kundig

Project: **Sommet Blanc - Bldg AB**
DEER VALLEY, UTAH

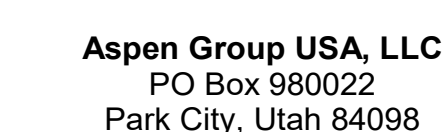

Pool Consultant
Cloward H2O
2896 N University Ave, Suite 290
Provo, UT 84604

Landscape Architect
EPG Design
6949 South High Tech Drive, Suite 101
Midvale, Utah 84047

Specifications Write
Friday Group
88 Mainelli Road
Middlebury, VT

Code Consultant
Holmes
600 1st Avenue, Suite 200A
Seattle, WA 98104

Fire Protection Engineer
Jensen Hughes
One Research Drive, Suite 305C
Westborough, MA 01581

Vertical Transportation Consultant
Lorch Bates
19515 North Creek Parkway, Suite 300
Bothell, WA 98011

Structural Engineer
Magnusson Klemencic Associates
1301 5th Ave, Suite 3200
Seattle, WA 98101

Lighting Designer
O-
1319 SE MLK Blvd, Suite 210
Portland, Oregon 97219

Building Envelope Consultant
RDH
2101 N 34th St
Seattle, WA 98103

Accessibility Consultant
Studio Pacifica
2144 Westlake Ave N, Suite F
Seattle, WA 98109

MEP Engineer
WSP USA
1001 Fourth Ave., Suite 3100
Seattle, WA 98154

principal architect _____
project manager _____
drawn by _____
checked by GM _____
job no. 2021-0595
date 5/17/2024

revisions:


1 10/06/2022 PERMIT RESUBMITTAL

no.	date	b
-----	------	---

IFC Set 2 of 3
5/17/2024

PLAN TOWER B LVL 7

 
P2.2B.17



159 South Jackson St, Suite 600
Seattle, Washington 98104 USA
+1 206 624 5670 olsorkundig.com

Olson Kundig

Project: **Sommet Blanc - Bldg AB**
DEER VALLEY, UTAH

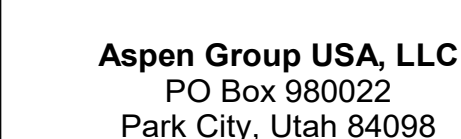

Pool Consultant
Cloward H20
2896 N University Ave, Suite 290
Provo, UT 84604

Landscape Architect
EPG Design
6949 South High Tech Drive, Suite 100
Midvale, Utah 84047

Specifications Writer
Friday Group
88 Mainelli Road
Middlebury, VT

Code Consultant
Holmes
600 1st Avenue, Suite 200A
Seattle, WA 98104

Fire Protection Engineer
Jensen Hughes
One Research Drive, Suite 305C
Westborough, MA 01581

Vertical Transportation Consultant
Lerch Bates
19515 North Creek Parkway, Suite 304
Bothell, WA 98011

Structural Engineer
Magnusson Klemencic Associates
1301 5th Ave, Suite 3200
Seattle, WA 98101

Lighting Designer
O-
1319 SE MLK Blvd, Suite 210
Portland, Oregon 97219

Building Envelope Consultant
RDH
2101 N 34th St
Seattle, WA 98103

Accessibility Consultant
Studio Pacifica
2144 Westlake Ave N, Suite F
Seattle, WA 98109

MFP Engineer
WSP USA
1001 Fourth Ave., Suite 3100
Seattle, WA 98154

principal architect _____
project manager _____
drawn by _____
checked by GM
job no. 2021-0696
date 5/17/2024

revisions:

1 10/06/2022 PERMIT RESUBMITTAL

no.	date	by
-----	------	----

 
IFC Set 2 of 3
5/17/2024

PLAN - TOWER B - ROOF

P2.2B.R


1 PLAN - TOWER B - ROOF
SCALE: 1/8" = 1'-0"

SCALE: 1/8" = 1'-0"






Olson Kundig


Project: **Sommet Blanc - Bldg AB**
DEER VALLEY, UTAH

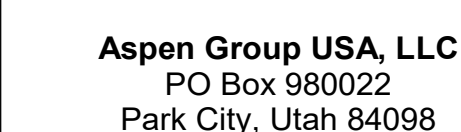

1	10/05/2022	PERMIT RESUBMITTAL
no.	date	by

 
P2.2BC.11

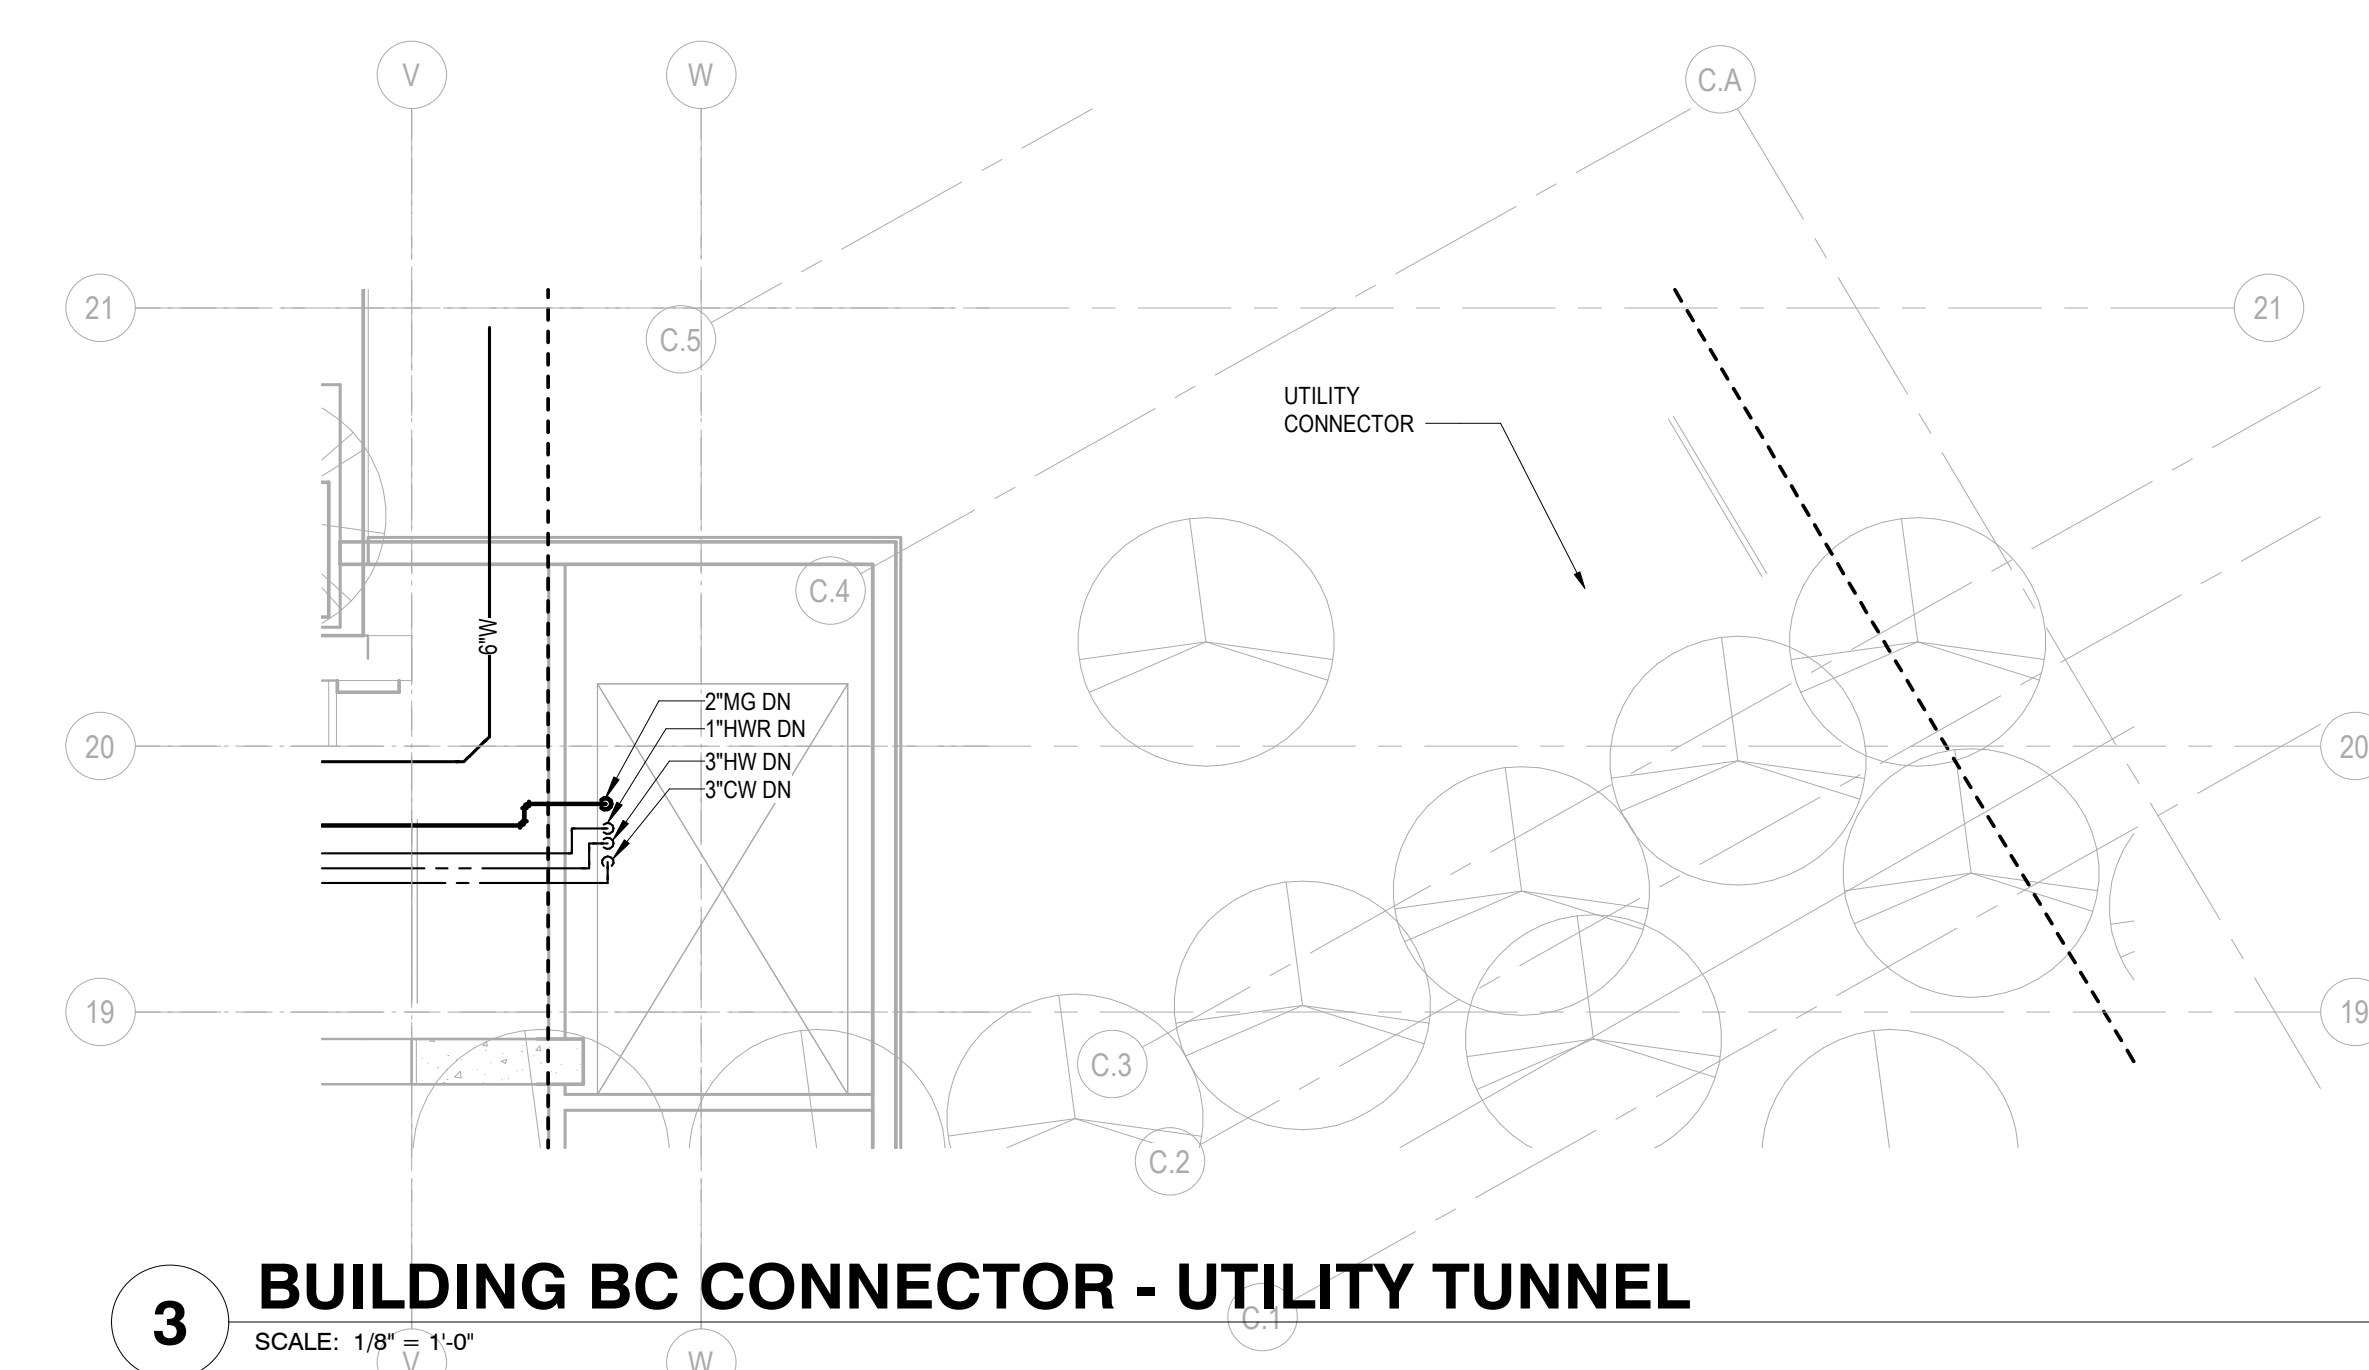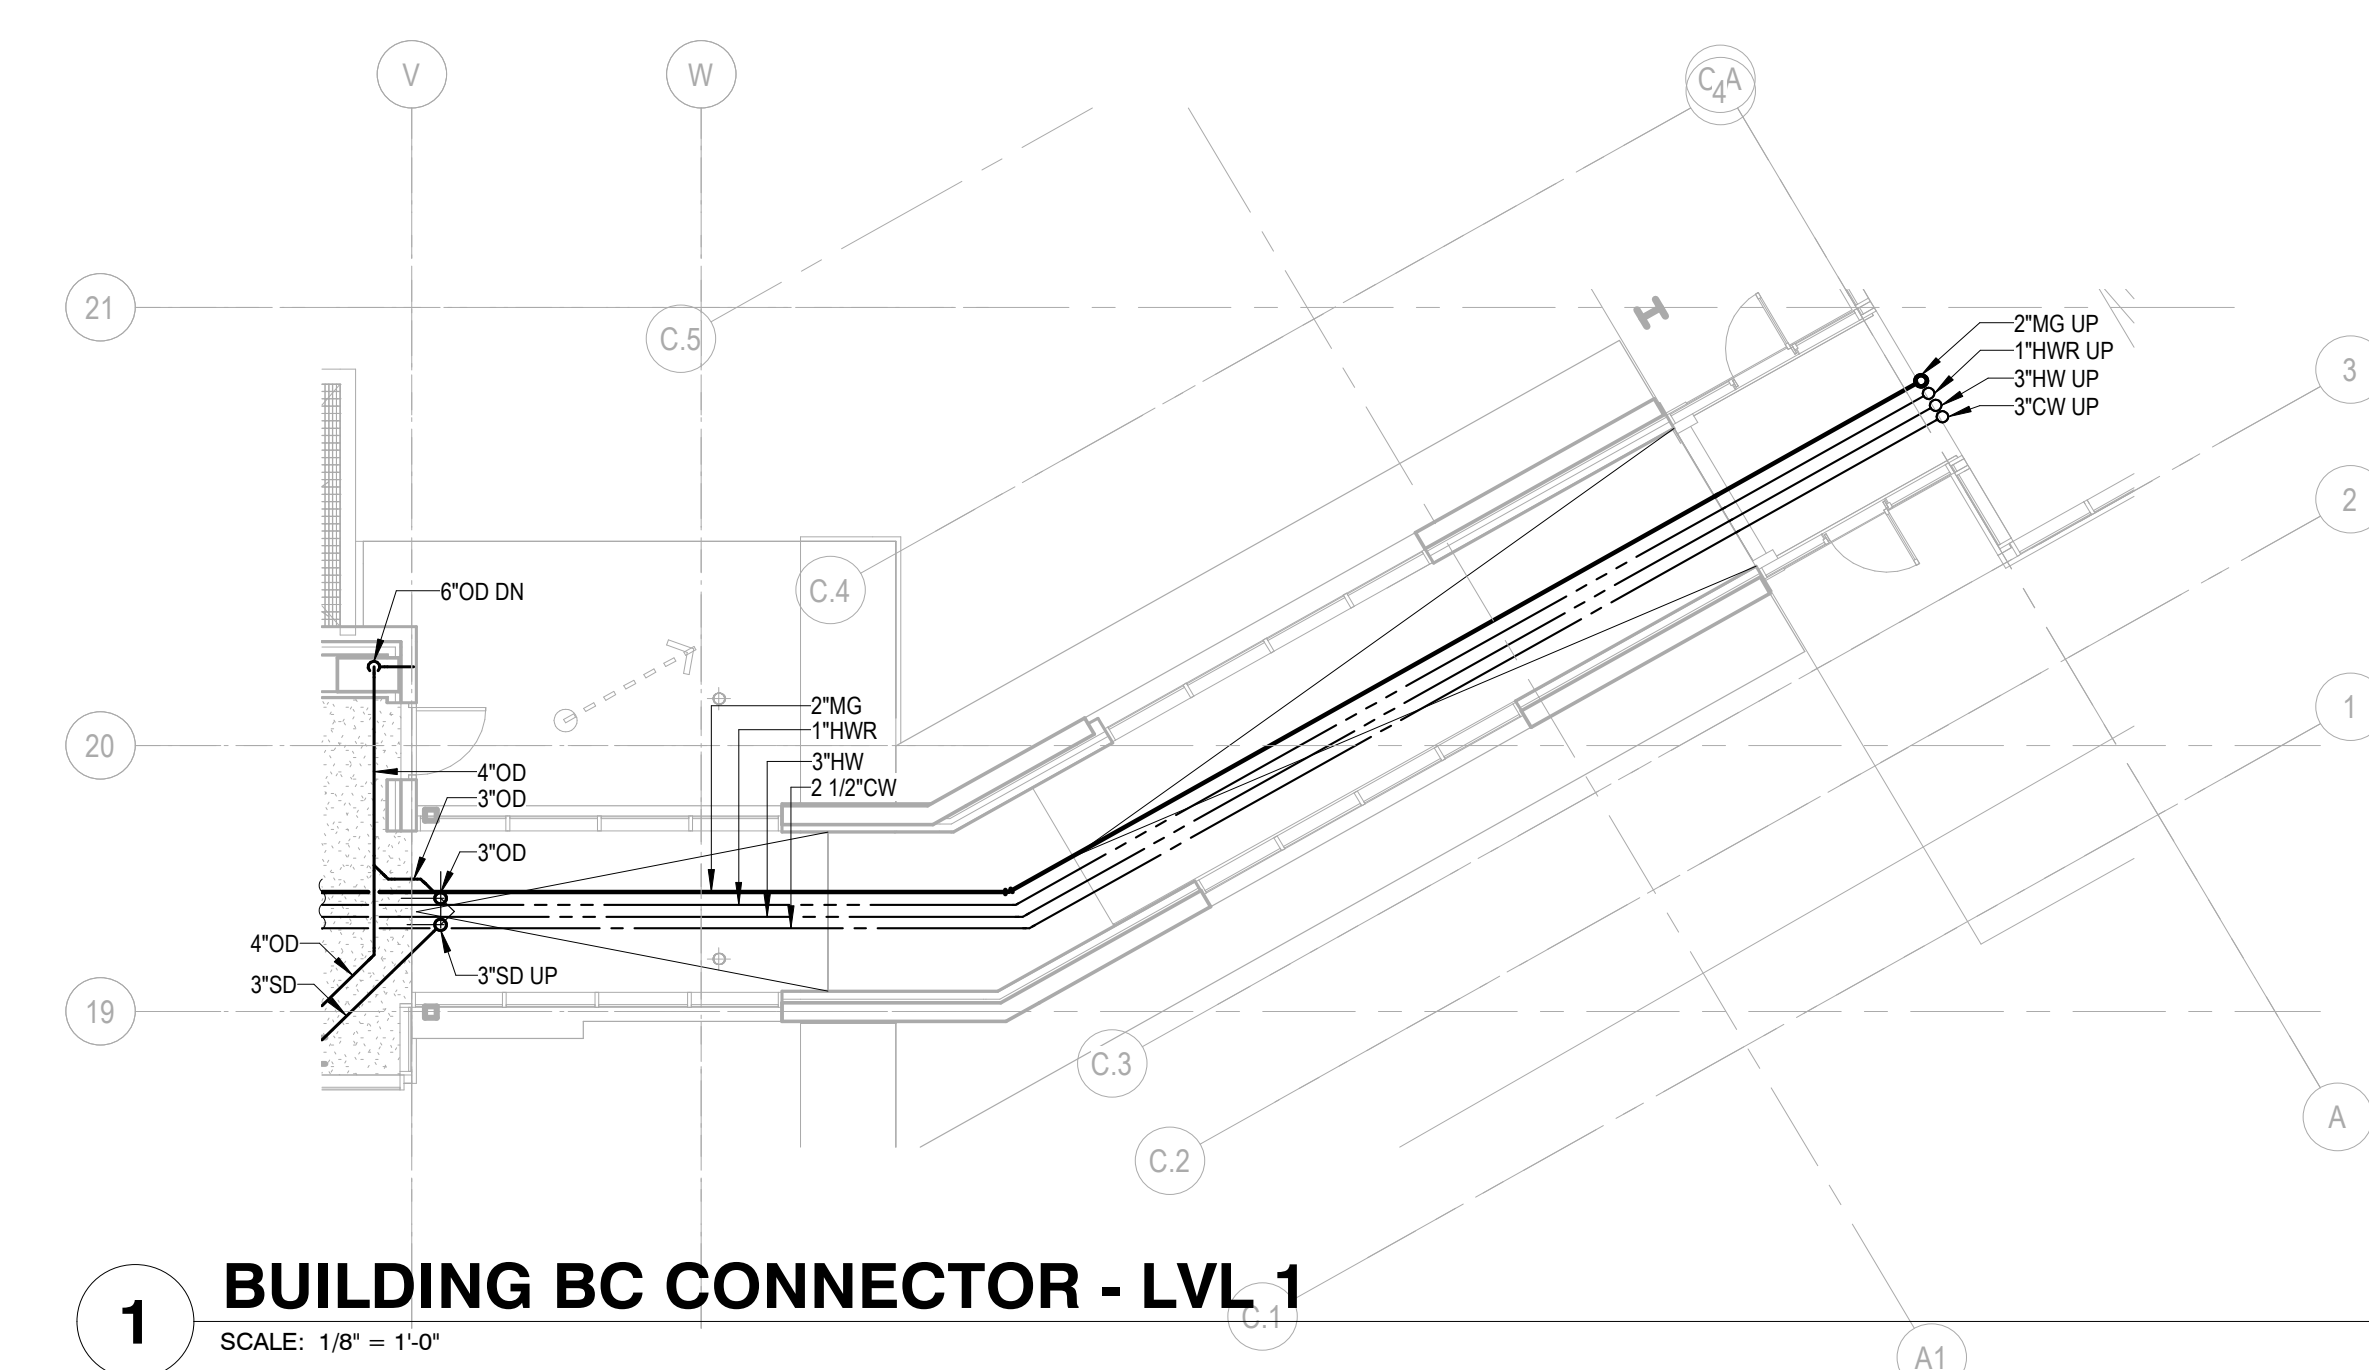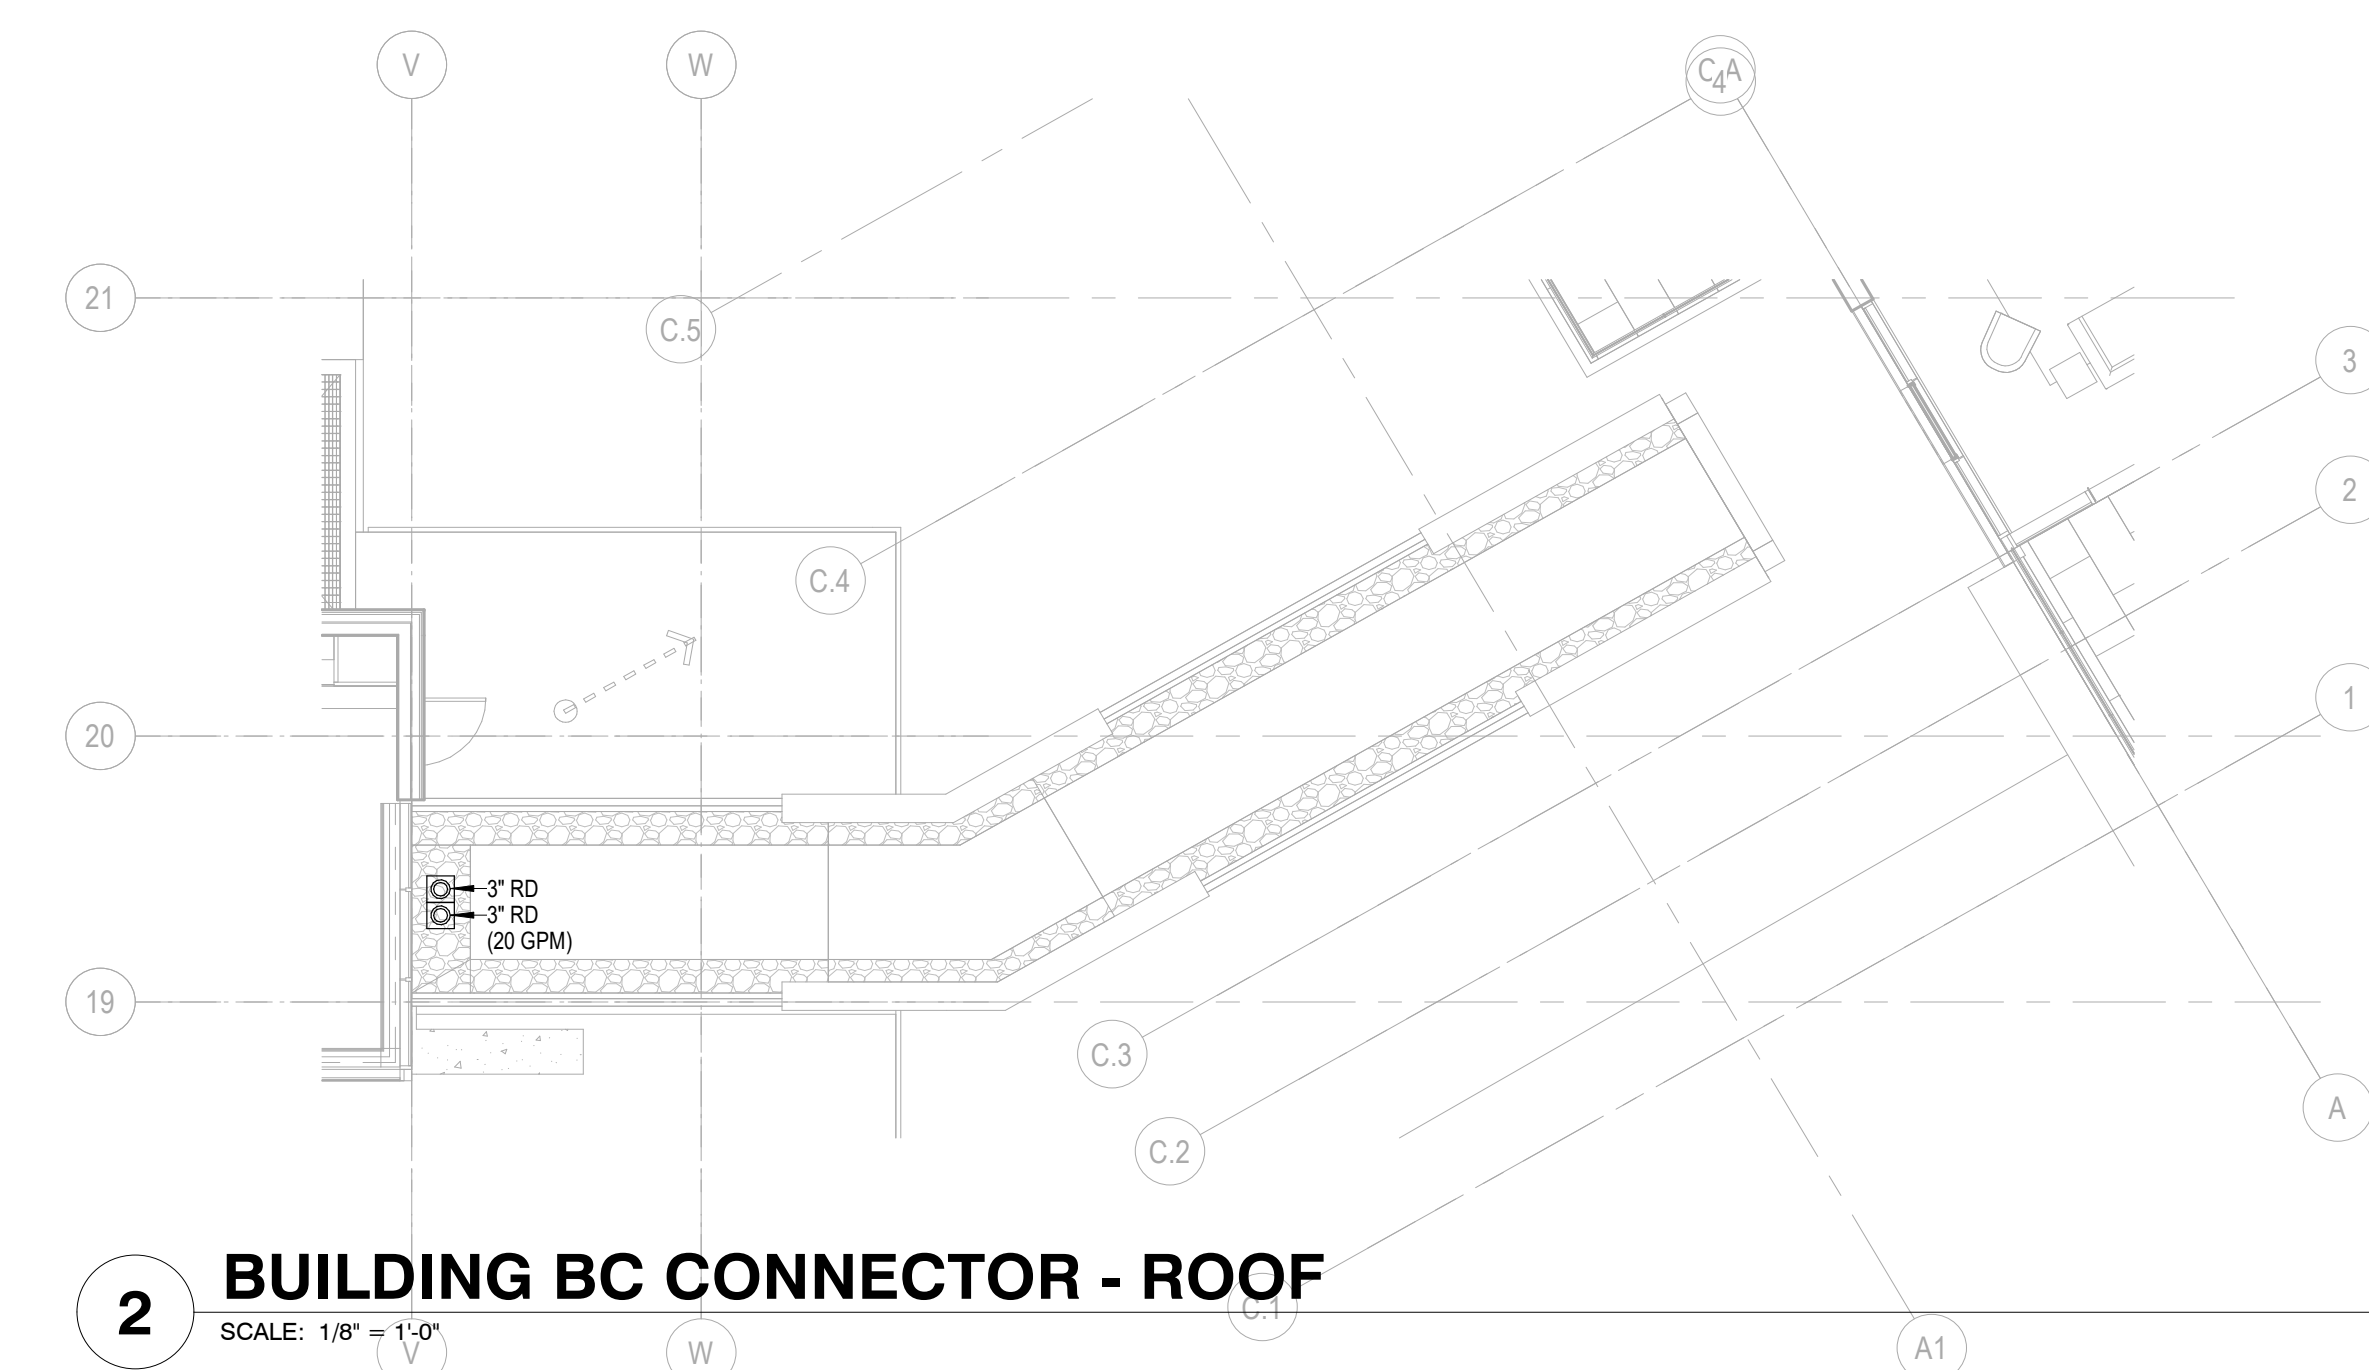



Olson Kundig

Project: **Sommet Blanc -C**
DEER VALLEY, UTAH

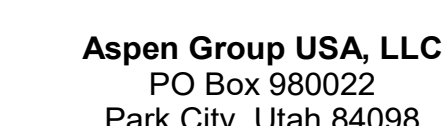

principal architect _____
project manager _____
drawn by _____
checked by GM
job no. 2021-0595
date 5/31/2024


[illegible]

no.	date	b
-----	------	---


IFC Set 3 of 3
5/31/2024

PLAN - TOWER C - LVL
P1

P2.2C.01

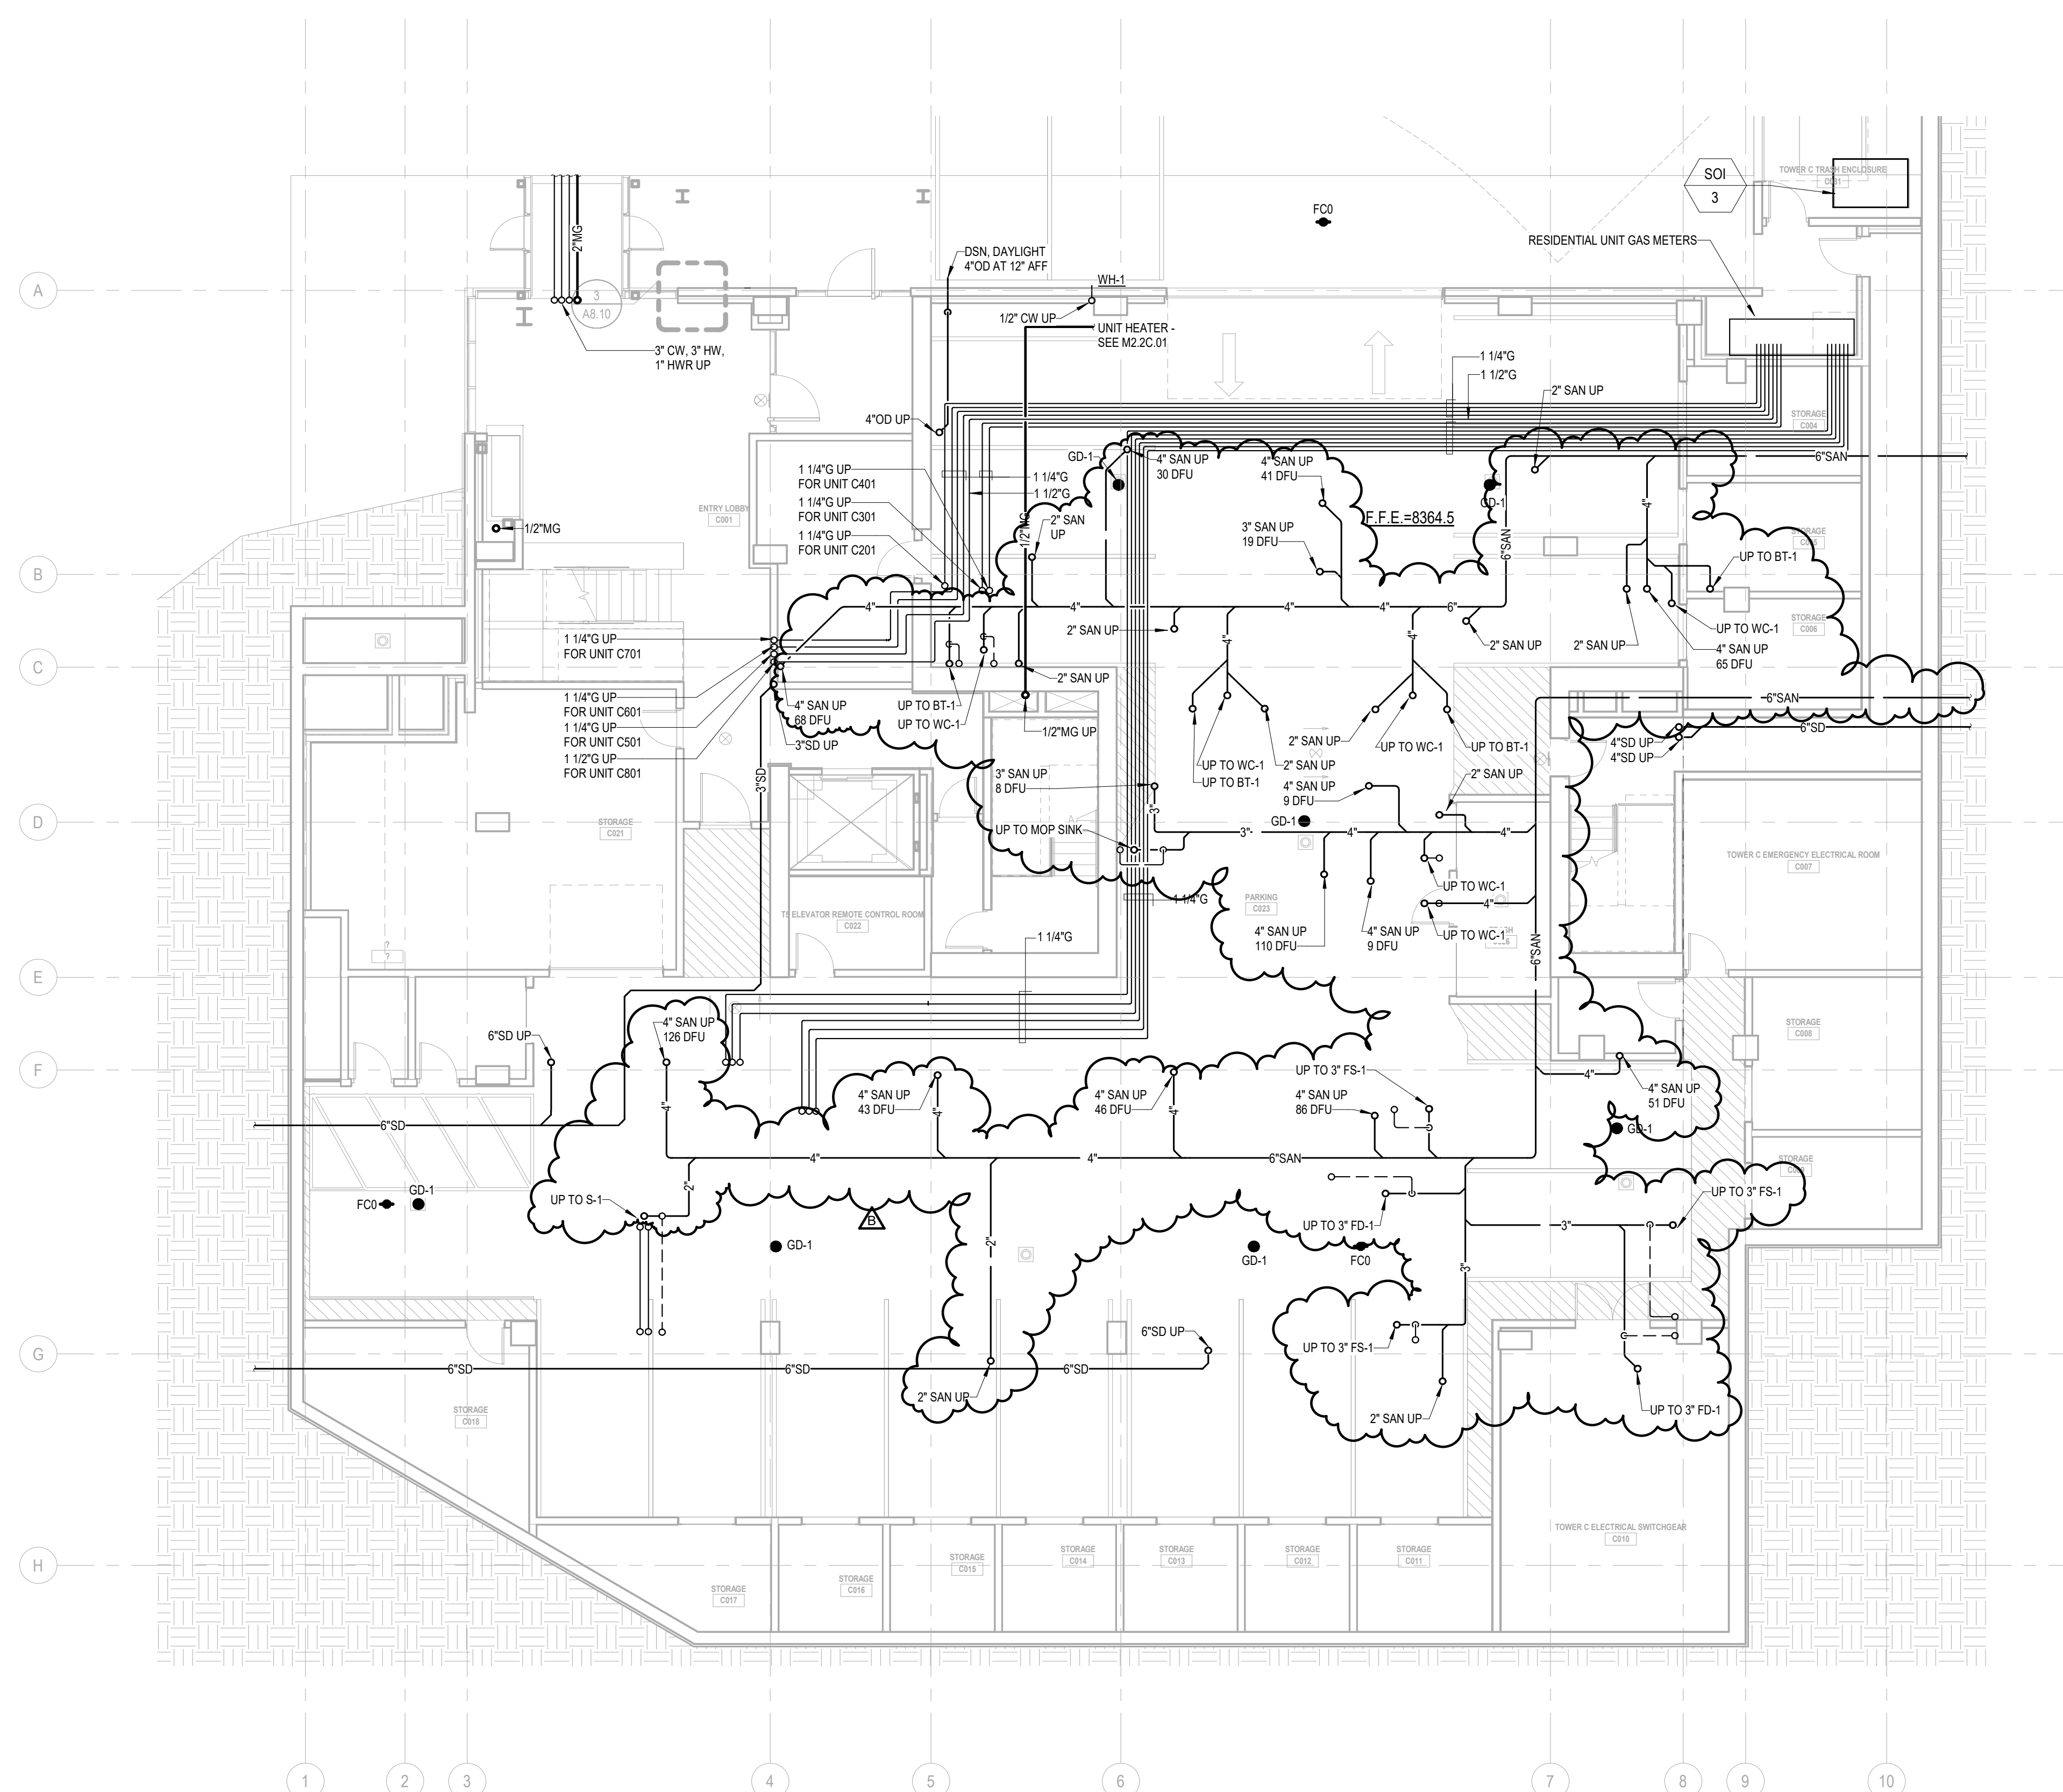

 
1 PLAN - TOWER C - LVL P1
SCALE: 1/8" = 1'-0"



159 South Jackson St, Suite 600
Seattle, Washington 98104 USA
+1 206 624 5670 disorkundg.com

Olson Kundig

Project: **Sommet Blanc - C**
DEER VALLEY, UTAH

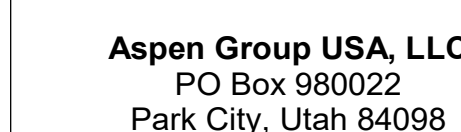

Pool Consultant
Cloward H20
2896 N University Ave, Suite 290
Provo, UT 84604

Landscape Architect
EPG Design
6949 South High Tech Drive, Suite 100
Midvale, Utah 84047

Specifications Write
Friday Group
88 Mainelli Road
Middlebury, VT

Code Consultant
Holmes
600 1st Avenue, Suite 200
Seattle, WA 98104

Fire Protection Engineer
Jensen Hughes
One Research Drive, Suite 305C
Westborough, MA 01581

Vertical Transportation Consultant
Lerch Bates
19515 North Creek Parkway, Suite 304
Bothell, WA 98011

Structural Engineer
Magnusson Klemencic Associates
1301 5th Ave, Suite 3200
Seattle, WA 98101

Lighting Designer
O-
1319 SE MLK Blvd, Suite 210
Portland, Oregon 97219

Building Envelope Consultants
RDH
2101 N 34th St
Seattle, WA 98103

Accessibility Consultant
Studio Pacifica
2144 Westlake Ave N, Suite F
Seattle, WA 98109

MFP Engineer
WSP USA
1001 Fourth Ave., Suite 3100
Seattle, WA 98154

principal architect _____
project manager _____
drawn by _____
checked by _____ Checker _____
job no. 2021-0595
date 5/17/2024


revisions:

no.	date
-----	------

IFC Set 2 of 3
5/17/2024

PLAN - TOWER C -LVL
P1U

P2.2C.01U

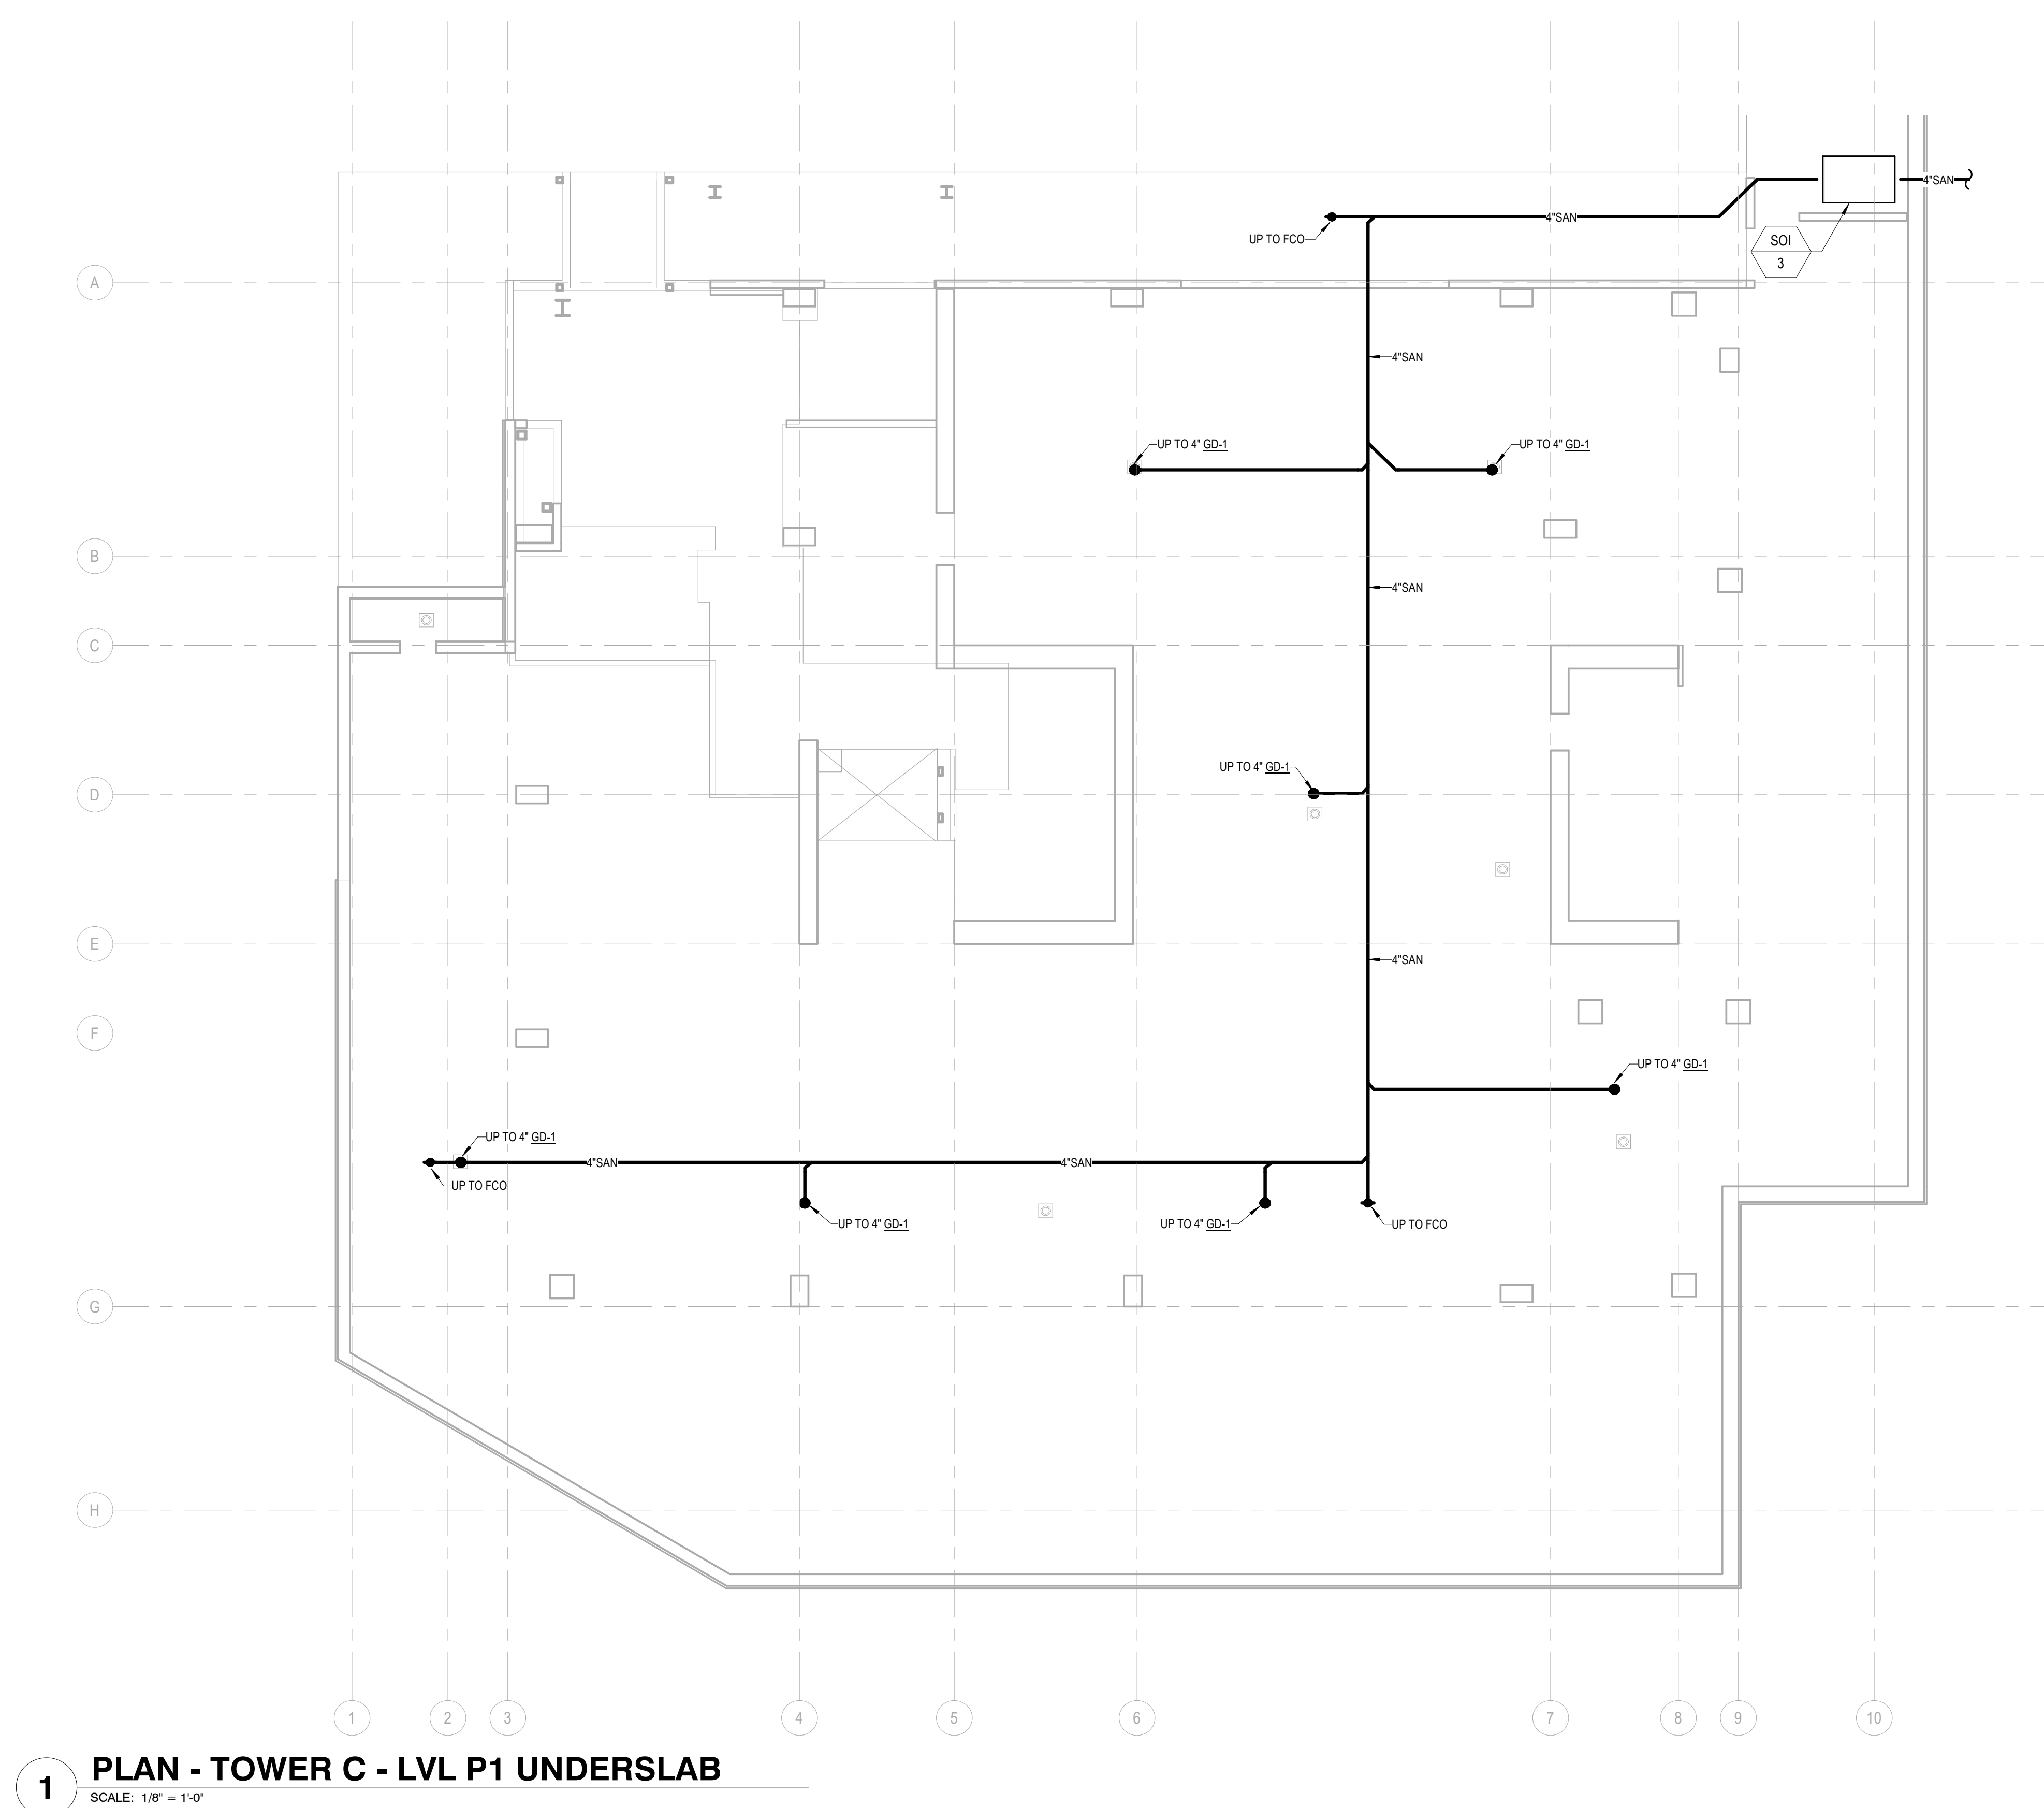

1 PLAN - TOWER C - LVL P1 UNDERSLAB
SCALE: 1/8" = 1'-0"




-

159 South Jackson St, Suite 600
Seattle, Washington 98104 USA
+1 206 624 5670 clerk@kundig.com

Olson Kundig

project:
Sommet Blanc -C
DEER VALLEY, UTAH

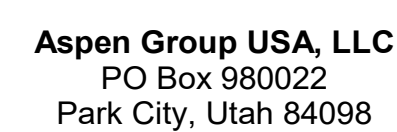

Pool Consultant
Cloward H2O
2896 N University Ave, Suite 290
Provo, UT 84604

Landscape Architect
EPG Design
6949 South High Tech Drive, Suite 100
Midvale, Utah 84047

Specifications Writer
Friday Group
88 Mainelli Road
Middlebury, VT

Code Consultant
Holmes
600 1st Avenue, Suite 200A
Seattle, WA 98104

Fire Protection Engineer
Jensen Hughes
One Research Drive, Suite 305C
Westborough, MA 01581

Vertical Transportation Consultant
Lorch Bates
19515 North Creek Parkway, Suite 304
Bothell, WA 98011

Structural Engineer
Magnusson Klemencic Associates
1301 5th Ave, Suite 3200
Seattle, WA 98101

Lighting Designer
O-
1319 SE MLK Blvd, Suite 210
Portland, Oregon 97219

Building Envelope Consultants
RDH
2101 N 34th St
Seattle, WA 98103

Accessibility Consultant
Studio Pacifica
2144 Westlake Ave N, Suite F
Seattle, WA 98109

MEP Engineer
WSP USA
1001 Fourth Ave., Suite 3100
Seattle, WA 98154

principal architect _____
project manager _____
drawn by _____
checked by GM _____
job no. 2021-0696
date 5/31/2024


revisions:

no.	date	
-----	------	--

IFC Set 3 of 3
5/31/2024


PLAN - TOWER C - LVL 1

 P2.2C.11



Olson Kundig

Project: **Sommet Blanc -C**
DEER VALLEY, UTAH

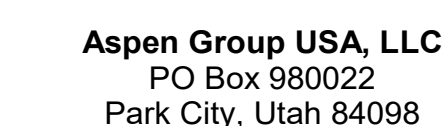

MEP Engineer
WSP USA
1001 Fourth Ave., Suite 3100
Seattle, WA 98154

principal architect _____
project manager _____
drawn by _____
checked by GM _____
job no. 2021-0596
date 5/17/2024


revisions:

no.	date	b
-----	------	---

IFC Set 2 of 3
5/17/2024

PLAN - TOWER C - LVL 2


P2.2C.12

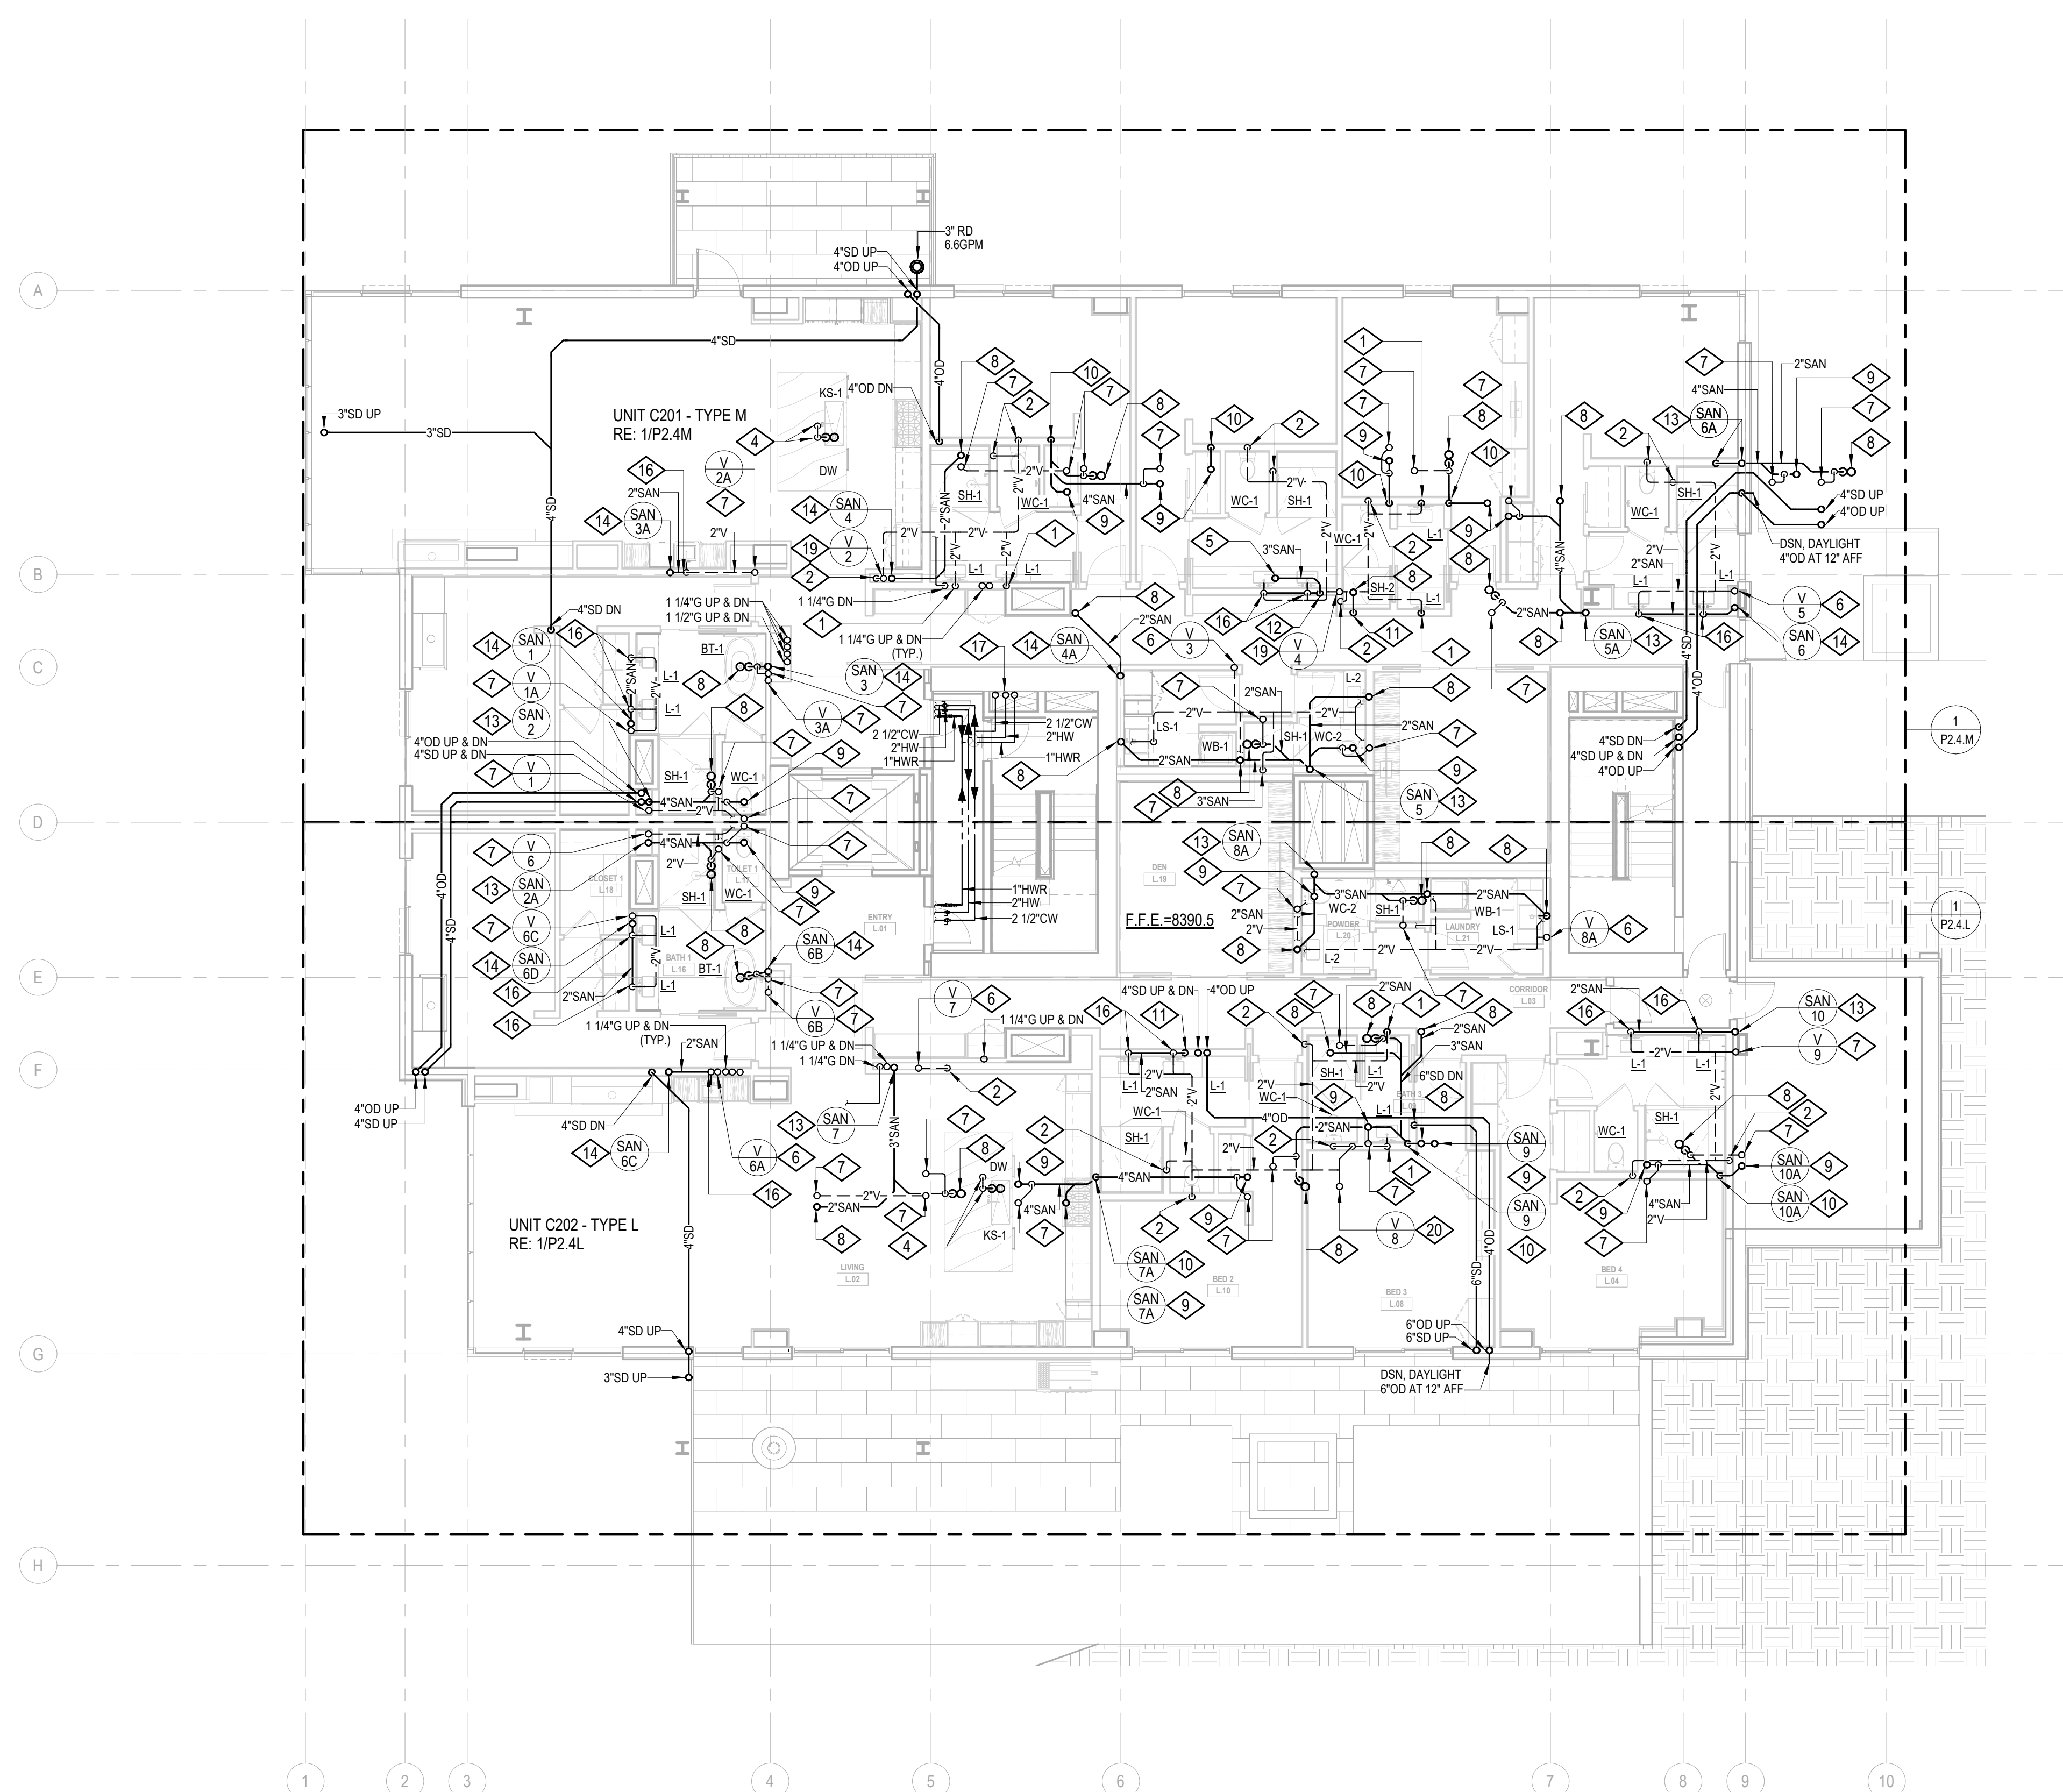

1 PLAN - TOWER C - LVL 2
SCALE: 1/8" = 1'-0"


- KEYNOTES:**

  - 1 2" SAN DN & 2" V RISE
 - 2 2" V DN
 - 3 3" V UP & DN
 - 4 2" SAN & 2" V DN
 - 5 3" SAN UP
 - 6 2" V UP & DN
 - 7 2" V UP
 - 8 2" SAN UP
 - 9 4" SAN UP
 - 10 4" SAN DN
 - 11 2" SAN DN
 - 12 3" SAN DN
 - 13 4" SAN UP & DN
 - 14 2" SAN UP & DN
 - 15 4" V UP & DN
 - 16 2" V RISE
 - 17 2" CW, 2" HW, 1" HWR UP
 - 18 2" HW, 2" HW, 1" HWR DN
 - 19 2" V DN, 3" V UP
 - 20 3" V UP



Olson Kundig

project:
Sommet Blanc -C
DEER VALLEY, UTAH

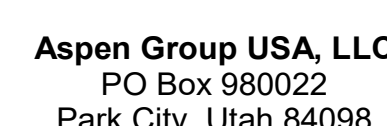

MEP Engineer
WSP USA
1001 Fourth Ave., Suite 3100
Seattle, WA 98154

principal architect _____
project manager _____
drawn by _____
checked by GM _____
job no. 2021-0595
date 5/17/2024


revisions:

no.	date	b
-----	------	---

IFC Set 2 of 3
5/17/2024

PLAN - TOWER C - I VI 3

P2.2C.13

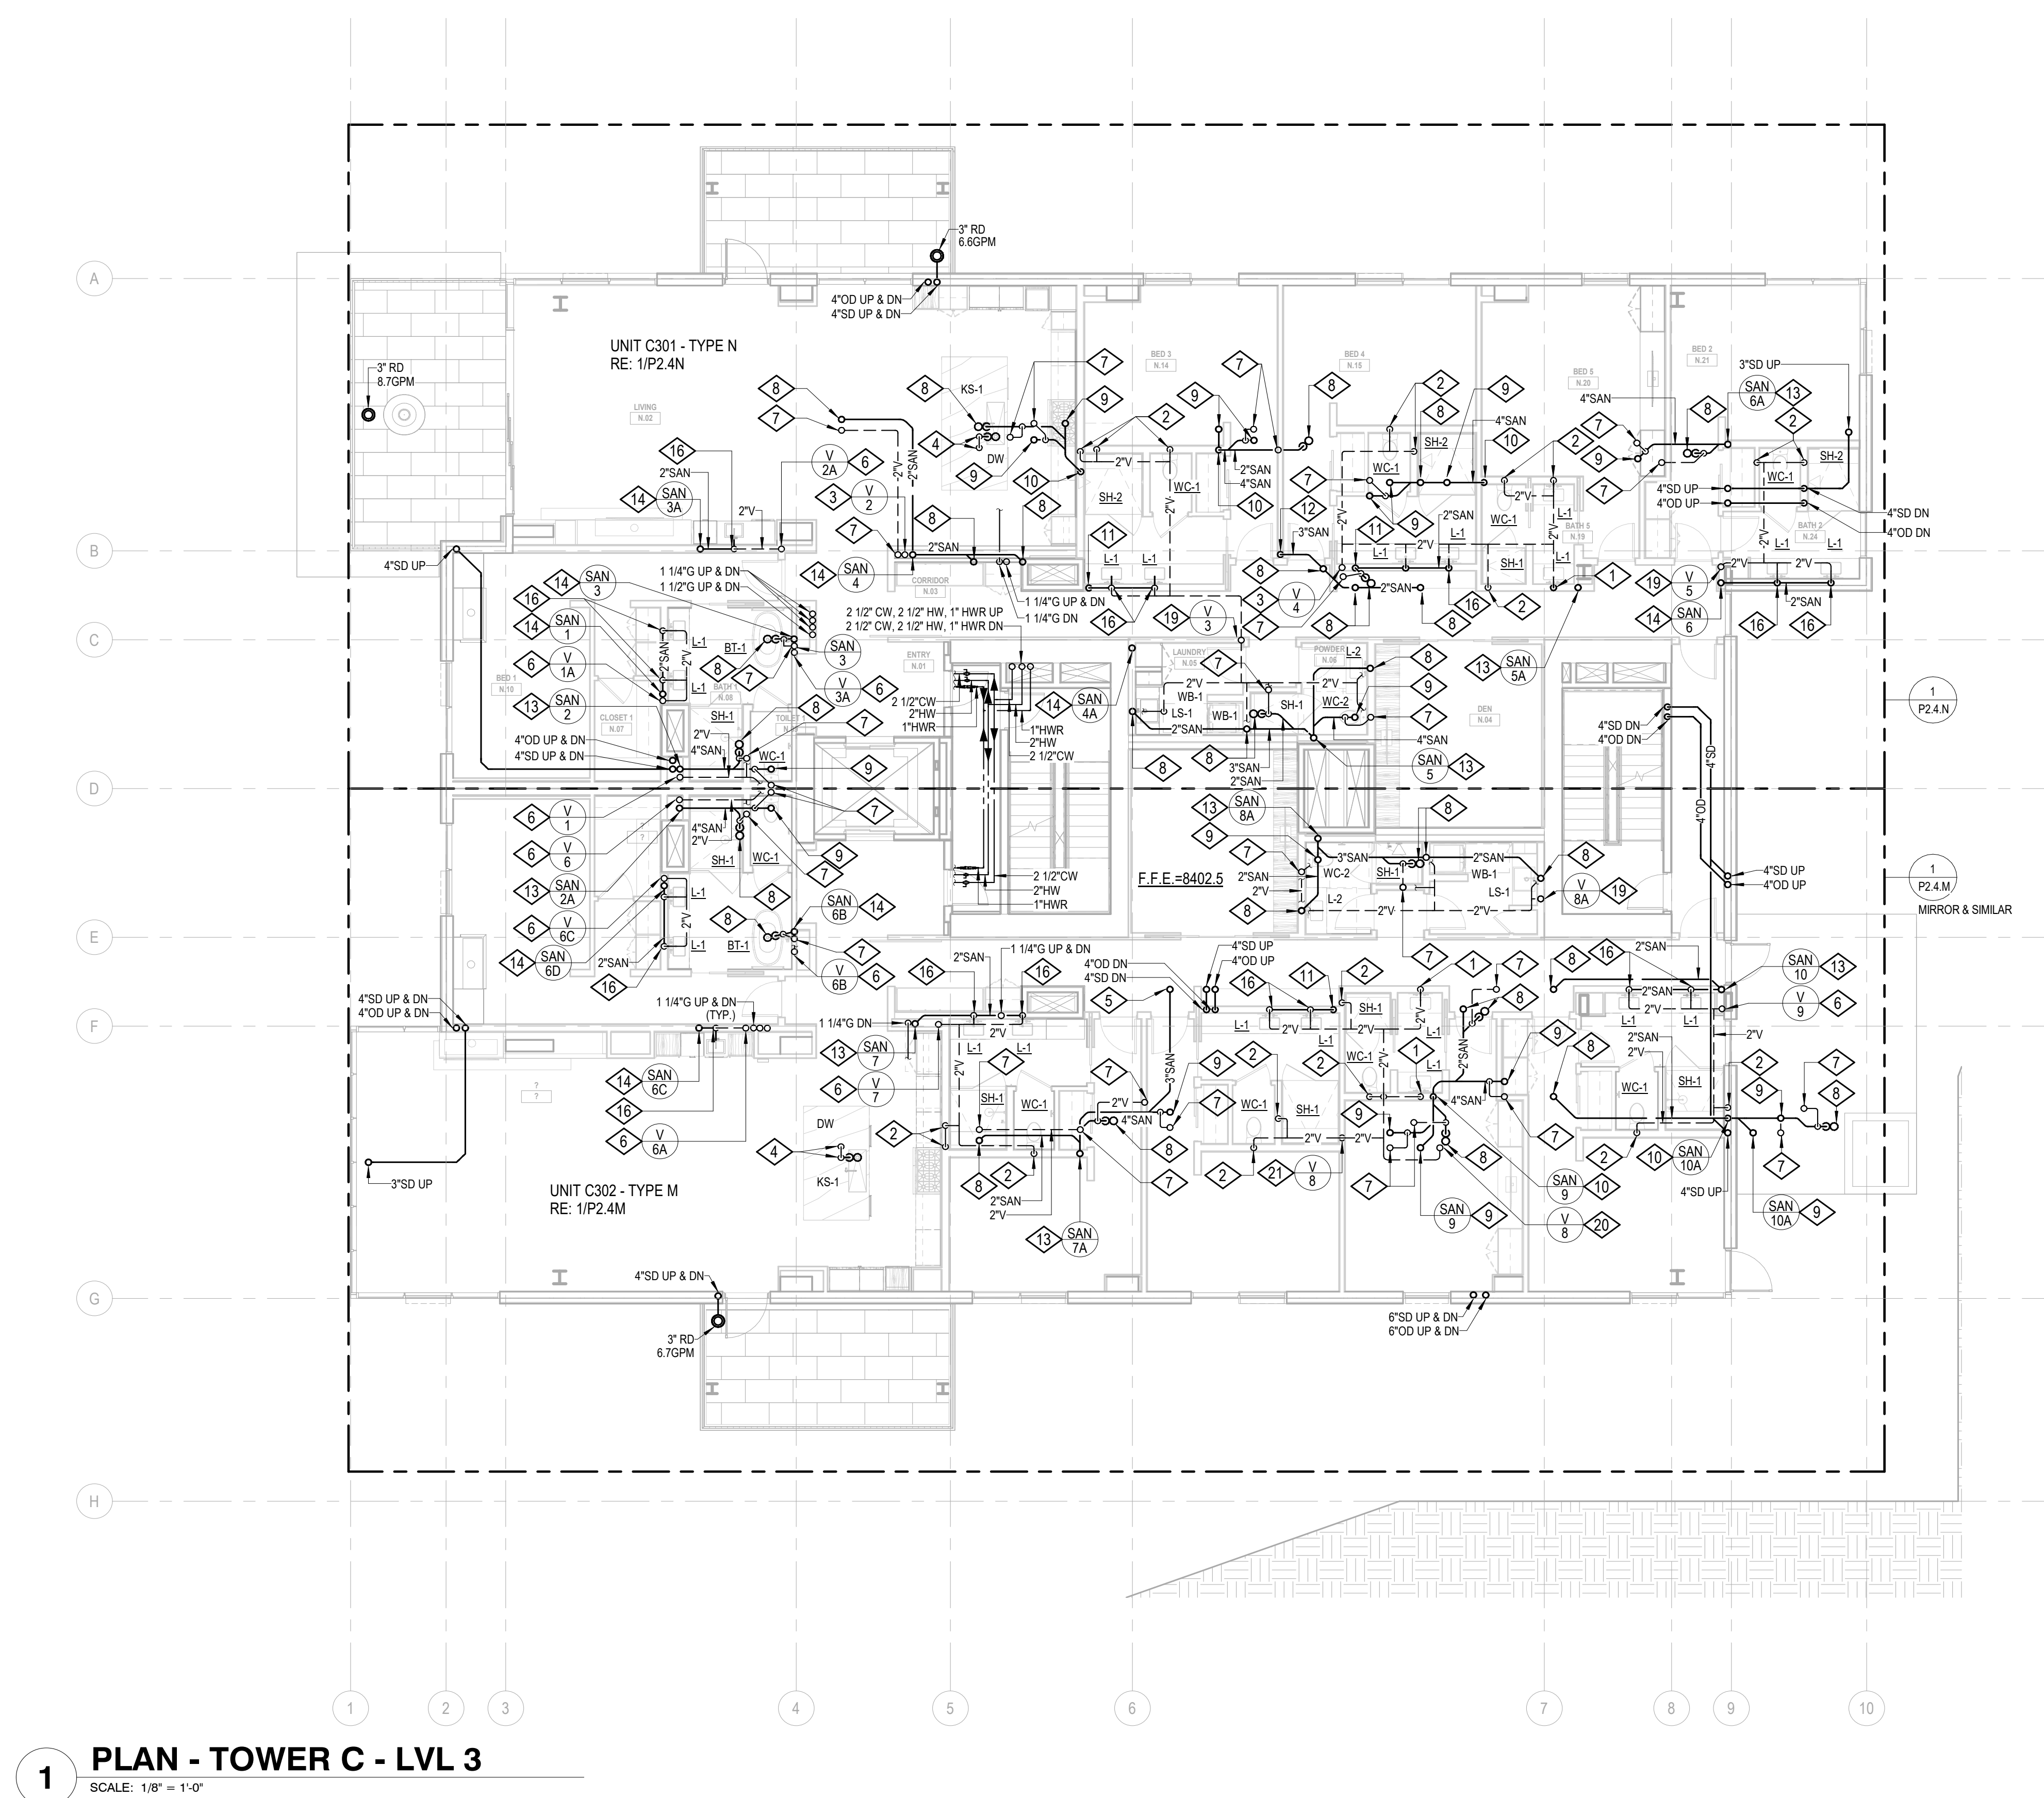

1 PLAN - TOWER C - LVL 3
SCALE: 1/8" = 1'-0"


SCALE: 1/8" = 1'-0"

KEYNOTES

1	2° SAN DN & 2° V RISE
2	2° V DN
3	3° V UP & DN
4	2° SAN & 2° V DN
5	3° SAN UP
6	2° V UP & DN
7	2° V UP
8	2° SAN UP
9	4° SAN UP
10	4° SAN DN
11	2° SAN DN
12	3° SAN DN
13	4° SAN UP & DN
14	3° SAN UP & DN
15	4° V UP & DN
16	2° V RISE
17	4° V UP
18	4° V DN
19	2° V DN & 3° V UP
20	3° V UP
21	3° V DN




 - P2.2C.14



Olson Kundig

project:
Sommet Blanc -C
DEER VALLEY, UTAH

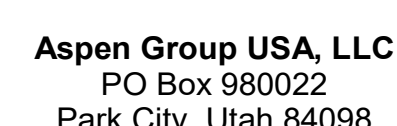

MEP Engineer
WSP USA
1001 Fourth Ave., Suite 3100
Seattle, WA 98154

principal architect _____
project manager _____
drawn by _____
checked by GM
job no. 2021-0596
date 5/17/2024


revisions:

no.	date	b
-----	------	---

IFC Set 2 of 3
5/17/2024


PLAN - TOWER C - LVL 5

P2.2C.15

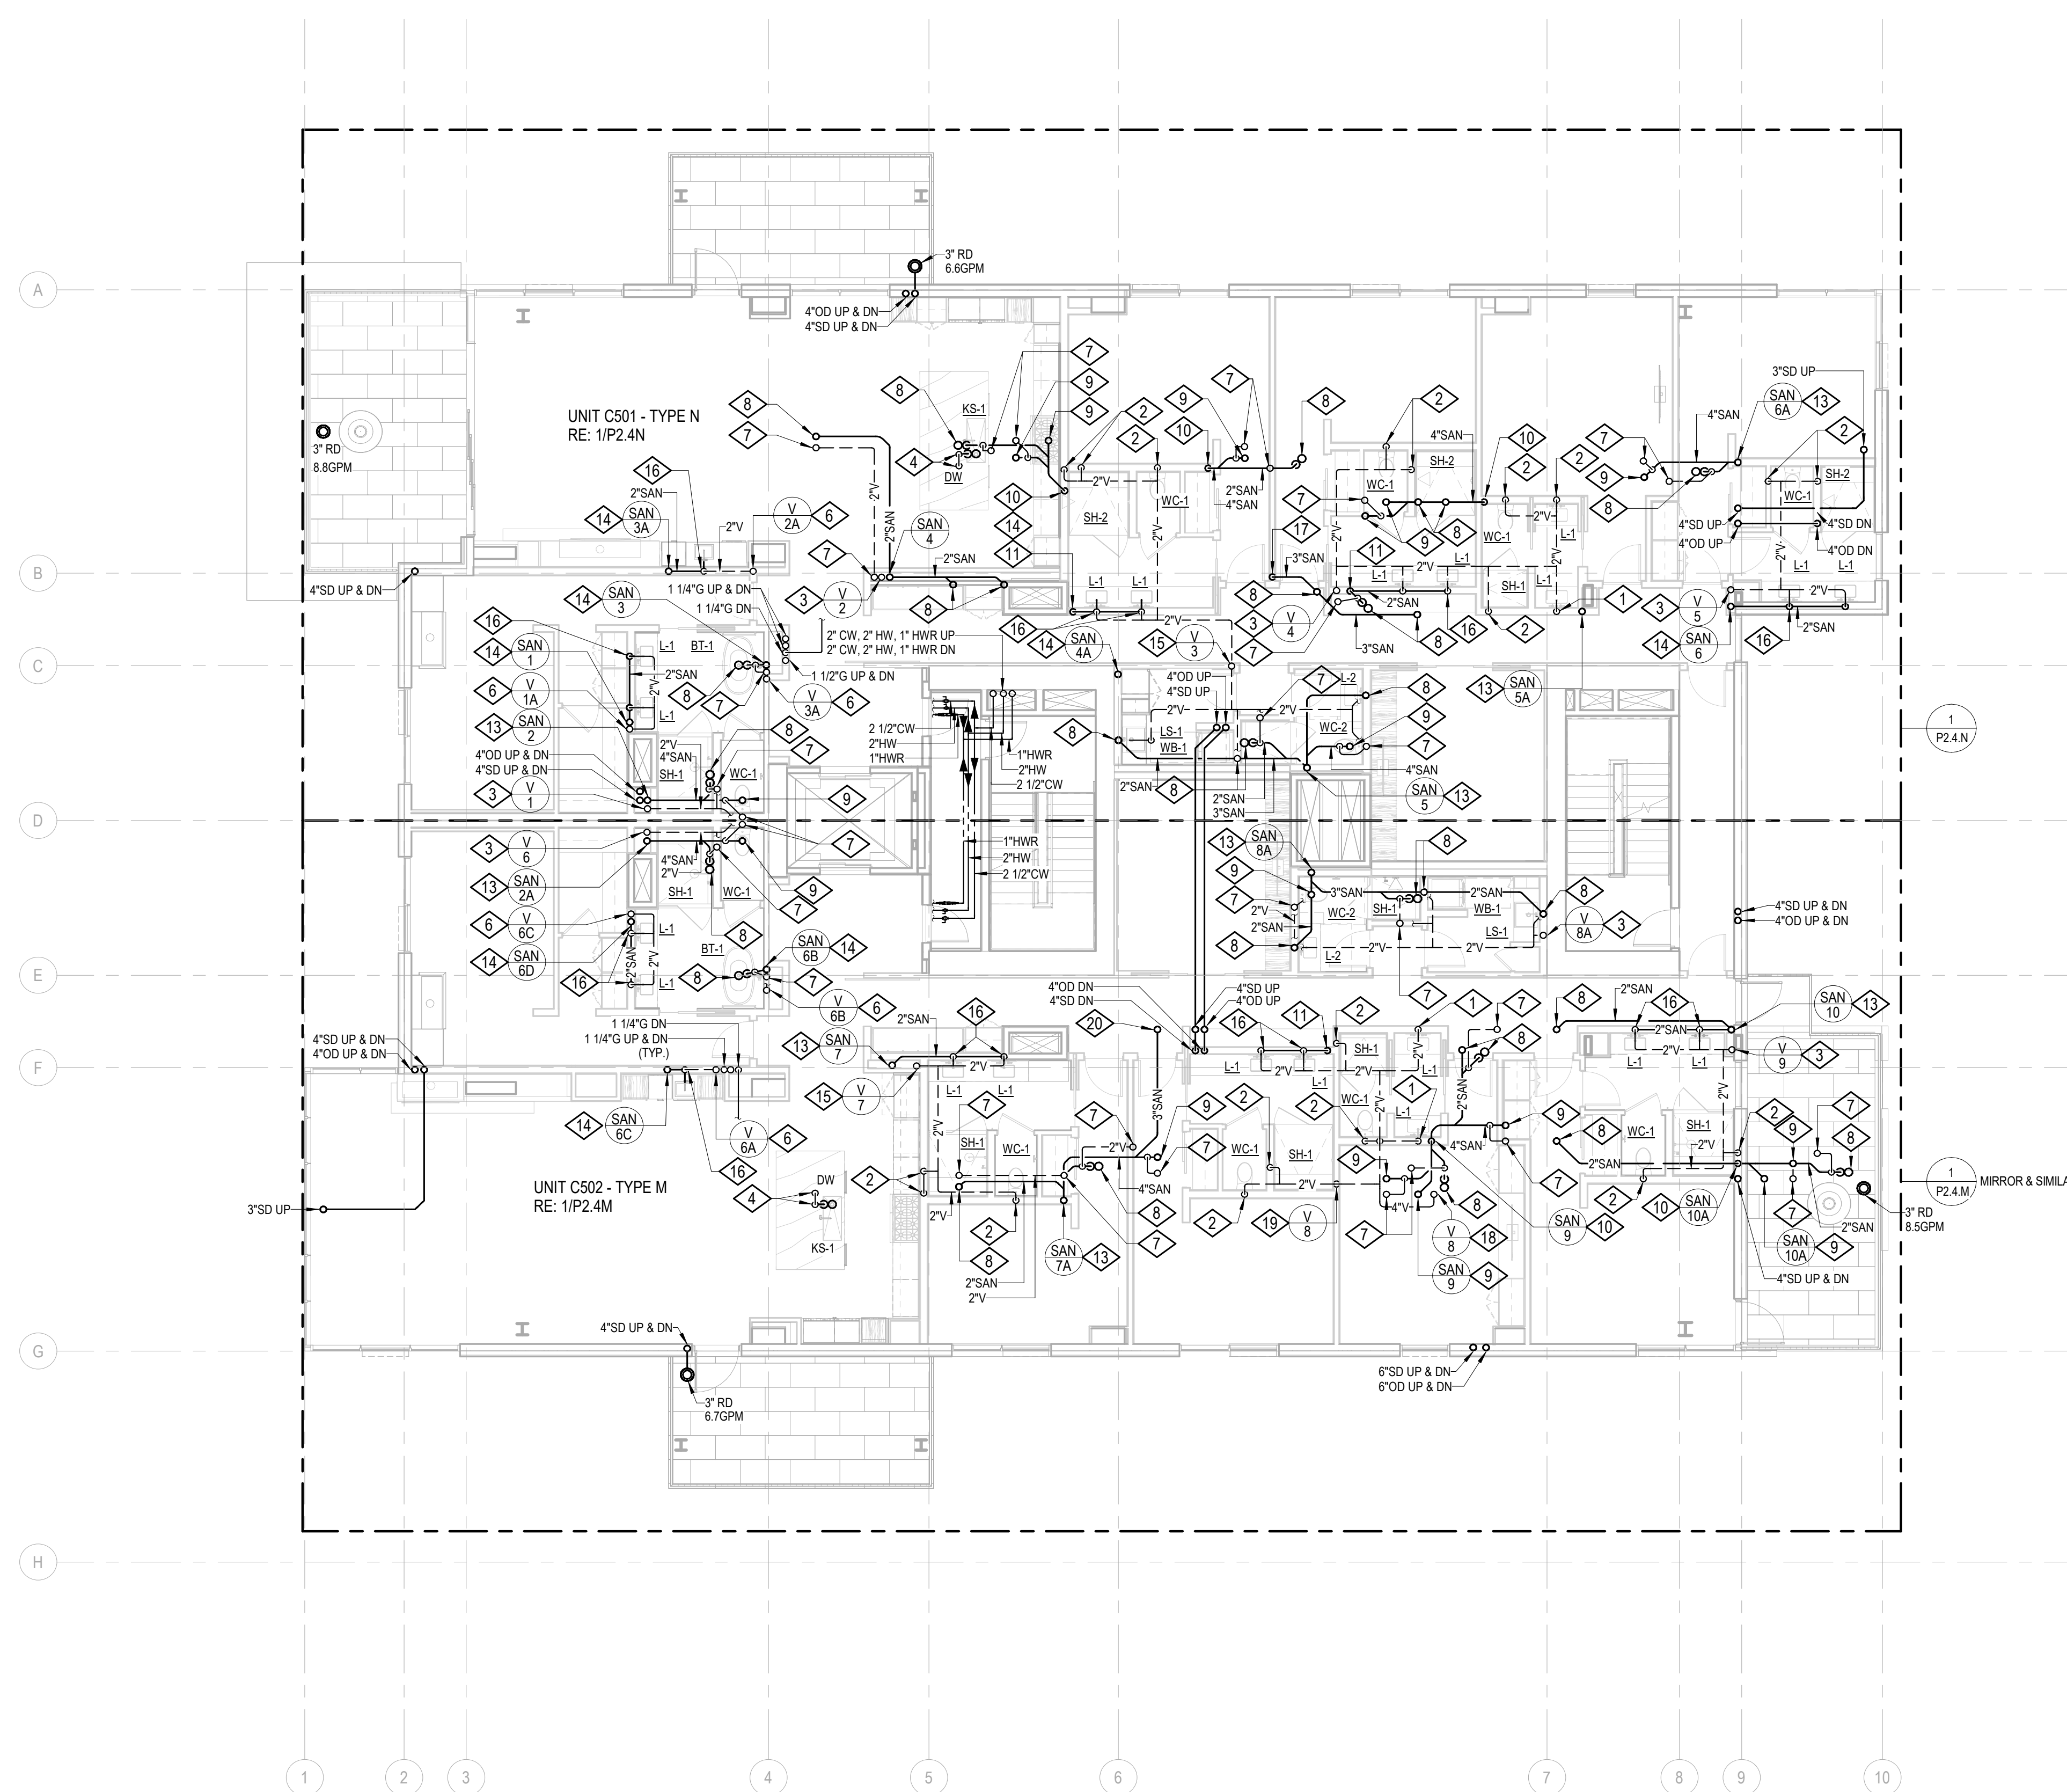

1 PLAN - TOWER C - LVL 5
SCALE: 1/8" = 1'-0"


- KEYNOTES:**
- | | |
|----|-----------------------|
| 1 | 2" SAN DN & 2" V RISE |
| 2 | 2" V DN |
| 3 | 3" V UP & DN |
| 4 | 2" SAN & 2" V DN |
| 5 | 2" SAN & 2" V UP |
| 6 | 2" V UP & DN |
| 7 | 2" V UP |
| 8 | 2" SAN UP |
| 9 | 4" SAN UP |
| 10 | 4" SAN DN |
| 11 | 2" SAN DN |
| 12 | 2" SAN UP & DN |
| 13 | 4" SAN UP & DN |
| 14 | 3" SAN UP & DN |
| 15 | 4" V UP & DN |
| 16 | 2" V RISE |
| 17 | 3" SAN DN |
| 18 | 4" V UP |
| 19 | 4" V DN |
| 20 | 3" SAN UP |

 

159 South Jackson St, Suite 600
Seattle, Washington 98104 USA
+1 206 624 5670 dsorkundig.com

Olson Kundig

Project: **Sommet Blanc - C**
DEER VALLEY, UTAH

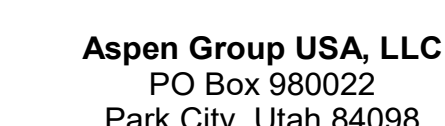

Pool Consultant
Cloward H2O
2896 N University Ave, Suite 290
Provo, UT 84604

Landscape Architect
EPG Design
6949 South High Tech Drive, Suite 101
Midvale, Utah 84047

Specifications Writer
Friday Group
88 Mainelli Road
Middletown, CT

Code Consultant
Holmes
600 1st Avenue, Suite 200A
Seattle, WA 98104

Fire Protection Engineer
Jensen Hughes
One Research Drive, Suite 305
Westborough, MA 01581

Vertical Transportation Consultant
Lerch Bates
19515 North Creek Parkway, Suite 3
Bethell, WA 98044

Structural Engineer
Magnusson Klemencic Associates
1301 5th Ave, Suite 3200
Seattle, WA 98101

Lighting Designer
O-
1319 SE MLK Blvd, Suite 210
Portland, Oregon 97219

Building Envelope Consultants
RDH
2101 N 34th St
Seattle, WA 98103

Accessibility Consultant
Studio Pacifica
2144 Westlake Ave N, Suite F
Seattle, WA 98109

MEP Engineer
WSP USA
1001 Fourth Ave., Suite 3100
Seattle, WA 98154

principal architect _____
project manager _____
drawn by _____
checked by GM _____
job no. 2021-0595
date 5/17/2024


revisions:

no.	date	b
-----	------	---

IFC Set 2 of 3
5/17/2024

PLAN - TOWER C - LVL 6


P2.2C.16

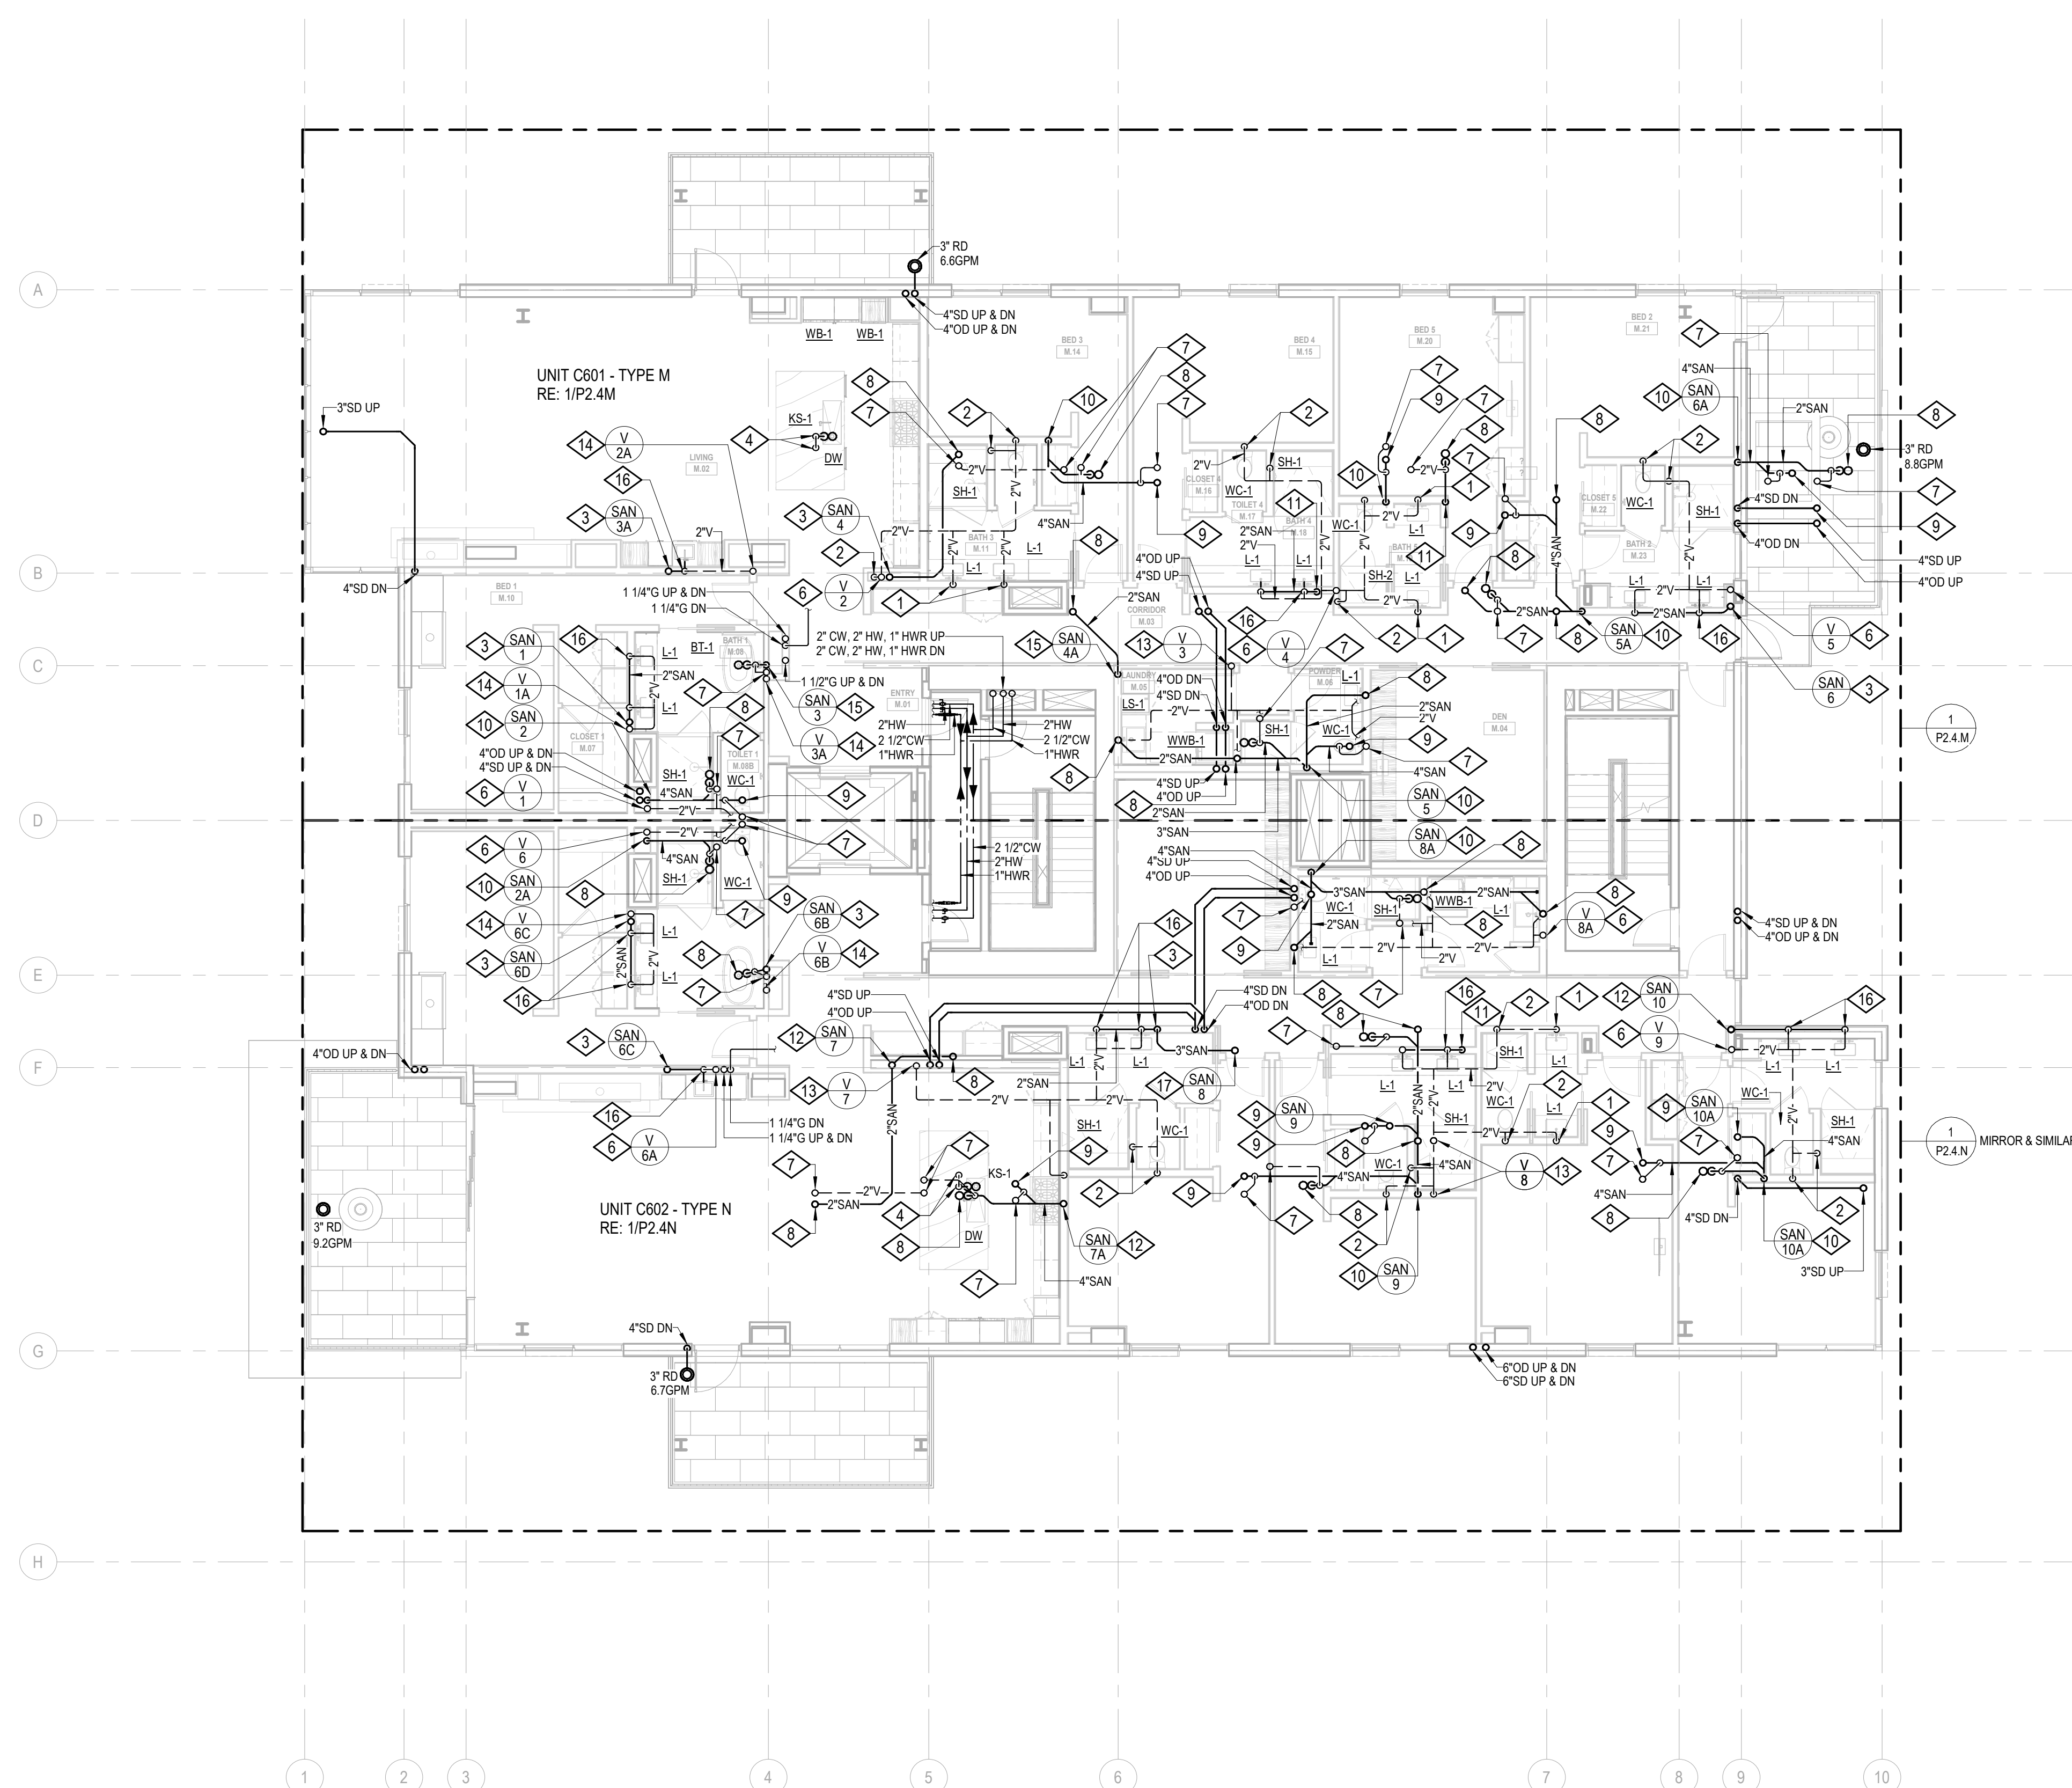

1 PLAN - TOWER C - LVL 6
SCALE: 1/8" = 1'-0"




 - P2.2C.17



Olson Kundia

Project: **Sommet Blanc -C**

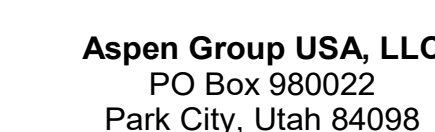


no. date

IFC Set 3 of 3
5/31/2024

PLAN - TOWER C - LVL 8

 
P2.2C.19



159 South Jackson St, Suite 600
Seattle, Washington 98104 USA
+1 206 624 5670 olsonkundig.com

Olson Kundig

project;
Sommet Blanc -C
DEER VALLEY, IUTAH

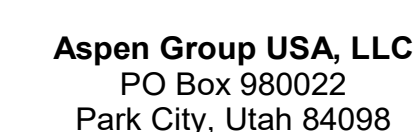

Pool Consultant
Cloward H20
2896 N University Ave, Suite 290
Provo, UT 84604

Landscape Architect
EPG Design
6949 South High Tech Drive, Suite 100
Midvale, Utah 84047

Specifications Writer
Friday Group
88 Mainelli Road
Middlebury, VT

Code Consultant
Holmes
600 1st Avenue, Suite 200
Seattle, WA 98104

Fire Protection Engineer
Jensen Hughes
One Research Drive, Suite 305C
Westborough, MA 01581

Vertical Transportation Consultant
Lerch Bates
19515 North Creek Parkway, Suite 304
Bothell, WA 98011

Structural Engineer
Magnusson Klemencic Associates
1301 5th Ave, Suite 3200
Seattle, WA 98101

Lighting Designer
O-
1319 SE MLK Blvd, Suite 210
Portland, Oregon 97219

Building Envelope Consultant
RDH
2101 N 34th St
Seattle, WA 98103

Accessibility Consultant
Studio Pacifica
2144 Westlake Ave N, Suite F
Seattle, WA 98109

MFP Engineer
WSP USA
1001 Fourth Ave., Suite 3100
Seattle, WA 98154

principal architect _____
project manager _____
drawn by _____
checked by GM
job no. 2021-0595
date 5/17/2024

revisions:

no.	date	by
-----	------	----

 
IFC Set 2 of 3
5/17/2024

PLAN - TOWER C - ROOF

P2.2C.R

1 PLAN - TOWER C - ROOF
SCALE: 1/8" = 1'-0"

- 1 STEAM SHOWER GENERATOR UNIT. PROVIDE 1/2" CW WITH SHUT-OFF VALVE AND ROUTE DRAIN TO LAV TAILPIPE.
- 2 PROVIDE 1/2" HW, 1/2" CW, 1-1/2" VENT AND 2" SAN FOR BAR SINK. PROVIDE 1/2" HW AND DRAIN WITH AIR GAP FOR DISHWASHER TYPE DISHWASHER.
- 3 PROVIDE 3/4" G, LOW PRESSURE REGULATOR, AND SHUT-OFF VALVE FOR BBQ.
- 4 PROVIDE 1/2" G, LOW PRESSURE REGULATOR, AND SHUT-OFF VALVE FOR FIREPLACE.
- 5 OWNER OPTION: PROVIDE 1/2" CW TO DUCT HUMIDIFIERS. SEE MECHANICAL PLANS FOR LOCATIONS. CONFIRM WITH OWNER PRIOR TO PROVIDING.



Seattle, Washington 98104 USA
+1 206 624 5670 clark@kundig.com

Olson Kuning

Sommet Blanc - Bldg AB
DEER VALLEY, UTAH



PE Engineer
SP USA
01 Fourth Ave., Suite 3100
Seattle, WA 98154

principal architect _____
project manager _____
drawn by _____
checked by GM _____
job no. 2021-0595
date 5/17/2024

ions:


10/06/2022 PERMIT RESUBMITTAL

date by

C Set 2 of 3
5/17/2024


UNIT PLAN - TOWER
B-UNIT A

P2.4.A

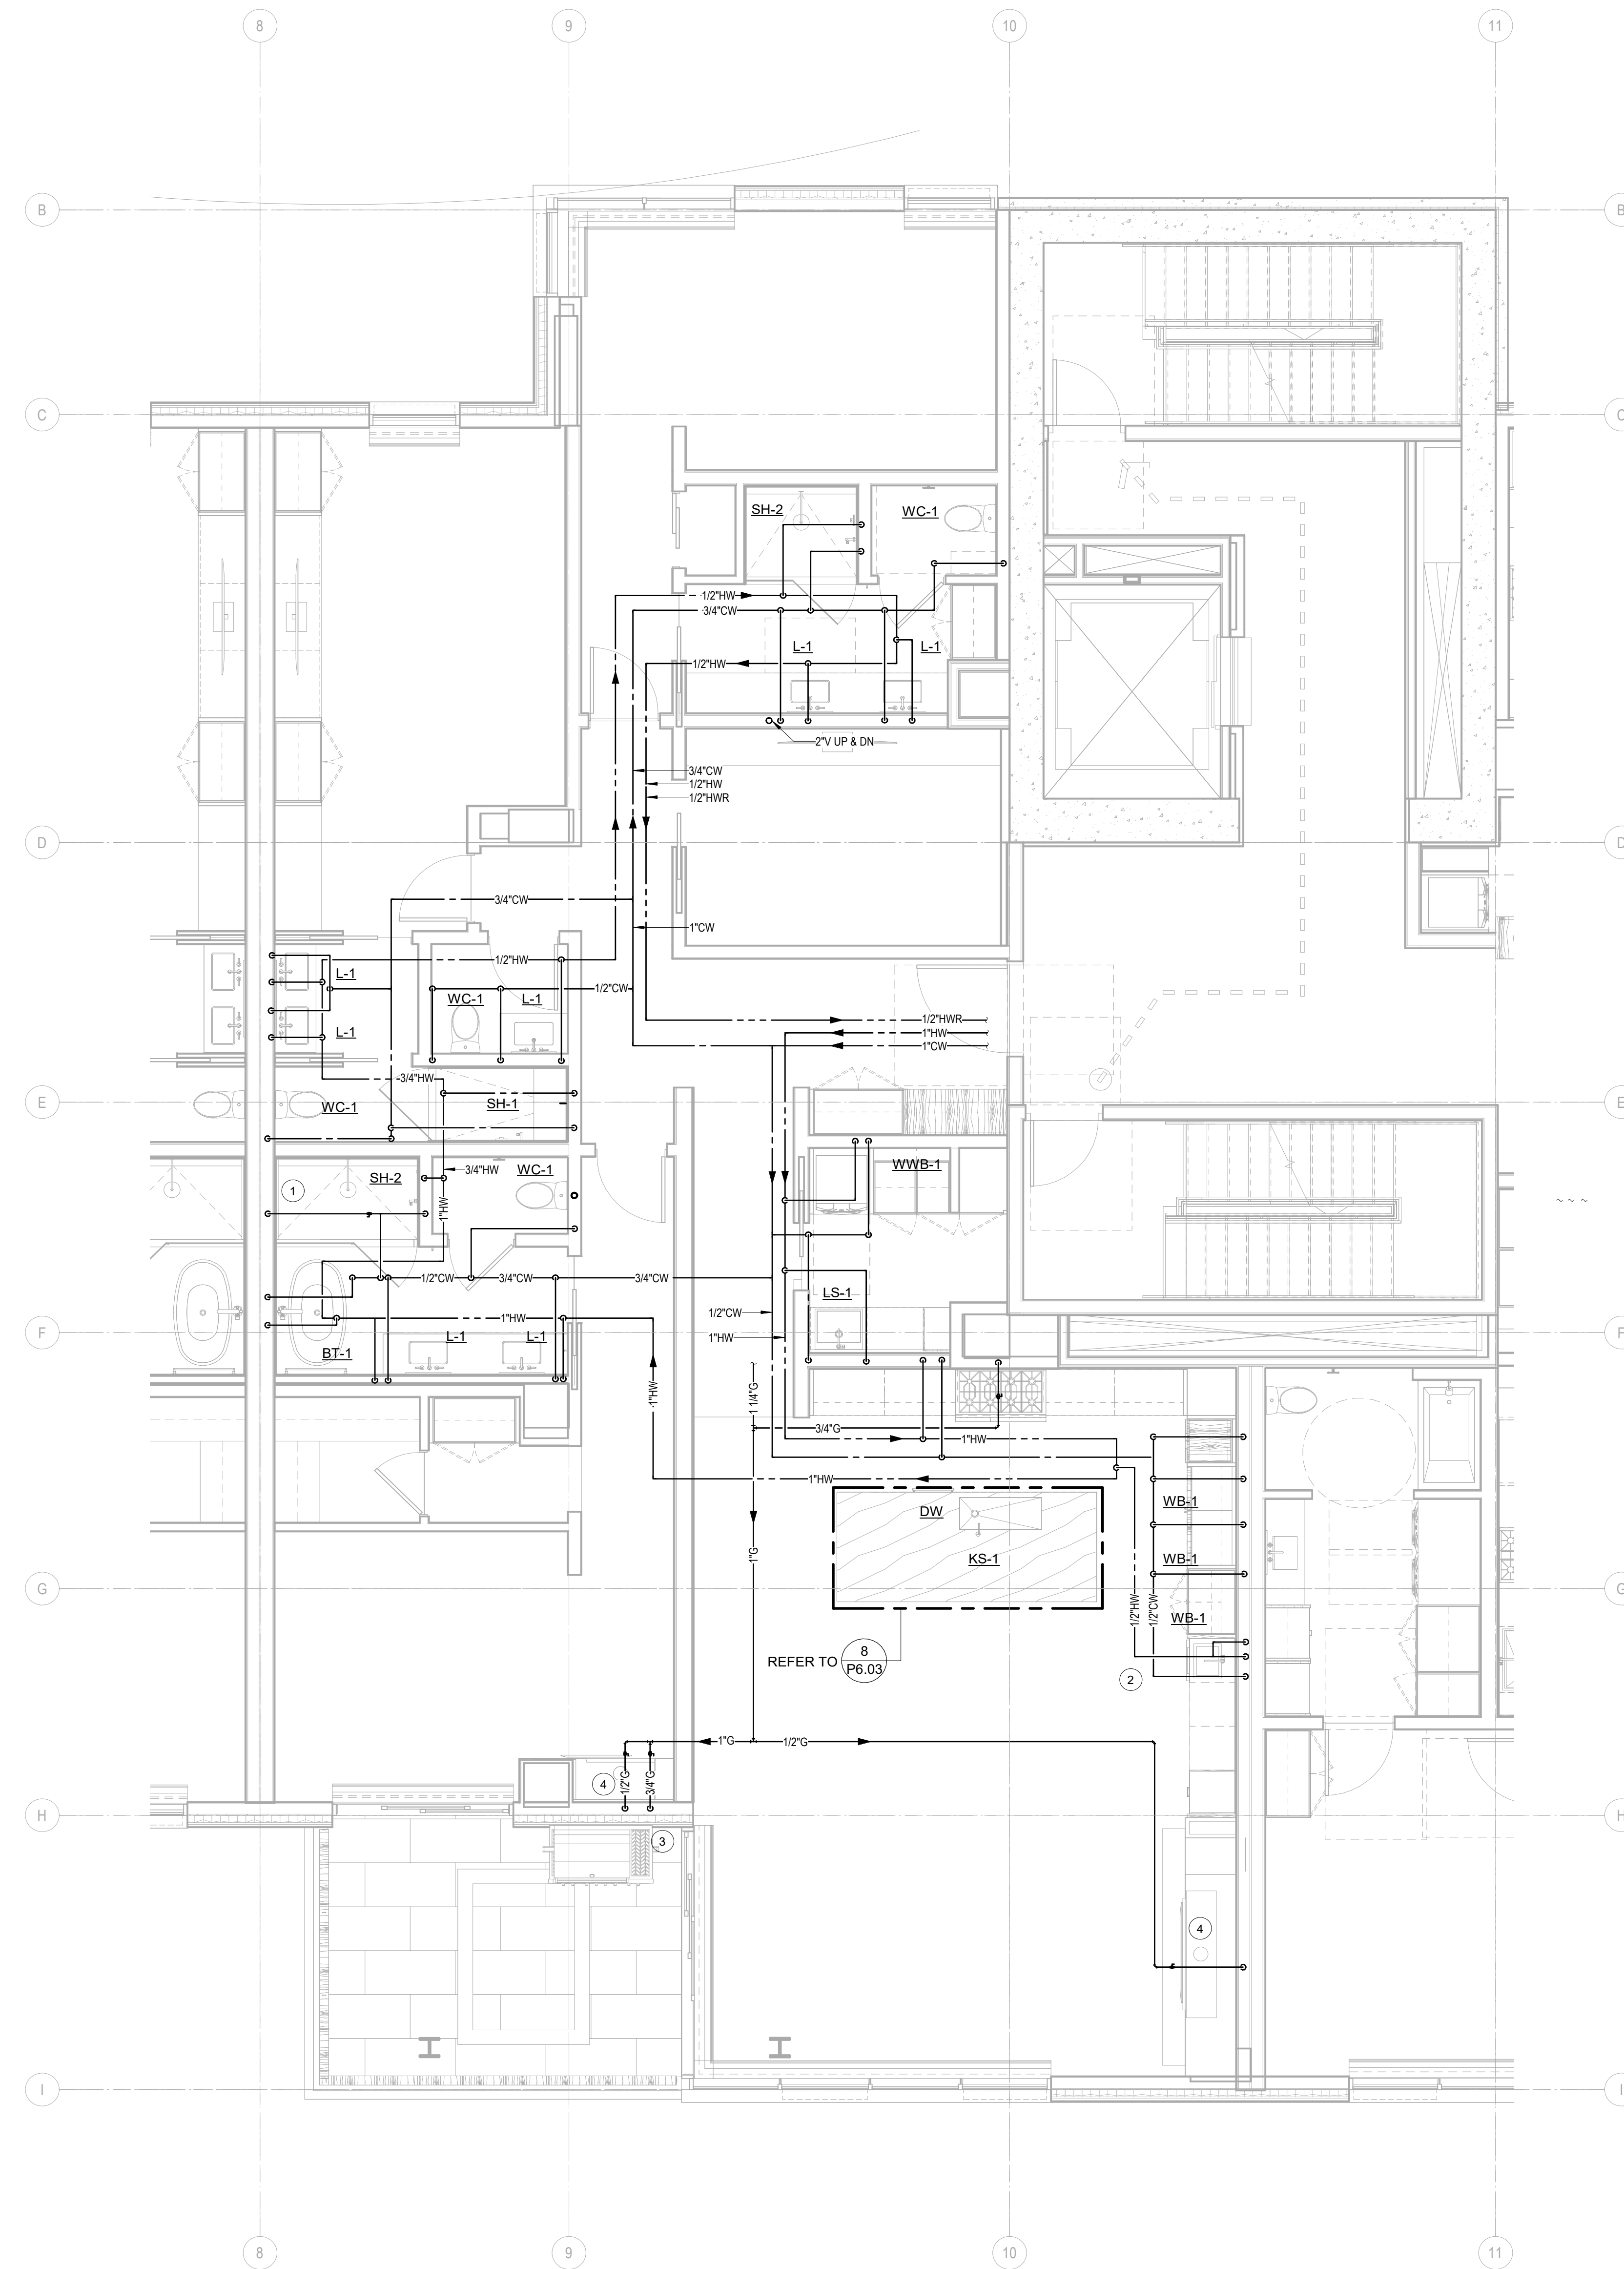

 
1 ENLARGED PLAN - A/B-UNIT A
SCALE: 1/4" = 1'-0"






Olson Kundig

project: **Sommet Blanc - Bldg AB**
DEER VALLEY, UTAH

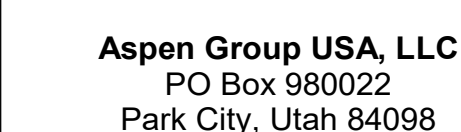

no.	date	by
-----	------	----


P2.4.B

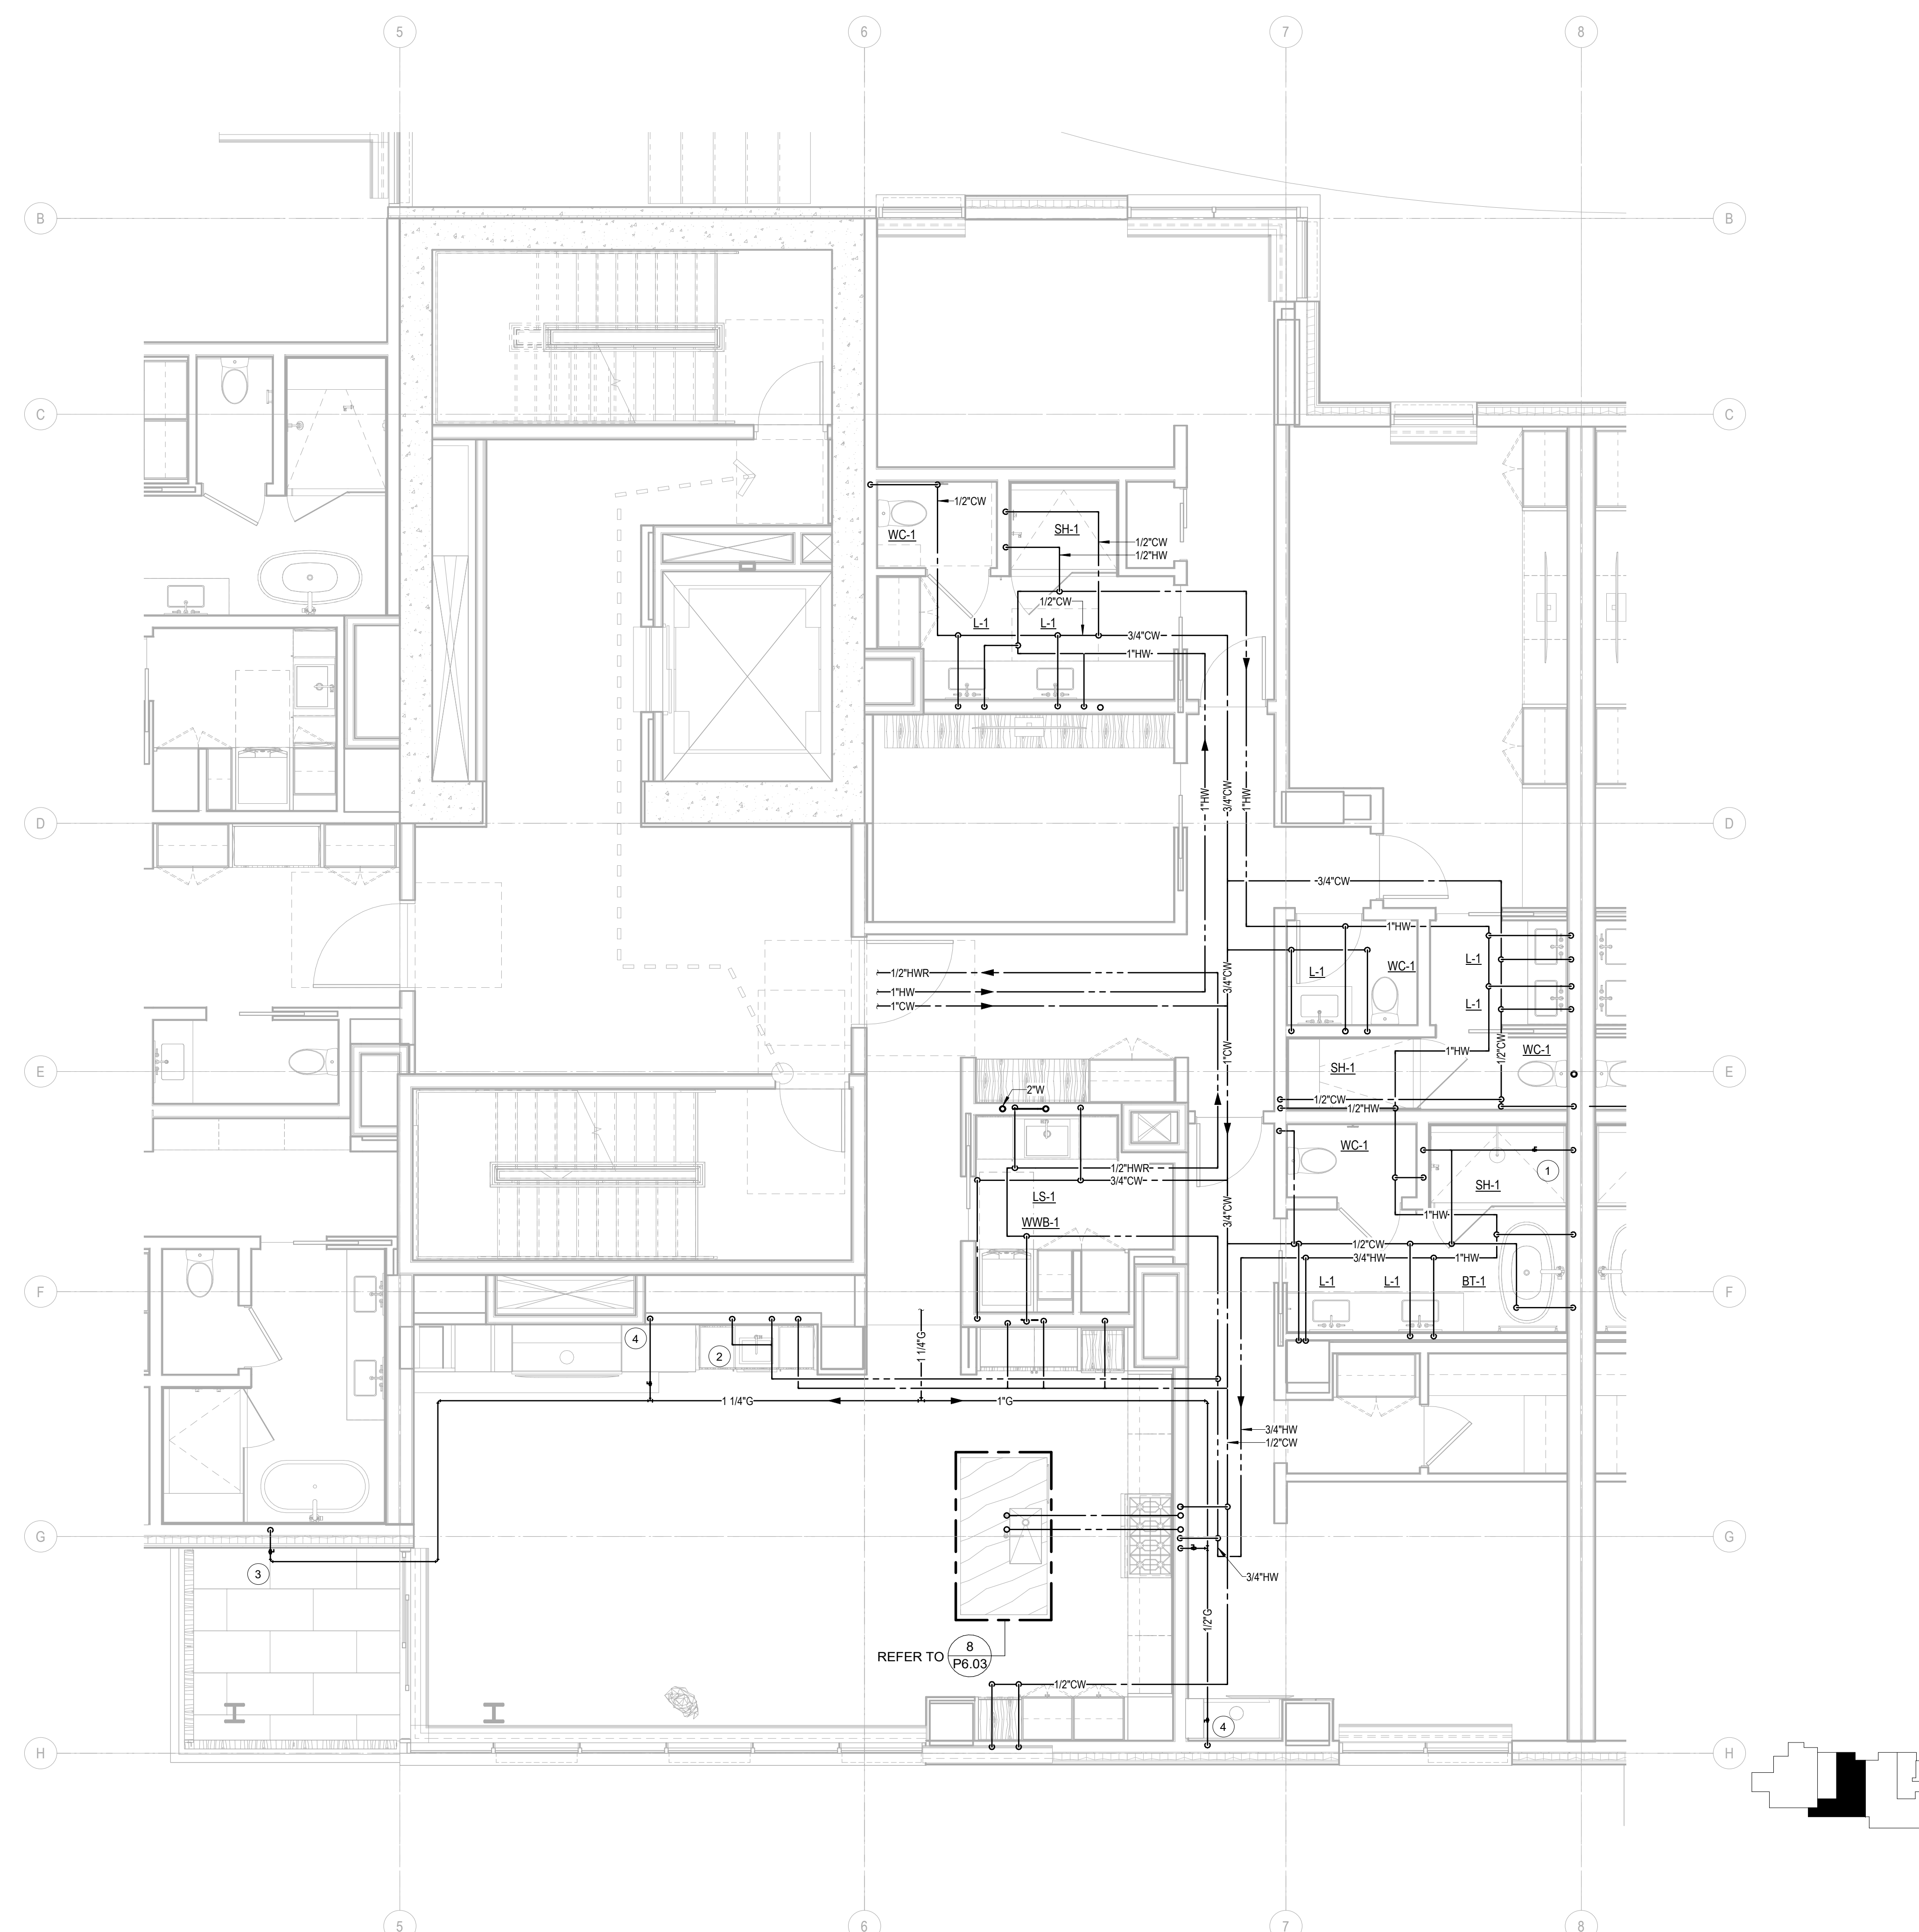

1 ENLARGED PLAN - A/B-UNIT B
SCALE: 1/4" = 1'-0"




 - 1 STEAM SHOWER GENERATOR UNIT. PROVIDE 1/2" CW WITH SHUT-OFF VALVE AND ROUTE DRAIN TO LAV TAILPIPE.
- 2 PROVIDE 5/8" HW, 1/2" CW, 1-1/2" VENT AND 2" SAN FOR BAR SINK. PROVIDE 5/8" HW AND DRAIN WITH AIR GAP FOR DISHWASHER TYPE DISHWASHER.
- 3 PROVIDE 3/4" G, LOW PRESSURE REGULATOR, AND SHUT-OFF VALVE FOR BBQ.
- 4 PROVIDE 1/2" G, LOW PRESSURE REGULATOR, AND SHUT-OFF VALVE FOR FIREPLACE.
- 5 OWNER OPTION: PROVIDE 1/2" CW TO DUCT HUMIDIFIERS. SEE MECHANICAL PLANS FOR LOCATIONS. CONFIRM WITH OWNER PRIOR TO PROVIDING.



Olson Kundig

Project: **Sommet Blanc - Bldg AB**
DEER VALLEY, UTAH

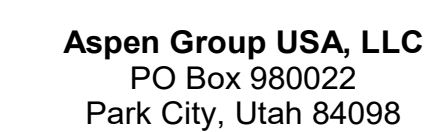

MFP Engineer
WSP USA
1001 Fourth Ave., Suite 3100
Seattle, WA 98154

principal architect _____
project manager _____
drawn by _____
checked by GM _____
job no. 2021-0696
date 5/17/2024


revisions:

no.	date	
-----	------	--

IFC Set 2 of 3
5/17/2024


UNIT PLAN - TOWER
A/B-UNIT C

 P2.4.C



Olson Kundig

Project: **Sommet Blanc - Bldg AB**
DEER VALLEY, UTAH

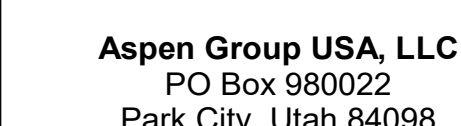


MEP Engineer
WSP USA
1001 Fourth Ave., Suite 3100
Seattle, WA 98154

revisions:

no.	date	b
-----	------	---

UNIT PLAN - TOWER
A/B-UNIT D


P2.4.D

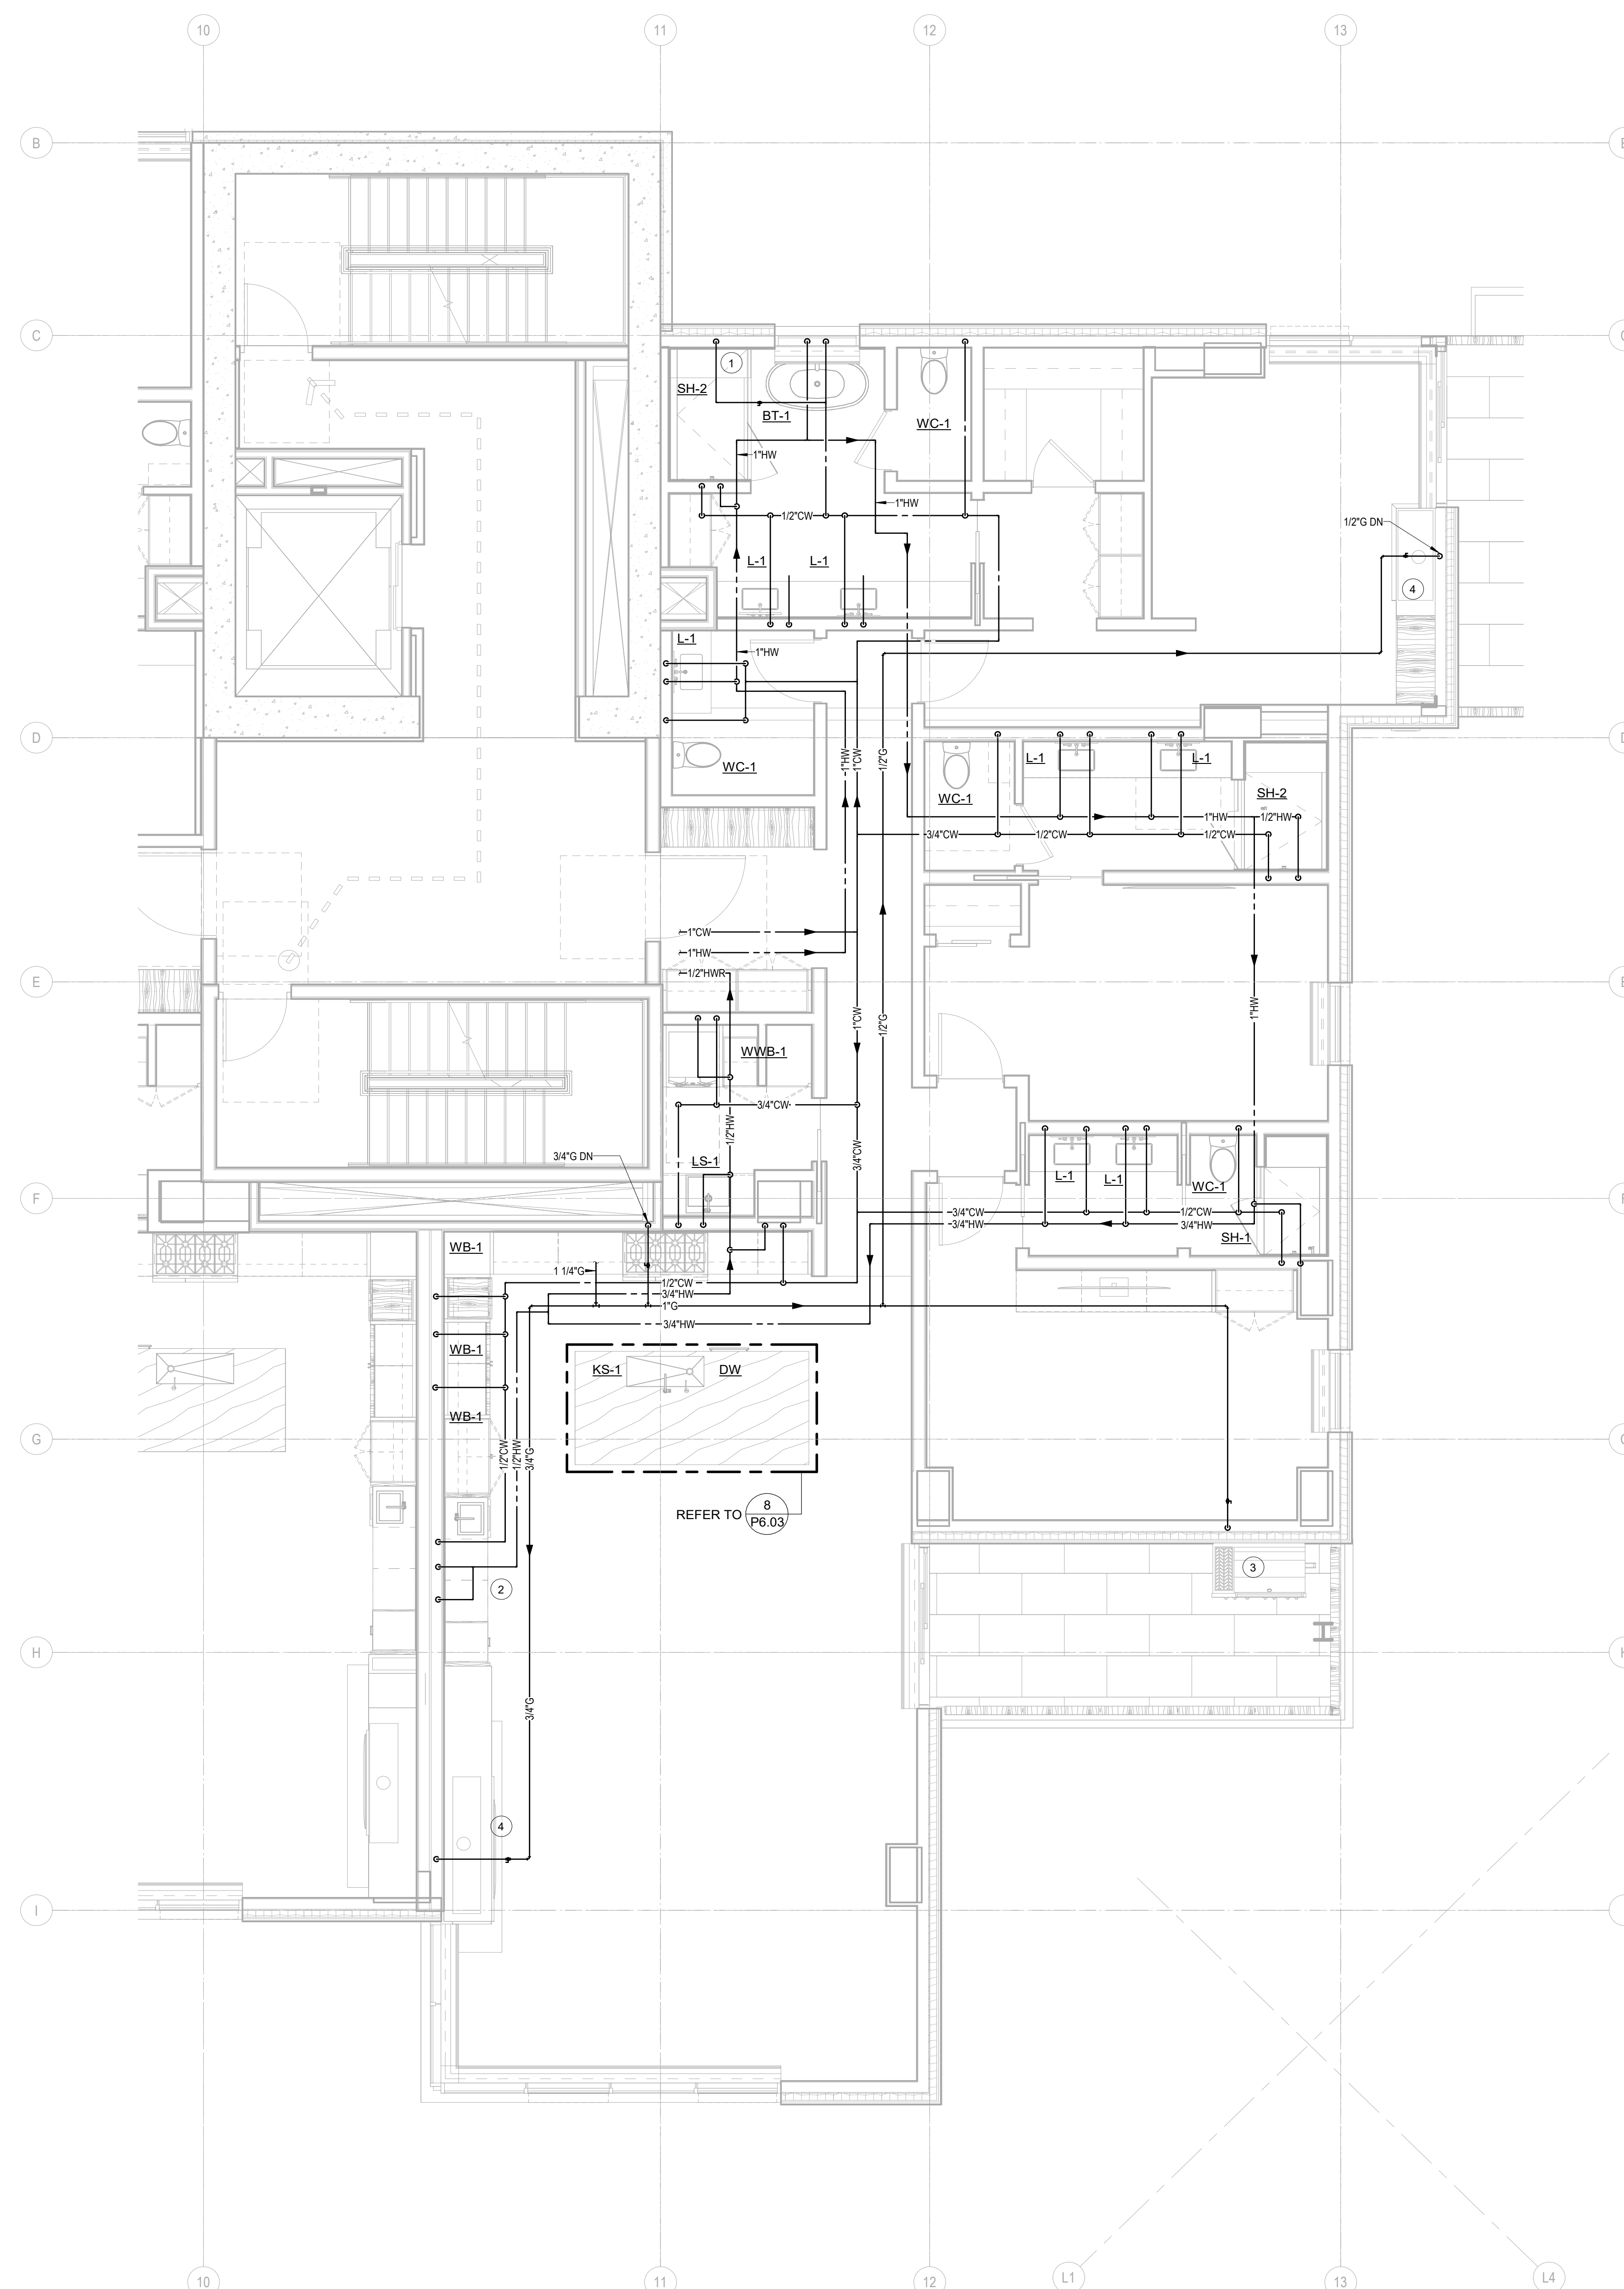

1 ENLARGED PLAN - A/B-UNIT D
SCALE: 1/4" = 1'-0"




 - 4 OWNER OPTION: PROVIDE 1/2" CW TO DUCT HUMIDIFIERS. SEE MECHANICAL PLANS FOR LOCATIONS. CONFIRM WITH OWNER PRIOR TO PROVIDING.



Olson Kundig

project:

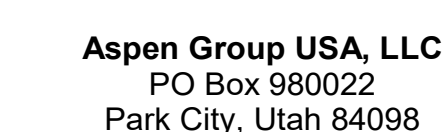

MEP Engineer
WSP USA
1001 Fourth Ave., Suite 3100
Seattle, WA 98154

1 10/06/2022 PERMIT RESUBMITTAL


no.	date	b
-----	------	---

IFC Set 2 of 3
5/17/2024

UNIT PLAN - TOWER
A/B-UNIT G


P2.4.G



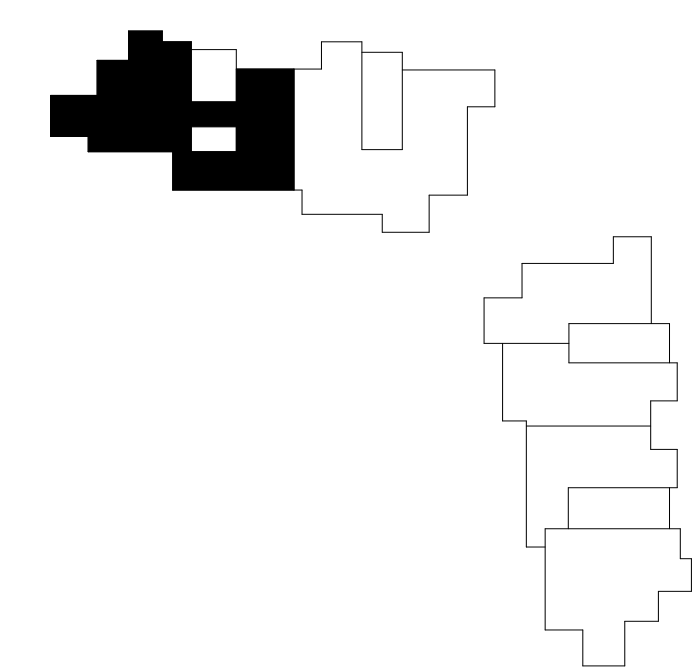

1 ENLAR
SCALE: 1/4" = 1'-0"

- NUMBERED NOTES:**
1. PROVIDE 3/4" G, LOW PRESSURE REGULATOR, AND SHUT-OFF VALVE FOR BBQ.
 2. PROVIDE 3/4" G, LOW PRESSURE REGULATOR, AND SHUT-OFF VALVE FOR FIRE PIT.
 3. PROVIDE 1/2" G, LOW PRESSURE REGULATOR, AND SHUT-OFF VALVE FOR FIREPLACE.
 4. STEAM SHOWER GENERATOR UNIT: PROVIDE 1/2" CW WITH SHUT-OFF VALVE AND ROUTE DRAIN TO TAIL PIPE.
 5. PROVIDE HOT & COLD WALL HYDRANT FOR FILL FOR HOT TUB.
 6. PROVIDE WATER AND DRAIN CONNECTIONS FOR SECOND DOWNSHOWER.
 7. PROVIDE 3/4" G, LOW PRESSURE REGULATOR, AND SHUT-OFF VALVE FOR FIREPLACE.
 8. OWNER OPTION: PROVIDE 1/2" CW TO DUCT HUMIDIFIERS. SEE MECHANICAL PLANS FOR LOCATIONS. CONFIRM WITH OWNER PRIOR TO PROVIDING.
 9. PROVIDE 1/2" DRAIN TUBING FROM WINE COOLER UNIT EVAPORATOR TO ADJACENT SINK TAILPIPE.

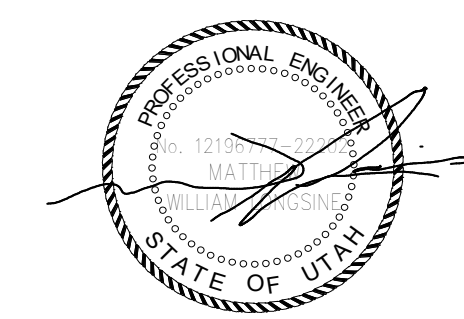

Reserved for permit stamp

159 South Jackson St, Suite 600
Seattle, Washington 98104 USA
+1 206 624 5670 ds@orkundig.com

Olson Kundig

Project: **Sommet Blanc - Bldg AB**
DEER VALLEY, UTAH



Aspen Group USA, LLC
PO Box 980022
Park City, Utah 84098

Pool Consultant
Cloward H20
2896 N University Ave, Suite 290
Provo, UT 84604

Landscape Architect
EPG Design
6949 South High Tech Drive, Suite 100
Midvale, Utah 84047

Specifications Writer
Friday Group
 88 Mainelli Road
 Middlebury, VT

Code Consultant
Holmes
600 1st Avenue, Suite 200A
Seattle, WA 98104

Fire Protection Engineer
Jensen Hughes
One Research Drive, Suite 305C
Westborough, MA 01581

Vertical Transportation Consultant
Lerch Bates
19515 North Creek Parkway, Suite 304
Bothell, WA 98011

Structural Engineer
Magnusson Klemencic Associates
1301 5th Ave, Suite 3200
Seattle, WA 98101

Lighting Designer
O-
1319 SE MLK Blvd, Suite 210
Portland, Oregon 97219

Building Envelope Consultant
RDH
2101 N 34th St
Seattle, WA 98103

Accessibility Consultant
Studio Pacifica
2144 Westlake Ave N, Suite F
Seattle, WA 98109

MEP Engineer
WSP USA
1001 Fourth Ave., Suite 3100
Seattle, WA 98154

principal architect _____
project manager _____

checked by GM
job no. 2021-0696

revisions:

[illegible]

1 10/06/2022 PERMIT RESUBMITTAL

no.	date	by
-----	------	----

 
IFC Set 2 of 3
5/17/2024

UNIT PLAN - TOWER
A/B-UNIT H


P2.4.H



-




- | | |
|--|--|
| <p>100 South Jackson St. Suite 600
Somerset, Washington 98148 USA
+1 206 461-2017 info@sommet.com</p> | <p>project: Sommet Blanc - Bldg AB
DEER VALLEY, UTAH</p> |
|--|--|

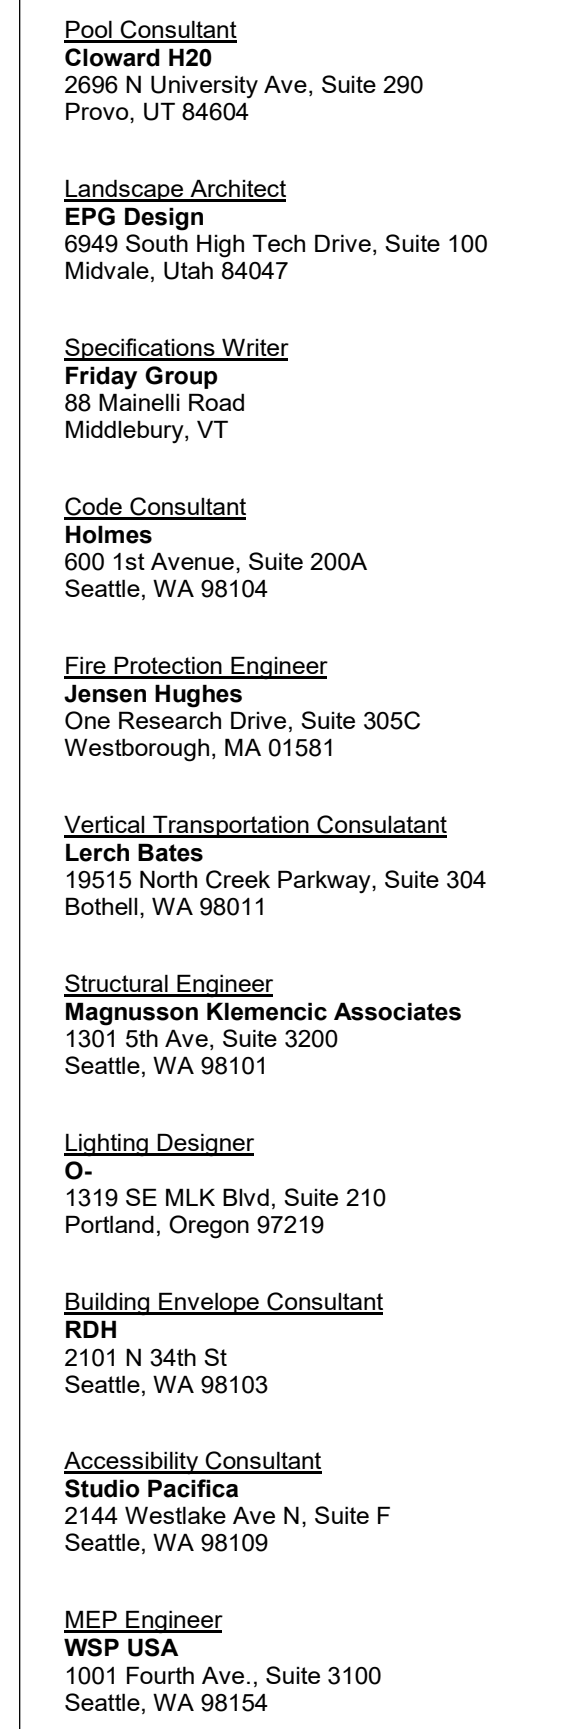


IFC Set 2 of 3
5/17/2024

UNIT PLAN - TOWER
A/B-UNIT J

P2.4.J

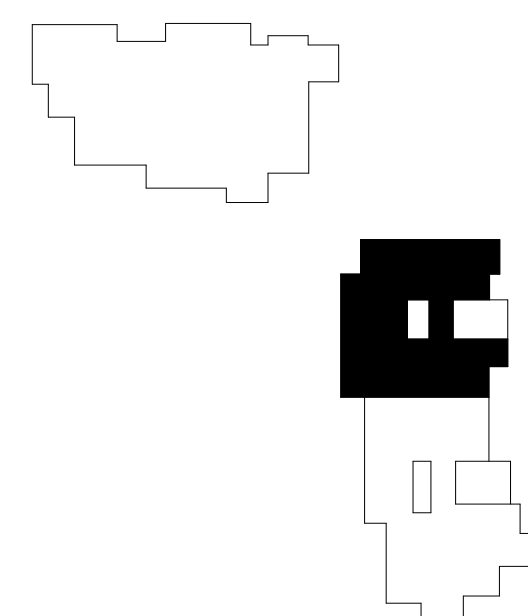

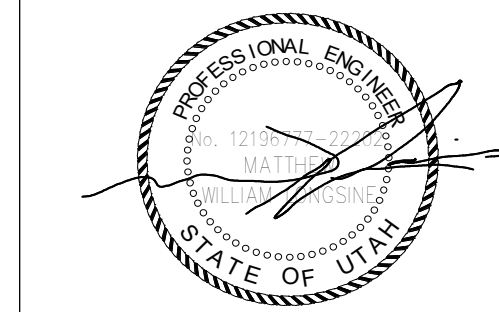

Reserved for permit stamp

159 South Jackson St, Suite 600
Seattle, Washington 98104 USA
+1 206 624 5670 olsonkundig.com

Olson Kundig

project:
Sommet Blanc -C
DEER VALLEY, UTAH



Aspen Group USA, LLC
PO Box 980022
Park City, Utah 84098

Pool Consultant
Cloward H20
2896 N University Ave, Suite 290
Provo, UT 84604

Landscape Architect
EPG Design
6949 South High Tech Drive, Suite 100
Midvale, Utah 84047

Specifications Writer
Friday Group
88 Mainelli Road
Middlebury, VT

Code Consultant
Holmes
600 1st Avenue, Suite 200
Seattle, WA 98104

Fire Protection Engineer
Jensen Hughes
One Research Drive, Suite 305C
Westborough, MA 01581

Vertical Transportation Consultant
Lerch Bates
19515 North Creek Parkway, Suite 304
Bothell, WA 98011

Structural Engineer
Magnusson Klemencic Associates
1301 5th Ave, Suite 3200
Seattle, WA 98101

Lighting Designer
O-
1319 SE MLK Blvd, Suite 210
Portland, Oregon 97219

Building Envelope Consultants
RDH
2101 N 34th St
Seattle, WA 98103

Accessibility Consultant
Studio Pacifica
2144 Westlake Ave N, Suite F
Seattle, WA 98109

MFP Engineer
WSP USA
1001 Fourth Ave., Suite 3100
Seattle, WA 98154

principal architect _____
project manager _____
drawn by _____
checked by GM _____
job no. 2021-0595
date 5/17/2024

revisions:

no.	date	by
-----	------	----


IFC Set 2 of 3
5/17/2024

UNIT PLAN - TOWER
C-UNIT L

P2.4.L




P2.4.M

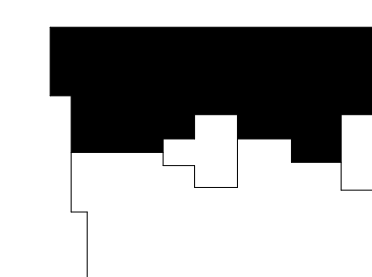



- KEYNOTES:**
- | | |
|---|--|
| 1 | 2" SAN DN & 2" V RISE |
| 2 | 2" V DN |
| 3 | 1/2" CW & 1/2" HW DN |
| 4 | 2" SAN & 2" V DN |
| 5 | 2" SAN & 2" V UP |
| 6 | 1/2" CW & 1/2" HW UP |
| 7 | 1/2" CW & 1/2" HW UP TO HOT TUB
2" SAN DN |
| 8 | 2" SAN DN |

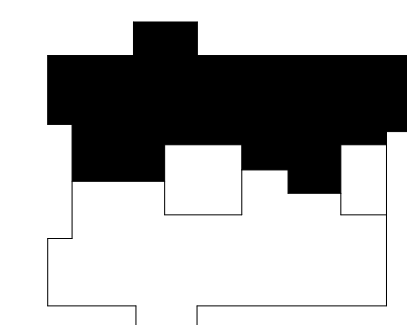





KEYNOTES:

1 1/2" CW & 1/2" HW DN

P2.4.O

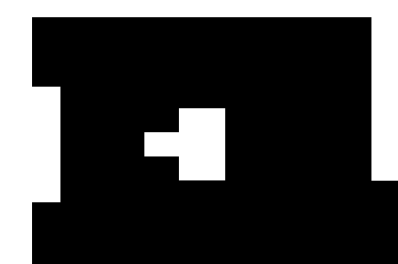


 1 OPTION: PROVIDE 1/2" CW TO DUCT HUMIDIFIERS. SEE MECHANICAL PLANS FOR LOCATIONS. CONFIRM WITH OWNER PRIOR TO PROVIDING.



Olson Kundig

project:
Sommet Blanc -C
DEER VALLEY, UTAH

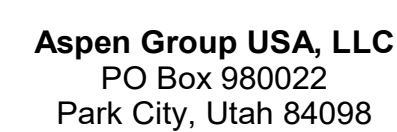

MEP Engineer
WSP USA
1001 Fourth Ave., Suite 3100
Seattle, WA 98154

principal architect _____
project manager _____
drawn by _____
checked by GM
job no. 2021-0595
date 5/17/2024


revisions:



no. date by

IFC Set 2 of 3
5/17/2024

UNIT PLAN - TOWER C -
UNIT R


P2.4.R

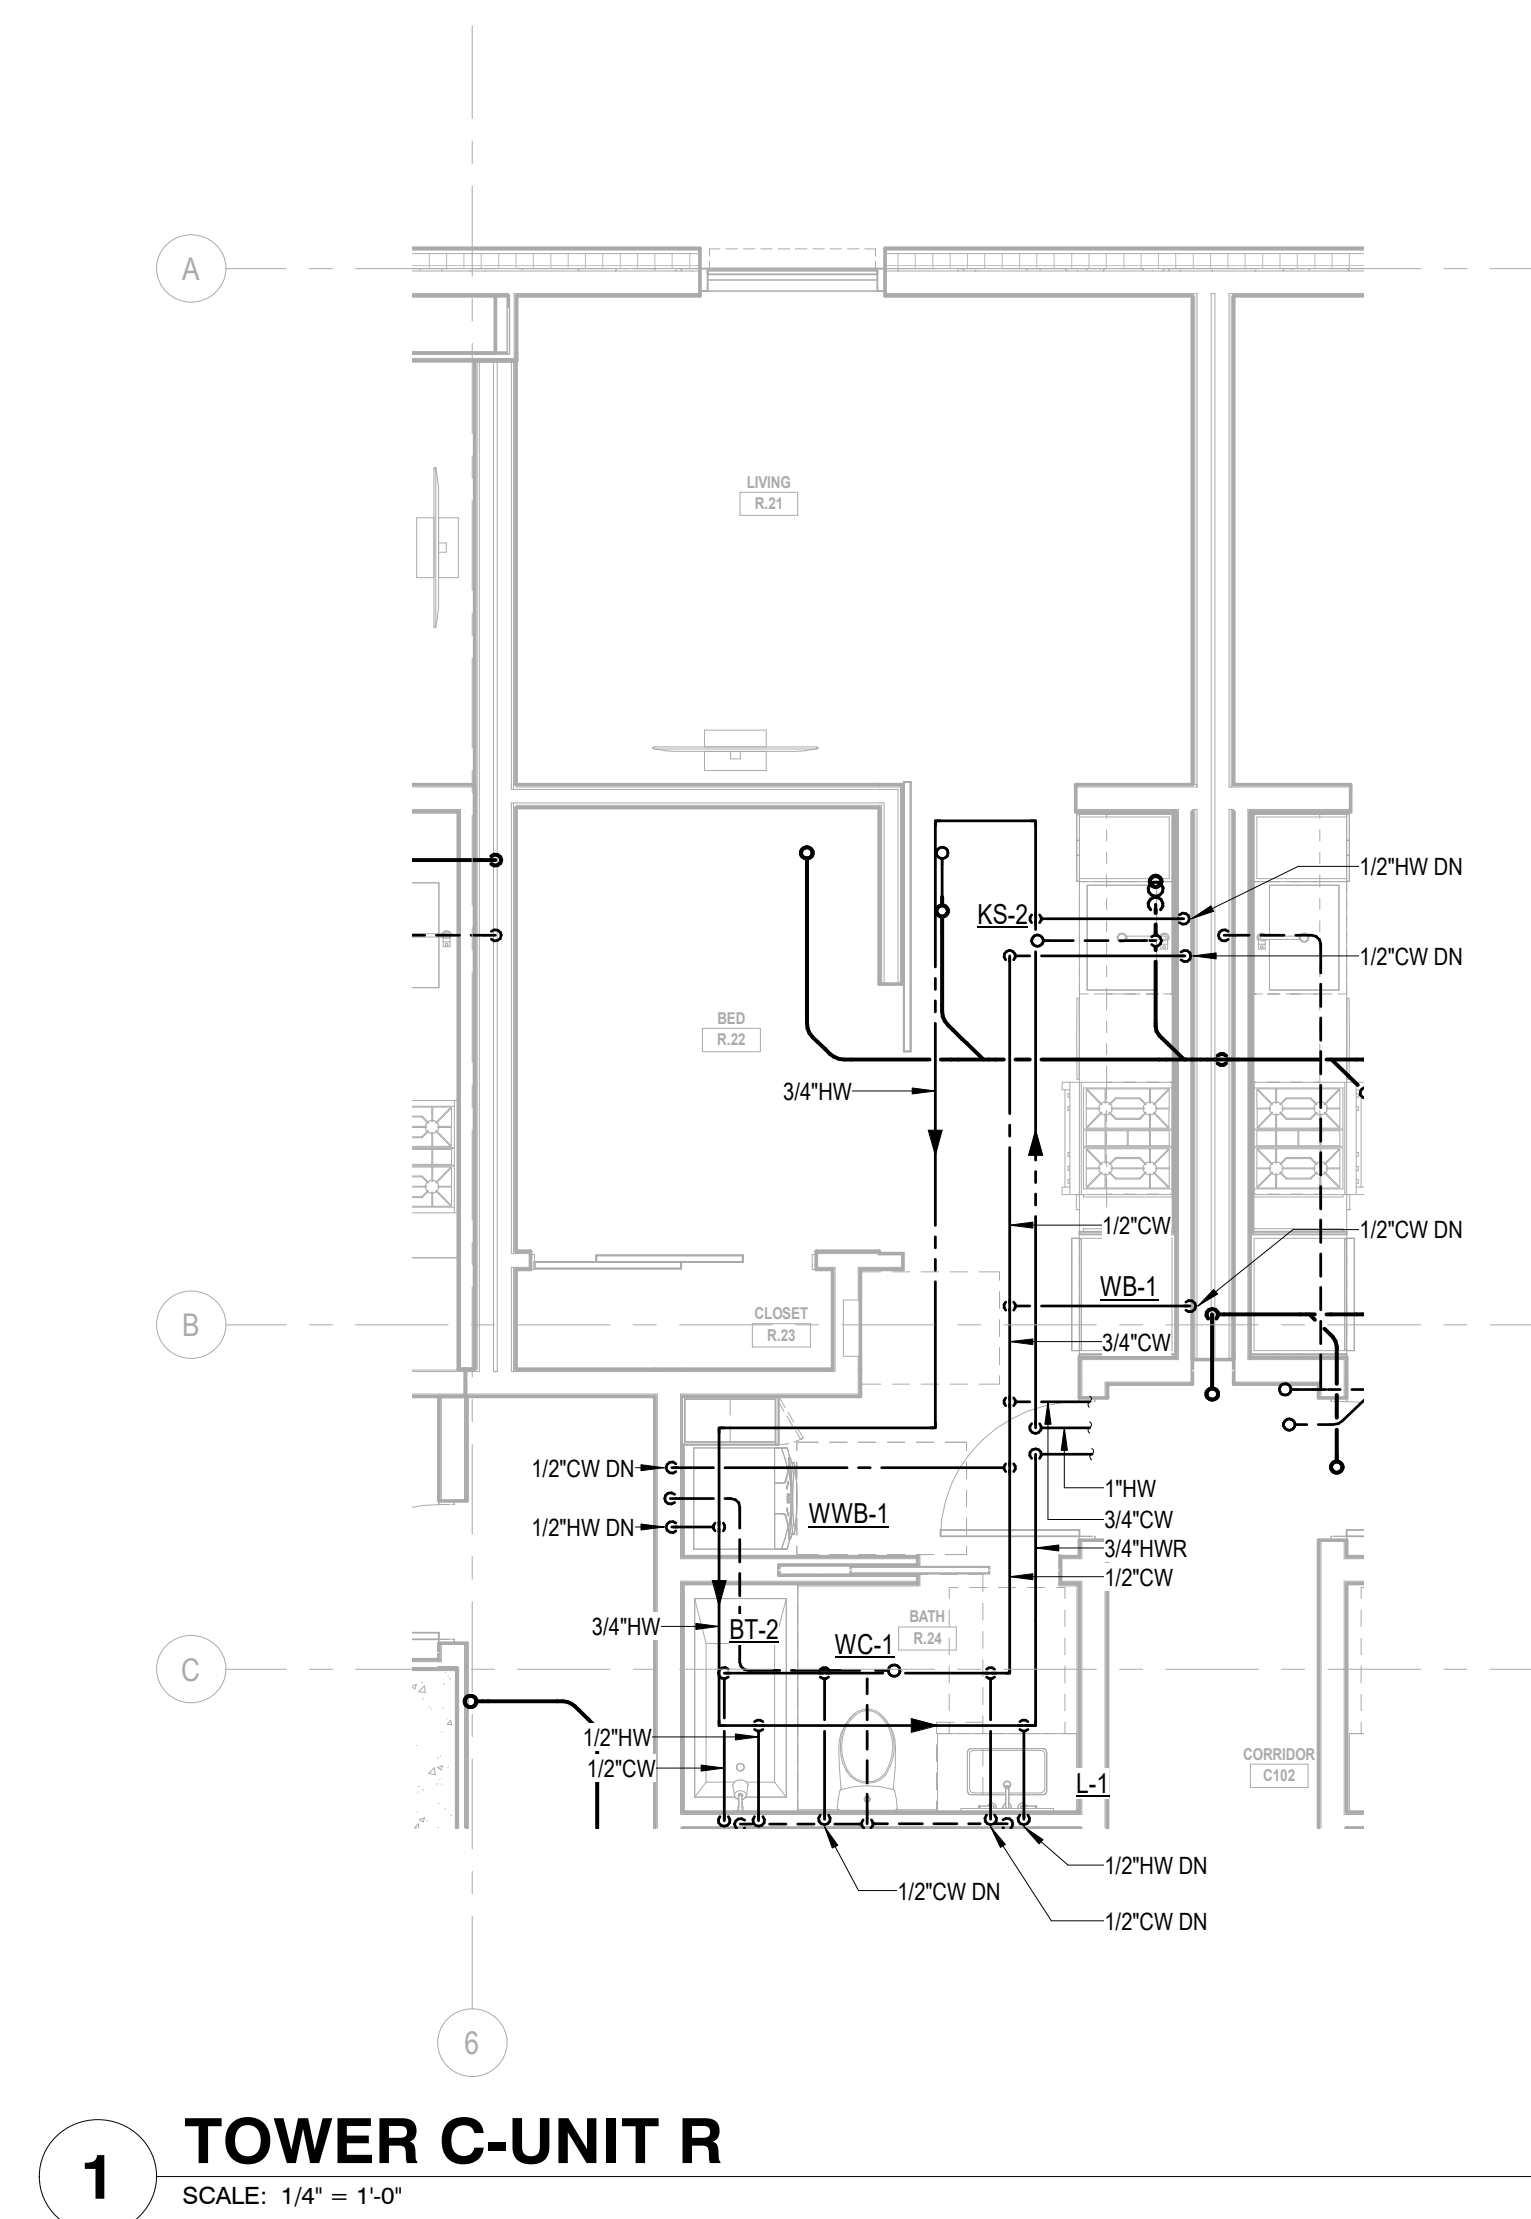

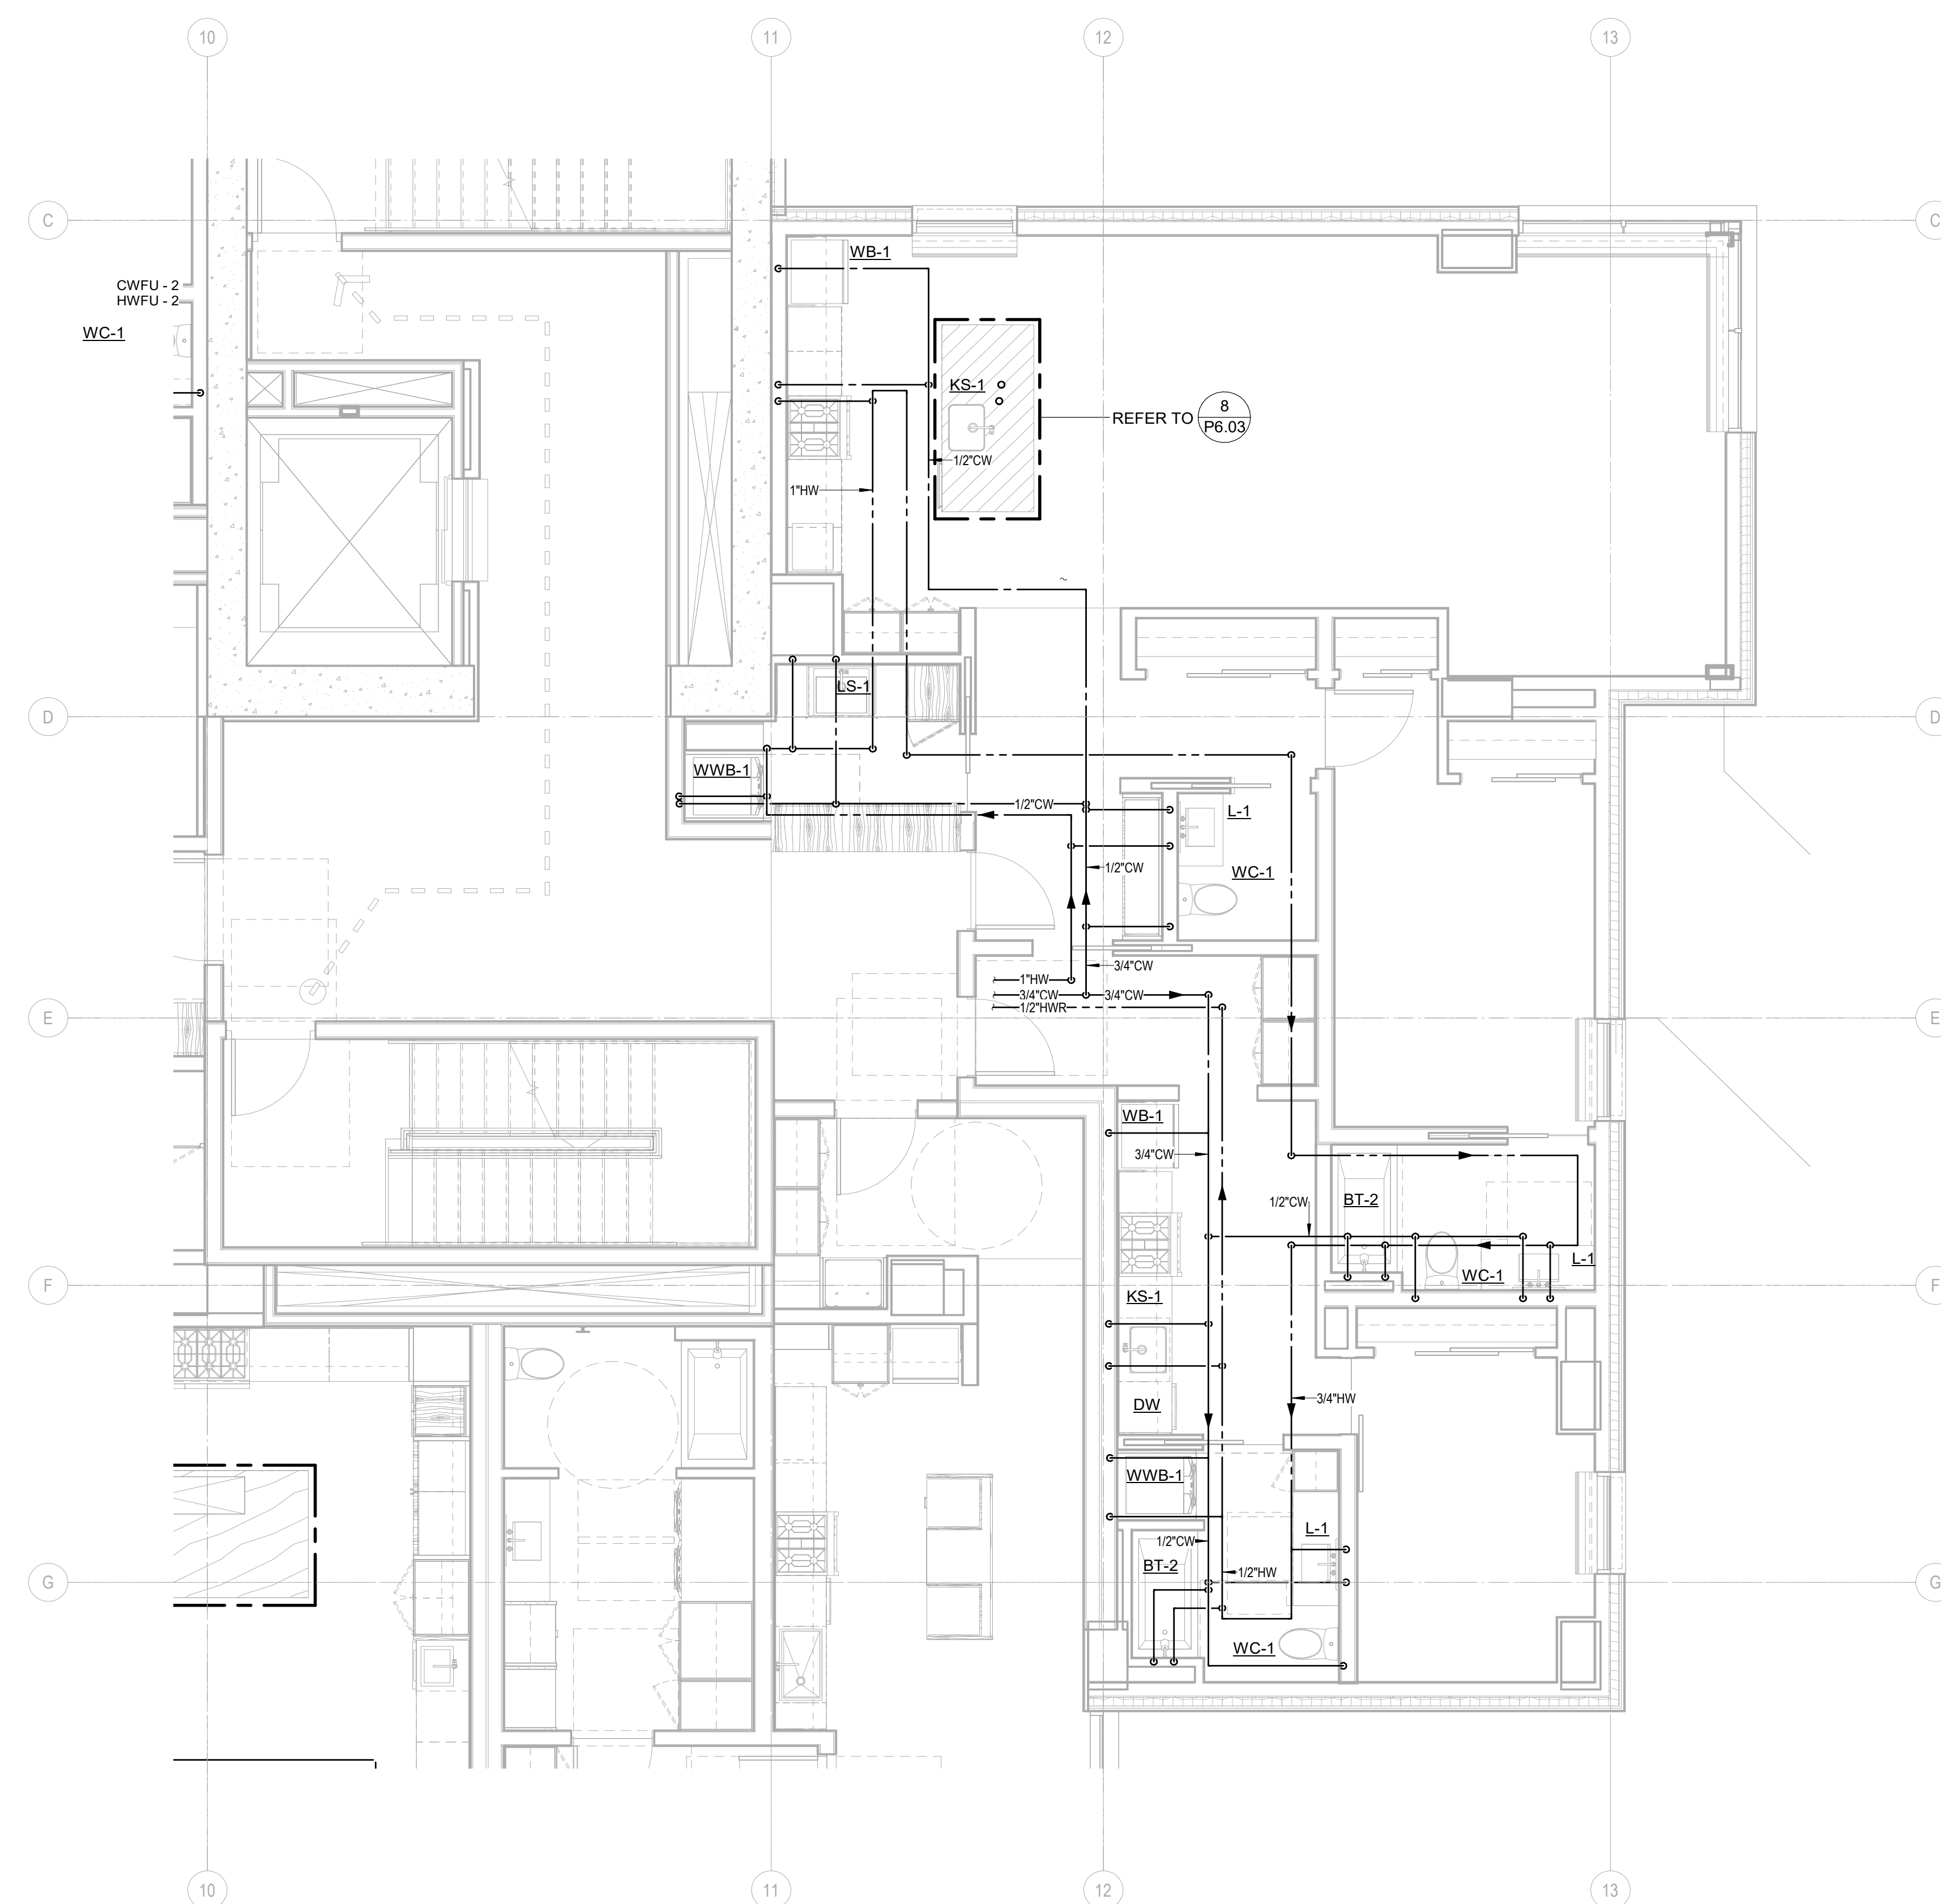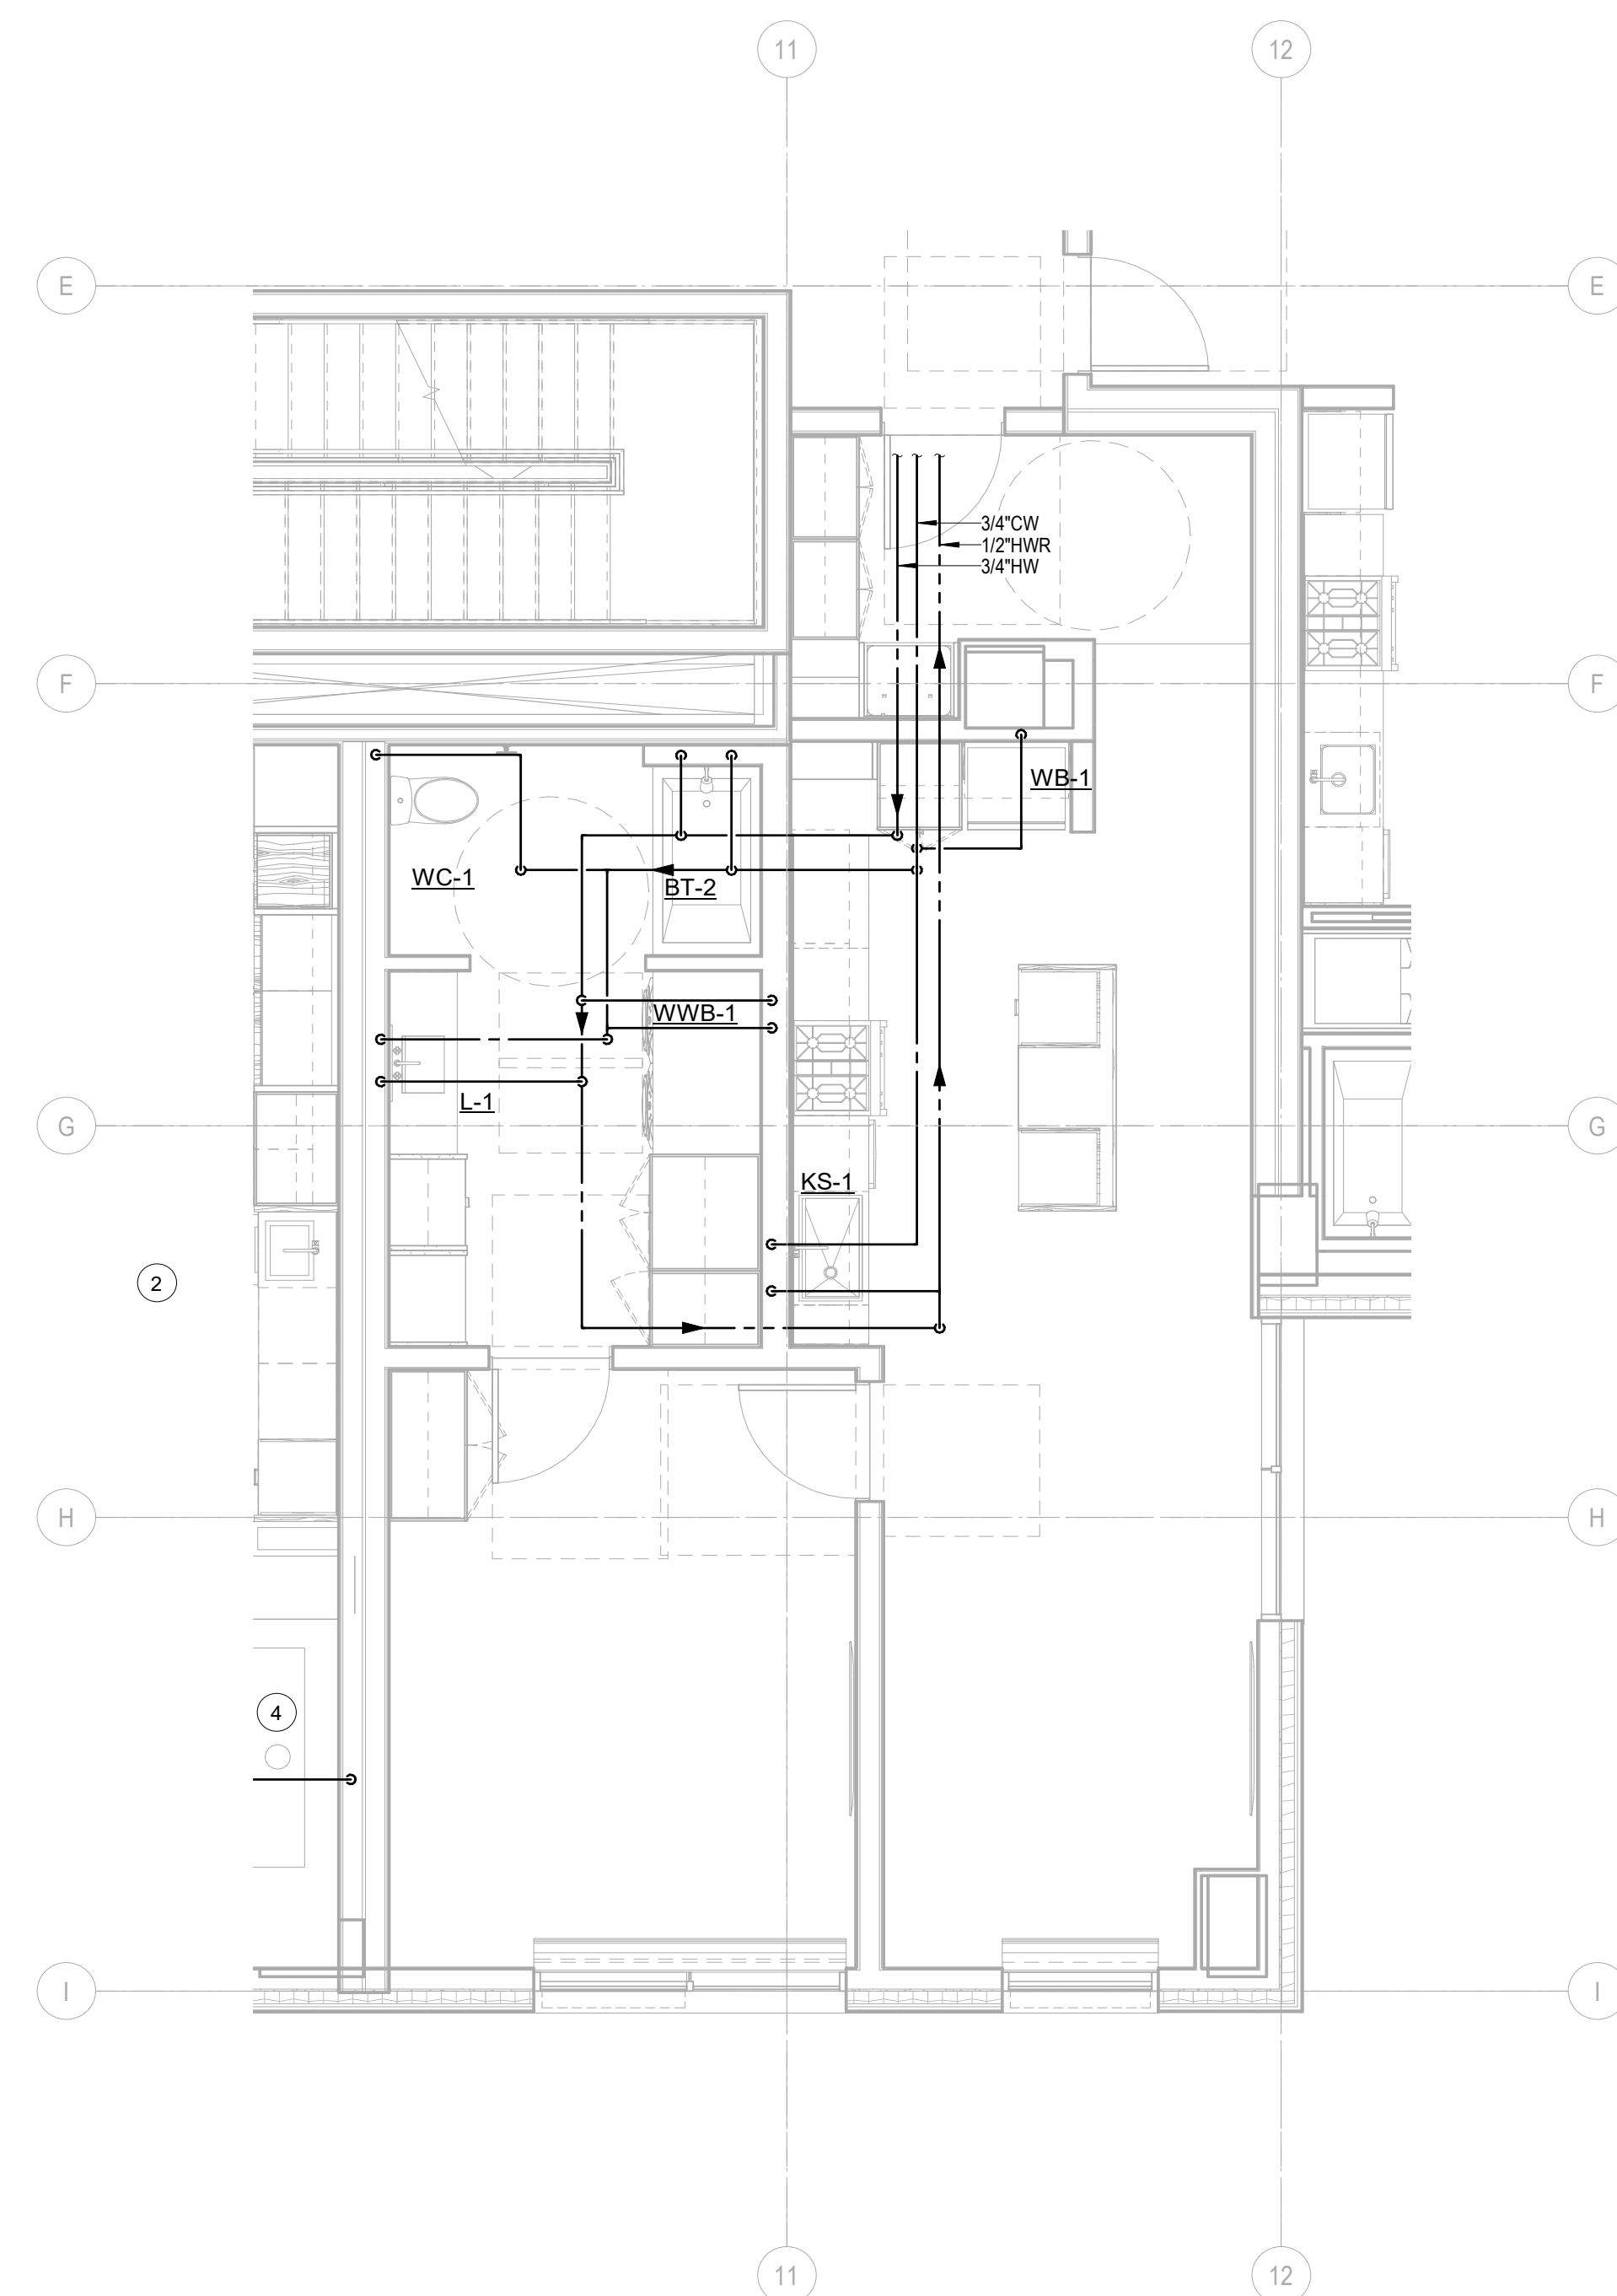

NUMBERED NOTES:

- 1 OWNER OPTION: PROVIDE 1/2" CW TO DUCT HUMIDIFIERS. SEE MECHANICAL PLANS FOR LOCATIONS. CONFIRM WITH OWNER PRIOR TO PROVIDING.
- 2 ROUTE 1/2" DRAIN TUBING FROM WINE COOLER UNIT EVAPORATOR TO ADJACENT SINK TAILPIECE.

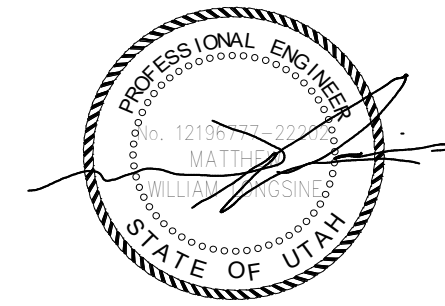

Reserved for permit stamp

159 South Jackson St., Suite 600
Seattle, Washington 98104 USA
+1 206 624 5670 olsorkundig.com

Olson Kundig

project: **Sommet Blanc - Bldg AB**
DEER VALLEY, UTAH



Aspen Group USA, LLC
PO Box 980022
Park City, Utah 84098

Pool Consultant
Cloward H2O
2896 N University Ave, Suite 290
Provo, UT 84604

Landscape Architect
EPG Design
6949 South High Tech Drive, Suite 100
Midvale, Utah 84047

Specifications Writer
Friday Group
89 Mainelli Road
Middlebury, VT

Code Consultant
Holmes
600 1st Avenue, Suite 200A
Seattle, WA 98104

Fire Protection Engineer
Jensen Hughes
One Research Drive, Suite 305C
Westborough, MA 01581

Vertical Transportation Consultant
Lerch Bates
19515 North Creek Parkway, Suite 304
Bothell, WA 98011

Structural Engineer
Magnusson Klemencic Associates
1301 5th Ave, Suite 3200
Seattle, WA 98101

Lighting Designer
O-
1319 SE MLK Blvd, Suite 210
Portland, Oregon 97219

Building Envelope Consultant
RDH
2101 N 34th St
Seattle, WA 98103

Accessibility Consultant
Studio Pacifica
2144 Westlake Ave N, Suite F
Seattle, WA 98109

MFP Engineer
WSP USA
1001 Fourth Ave., Suite 3100
Seattle, WA 98154

principal architect _____
project manager _____
drawn by _____
checked by GM _____
job no. 2021-0556
date 5/17/2024

revisions:

1	10/06/2022	PERMIT RESUBMITTAL
no.	date	by

IFC Set 2 of 3
5/17/2024

UNIT PLAN - TOWER
A/B-UNIT P & Q


P2.4.X



P5.01


25	FILTER SYSTEM	1/2							
25	BLAST CHILLER/SHOCK FREEZER				1 1/4	-	-	-	-
26	WORK TABLE W/SINK	1/2	1/2	1 1/2					
30	HAND SINK	1/2	1/2		1/2	1 1/2			



 

Olson Kundig

Sommet Blanc - Bldg AB
DEER VALLEY, UTAH

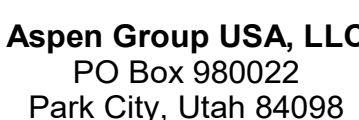

MFP Engineer
WSP USA
1001 Fourth Ave., Suite 3100
Seattle, WA 98154

revisions:

no.	date	by
-----	------	----

DETAILS



 
1. INSTALLATION SHALL BE IN ACCORDANCE WITH THE REQUIREMENTS OF THE CURRENT EDITION CPC, CHAPTER 12.
2. NO GAS PIPING SHALL BE INSTALLED IN OR ON THE GROUND UNDER ANY BUILDING OR STRUCTURE.



- NOTE:
1. NO CONTACT BETWEEN PIPE CLAMP AND STUDS OR GYPSUM BOARD












1. INSTALL BALANCING VALVE ASSEMBLY IN EACH DOMESTIC HOT WATER RETURN PIPE BRANCH BEYOND THE LAST HOT WATER FIXTURE ON THE BRANCH.
2. PROVIDE SUITABLE ACCESS PANEL AS REQUIRED IN NON-ACCESSIBLE CEILINGS AND WALLS.
3. INSURE BALANCING VALVES & CHECK VALVES ARE INSTALLED WITH FLOW IN THE CORRECT DIRECTION.
4. WHERE INSTALLED VALVE LOCATIONS DEVIATE FROM LOCATIONS SHOWN ON PLUMBING PLANS, CONTRACTOR SHALL



NOTES

- | | |
|--|---|
| 1. FLEXIBLE PIPE CONNECTORS EQUIV. TO 'METRIFLEX' AGA METALPOLO OR EQUAL . | 4. SUBMIT BROCHURES & SHOP DRAWINGS . |
| 2. PIPE SIZES & CONFIGURATIONS OF PIPING MAY VARY - VERIFY LAYOUT ON FLOOR PLANS . | 5. ALL SEISMIC JOINTS SHOULD BE INSPECTED AFTER ANY SEISM ACTIVITY OF 4.5 OR LARGER ON THE RICHTER SCALE . |
| 3. 'LIVE LENGTH' IS BASED ON A 4" MOVEMENT FOR EITHER SIDE OF CENTERLINE . | 6. CONNECTORS ALLOW TRANSVERSE MOTION ONLY. EACH LOOP MUST HAVE (2) CONNECTORS AT 90° ORIENTATION TO BE ALL-DIRECTIONAL . |

   

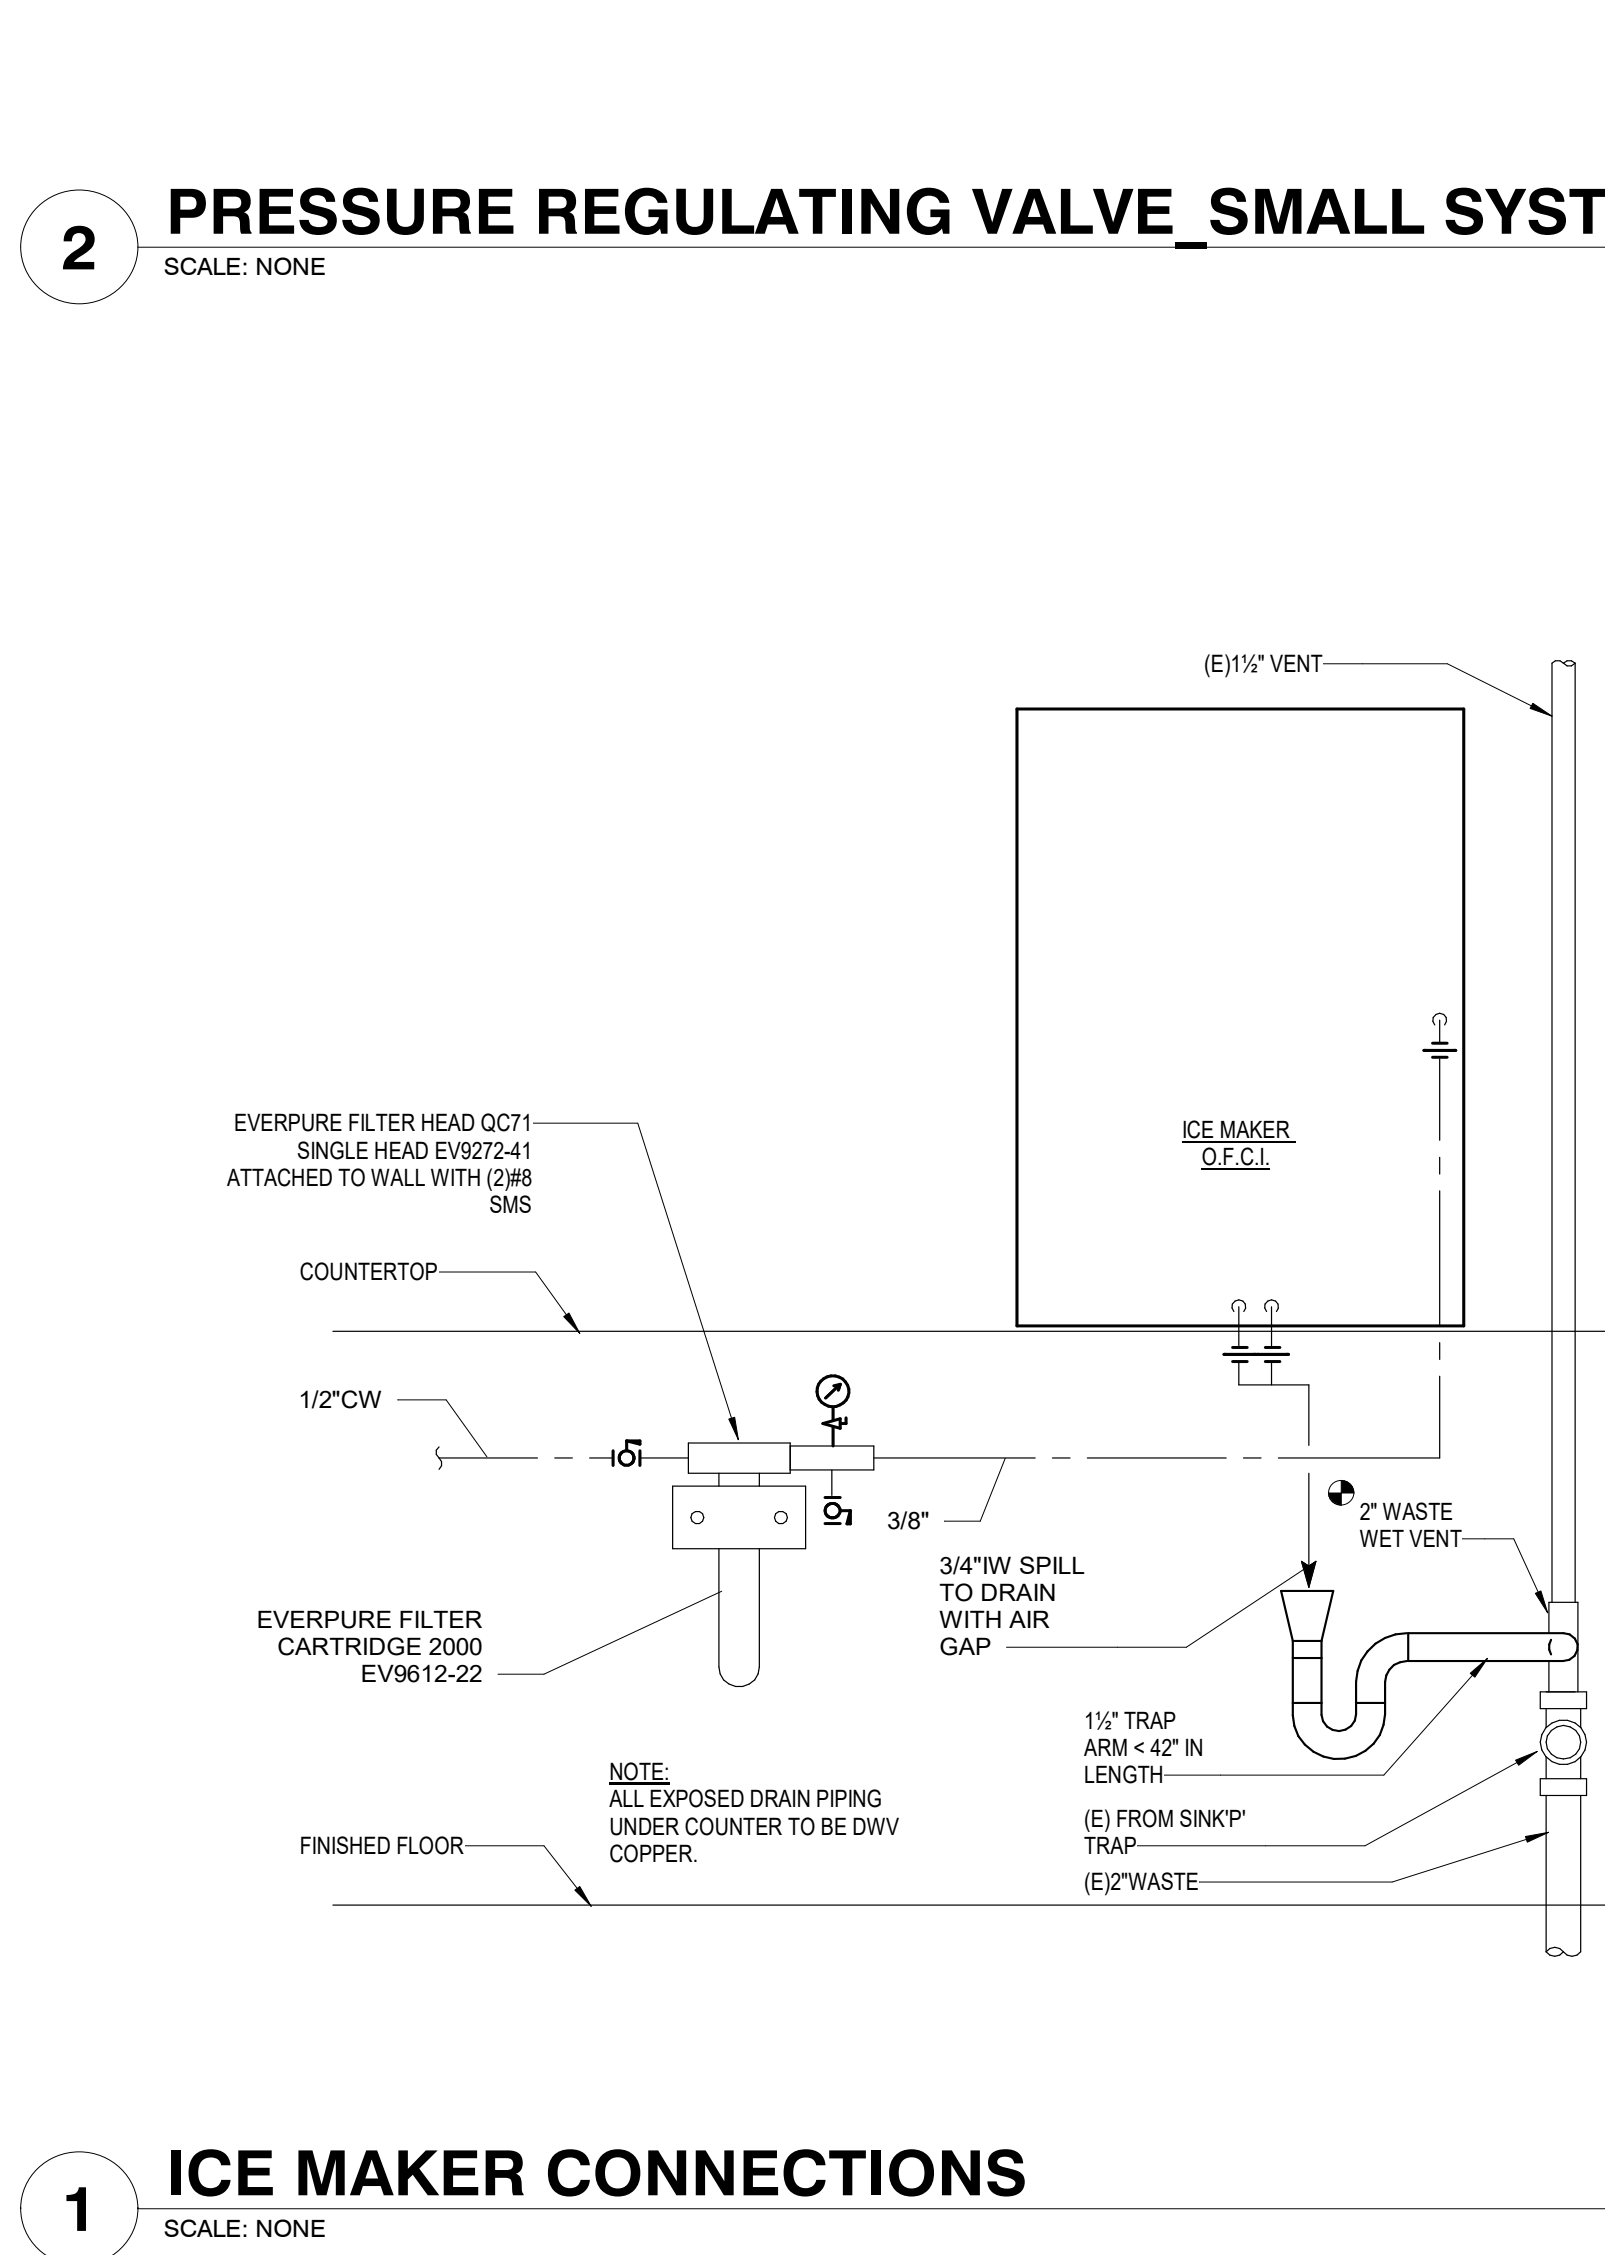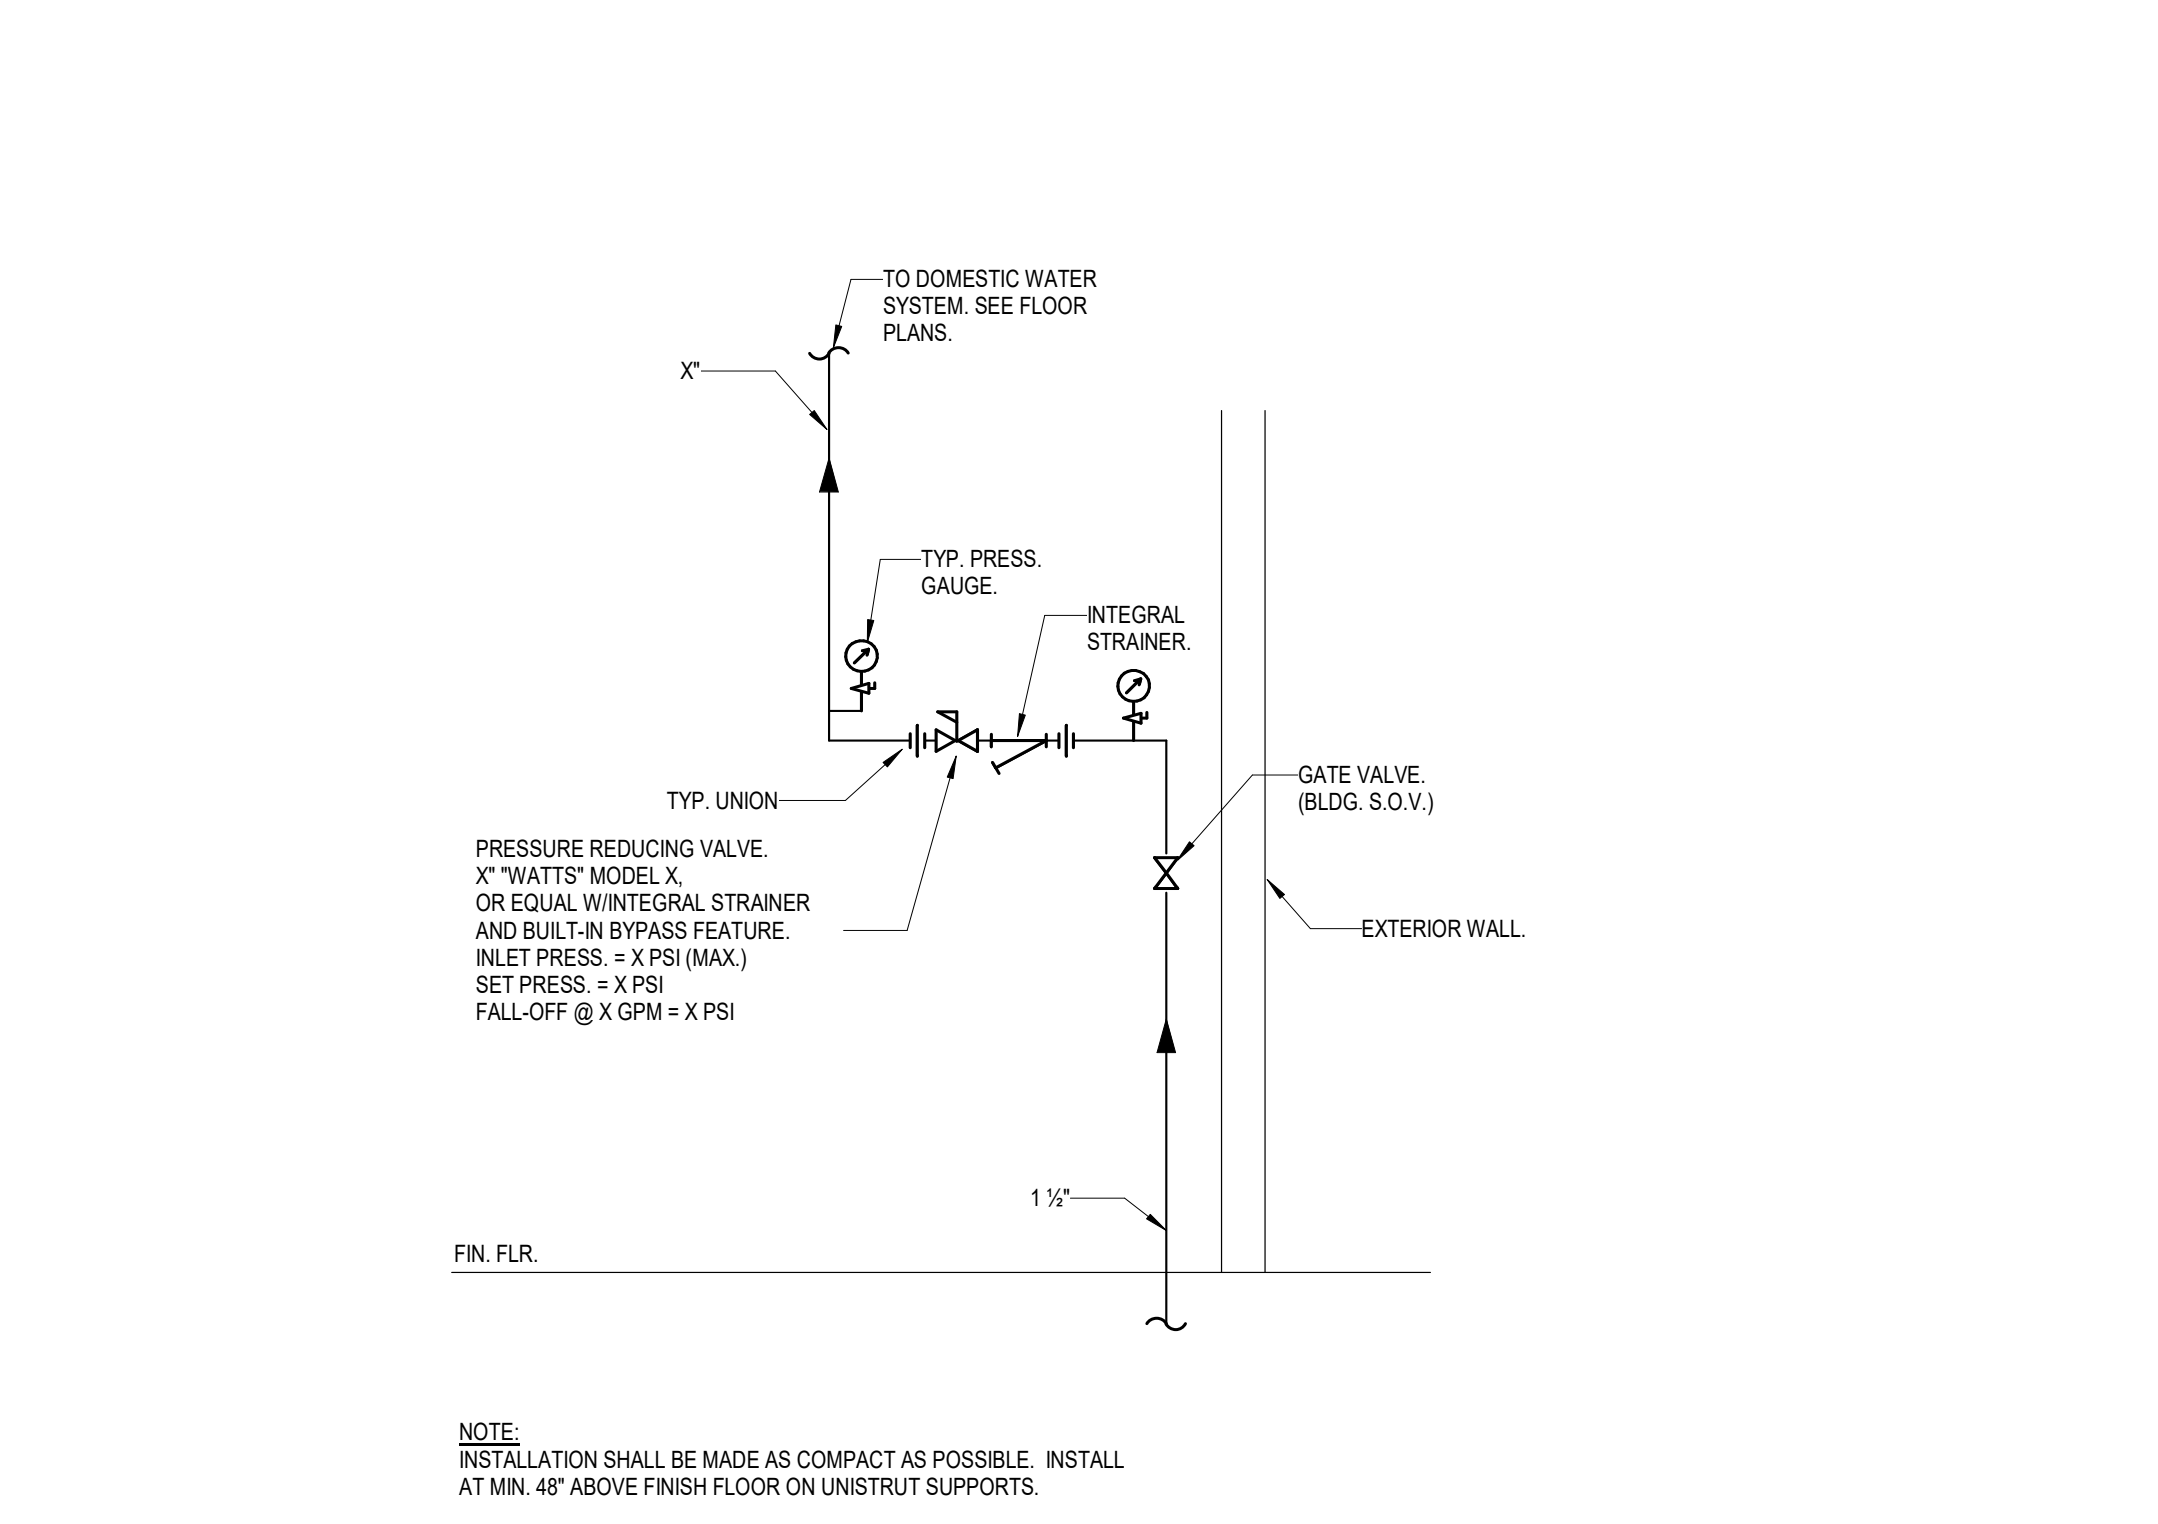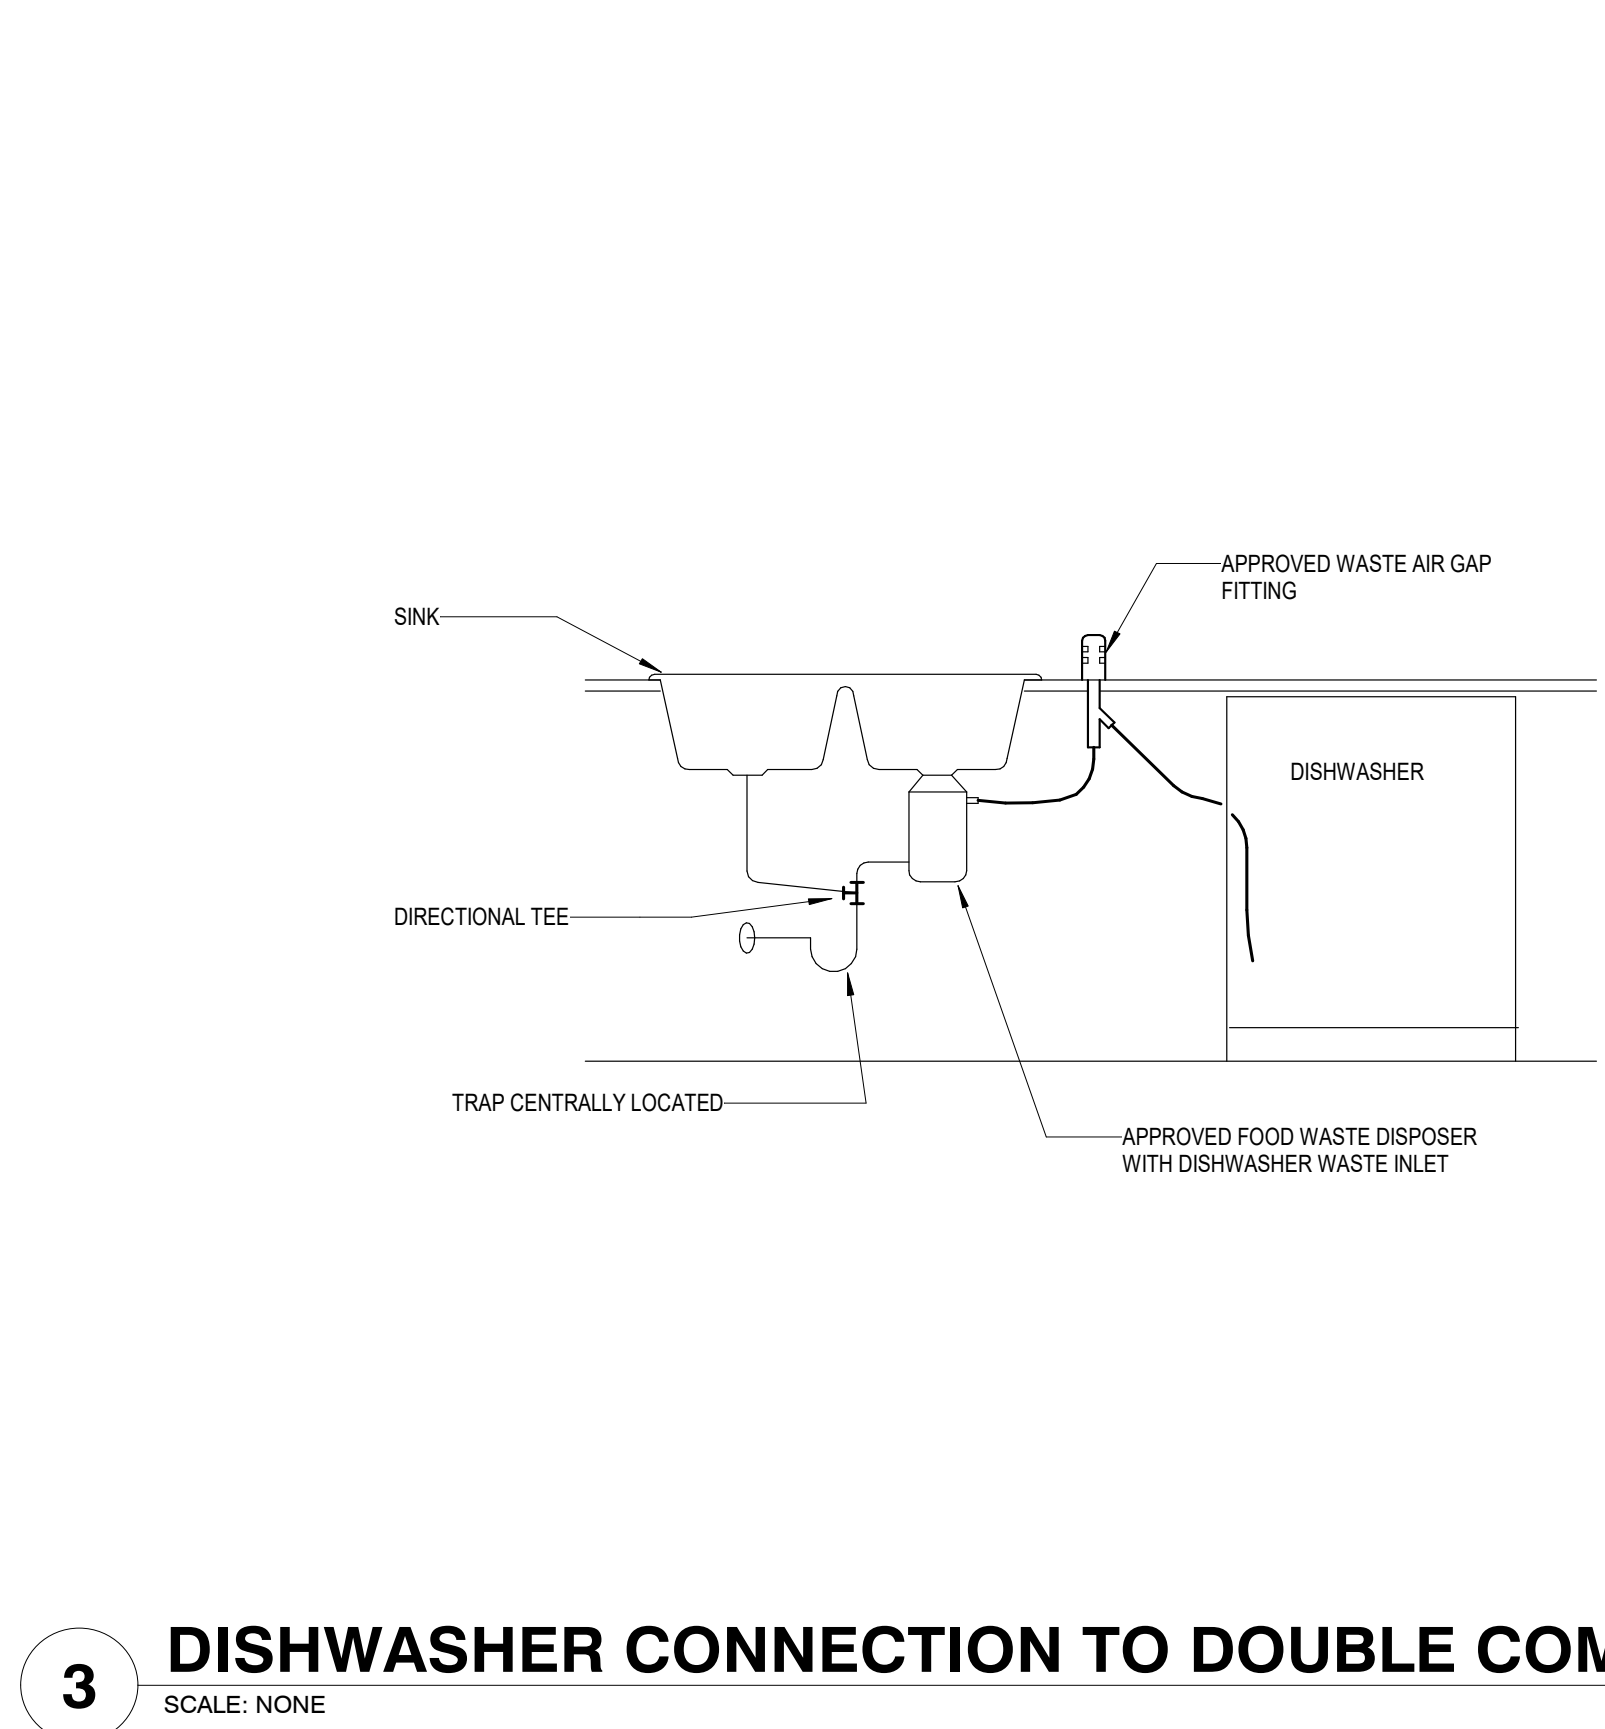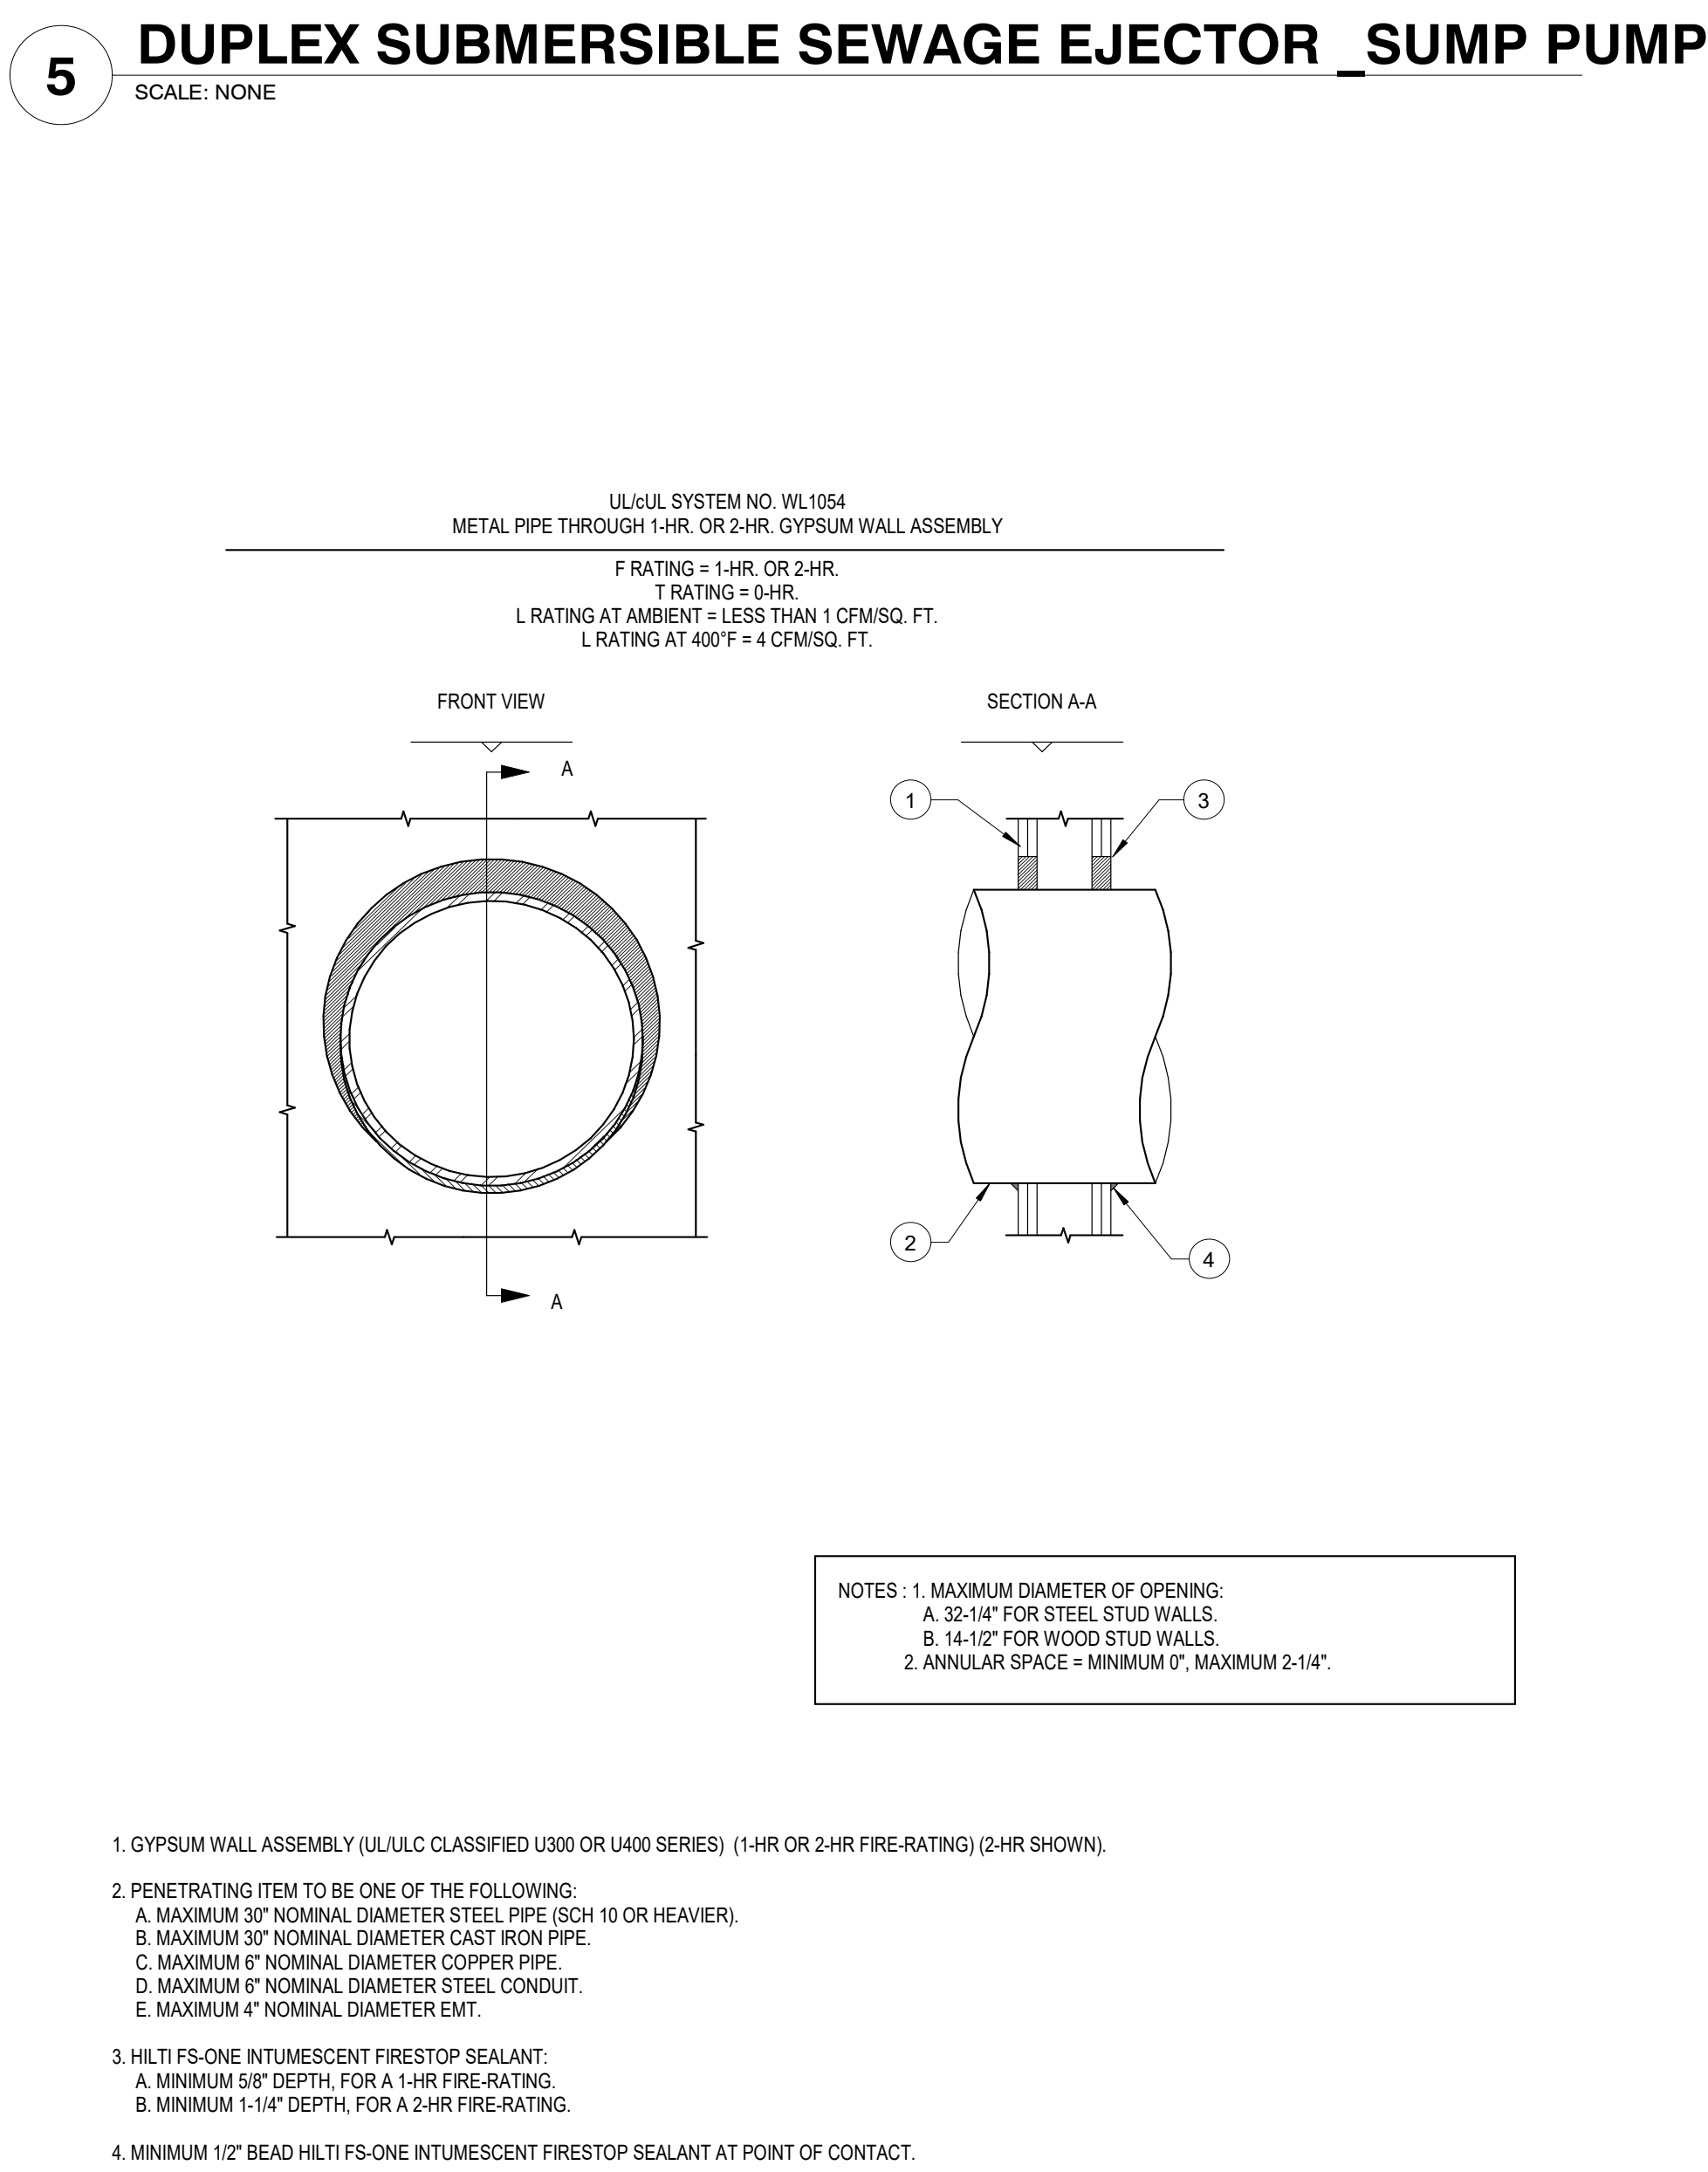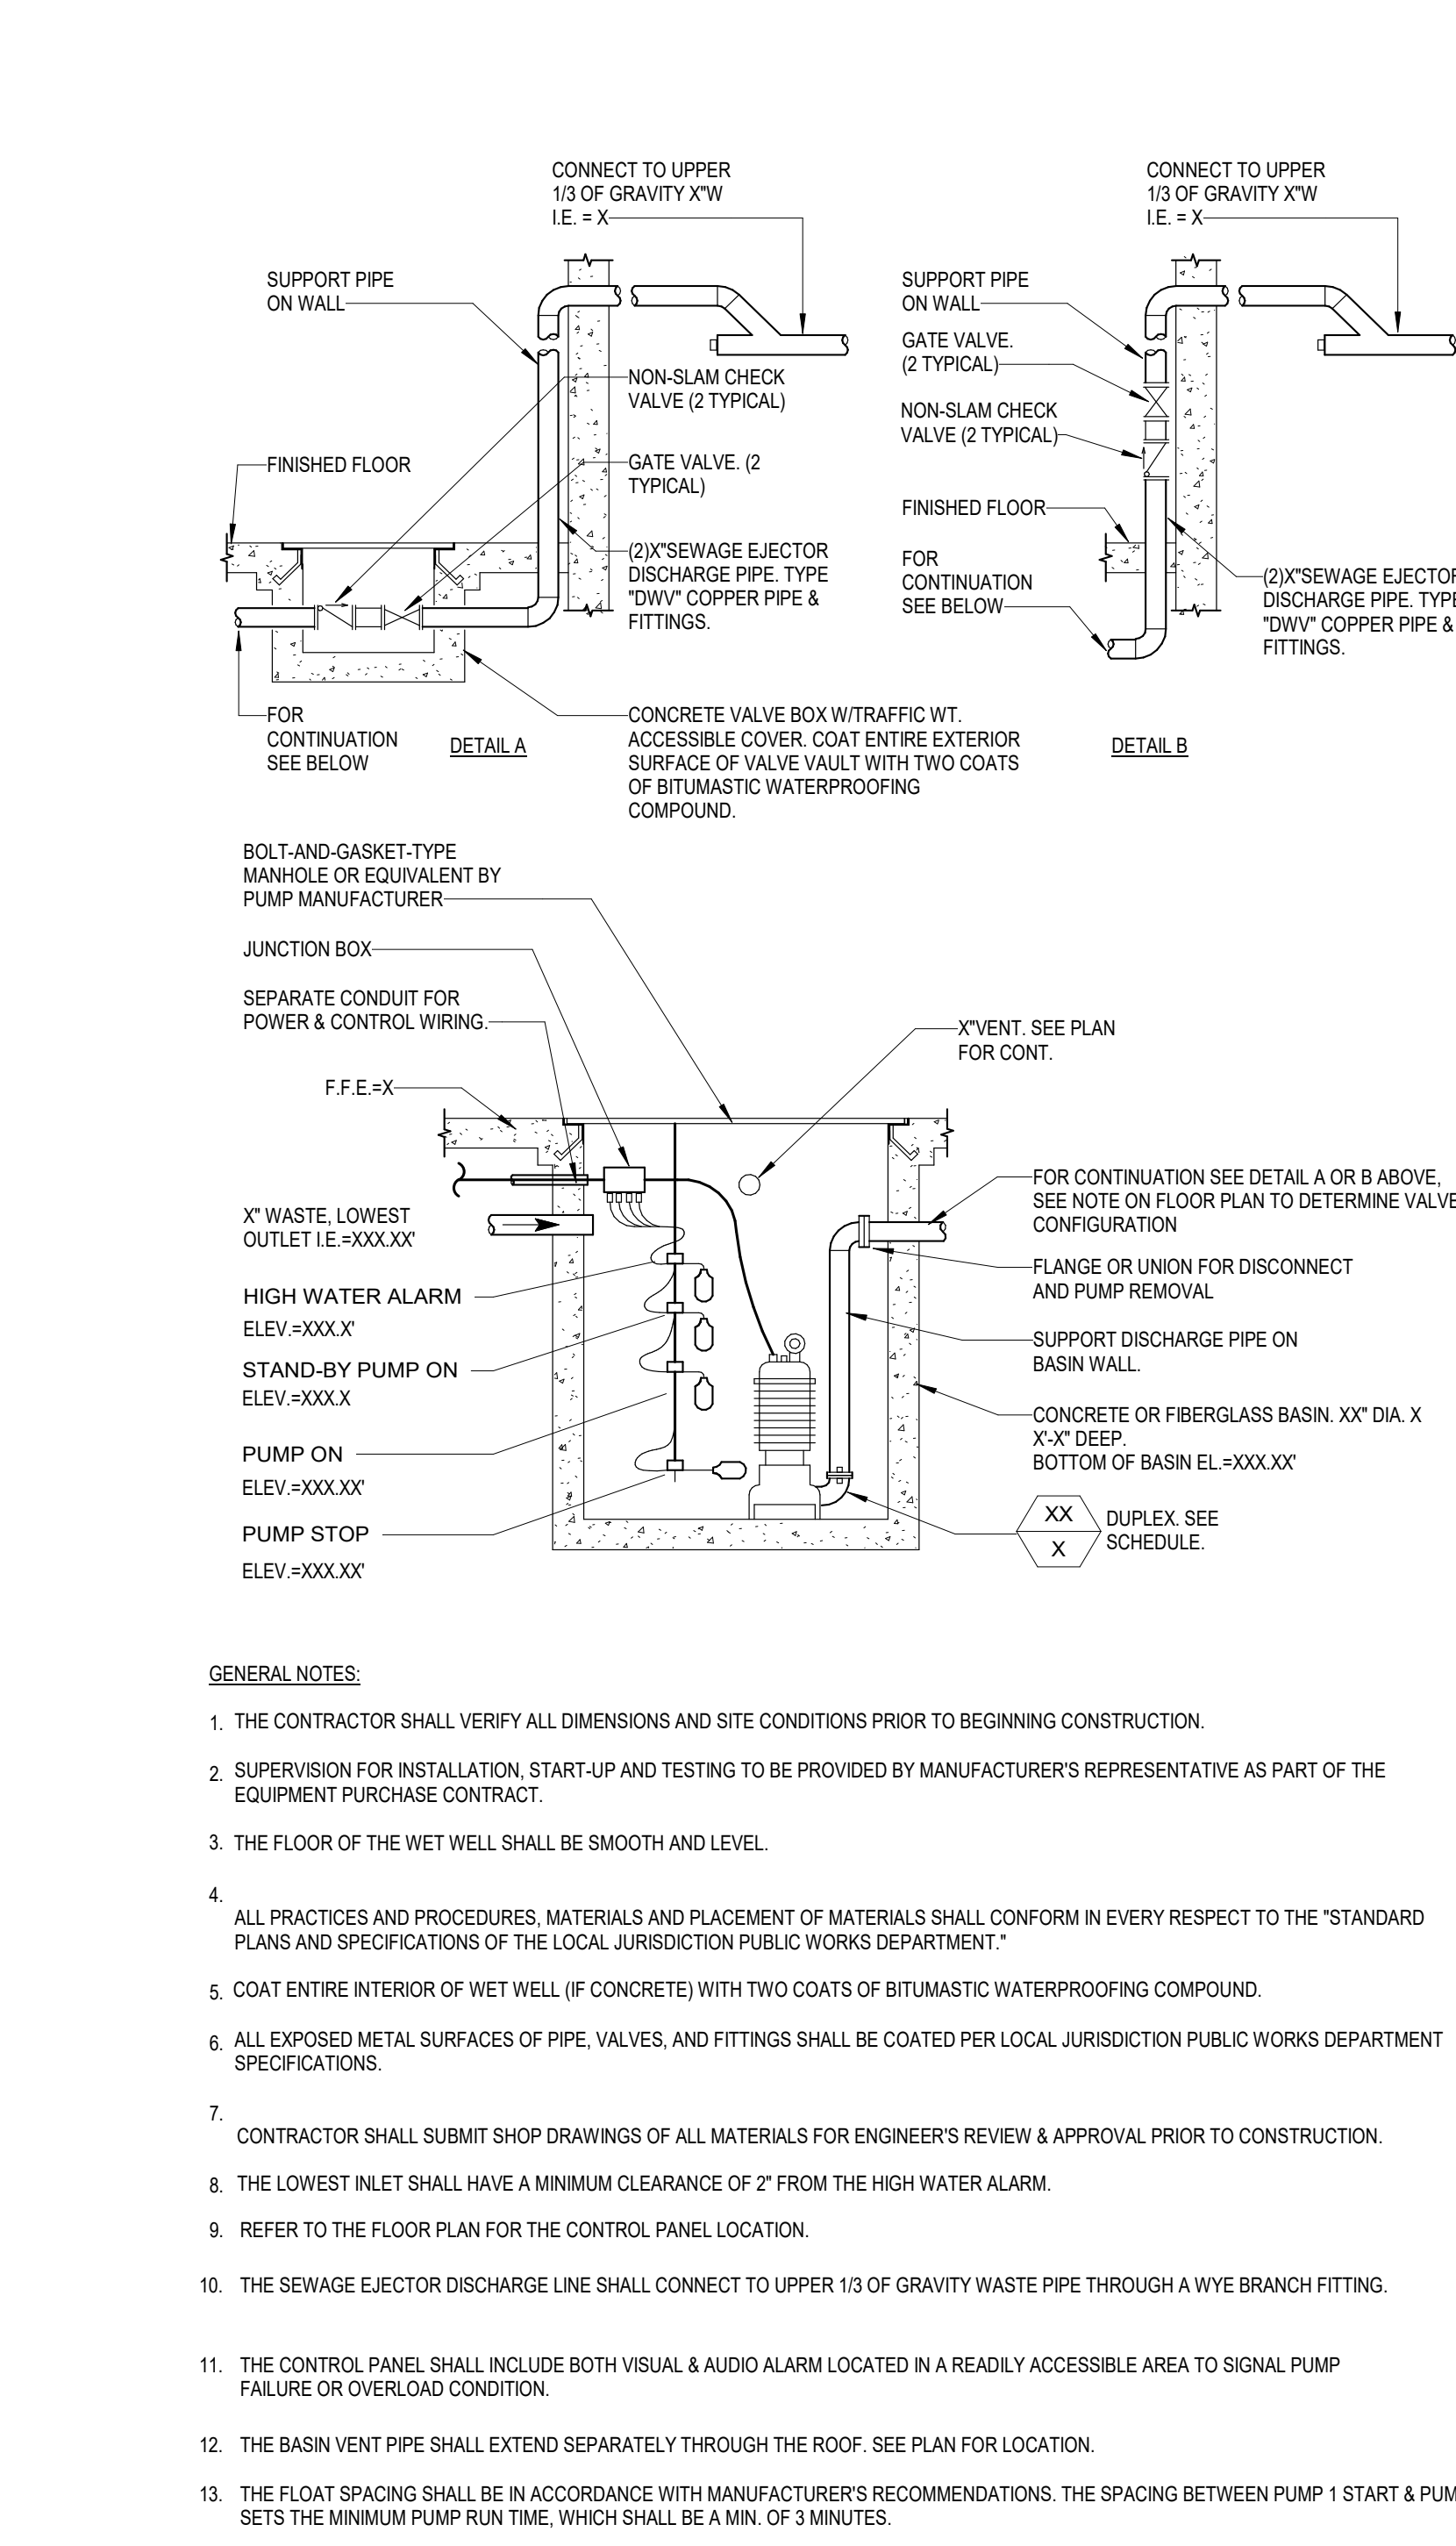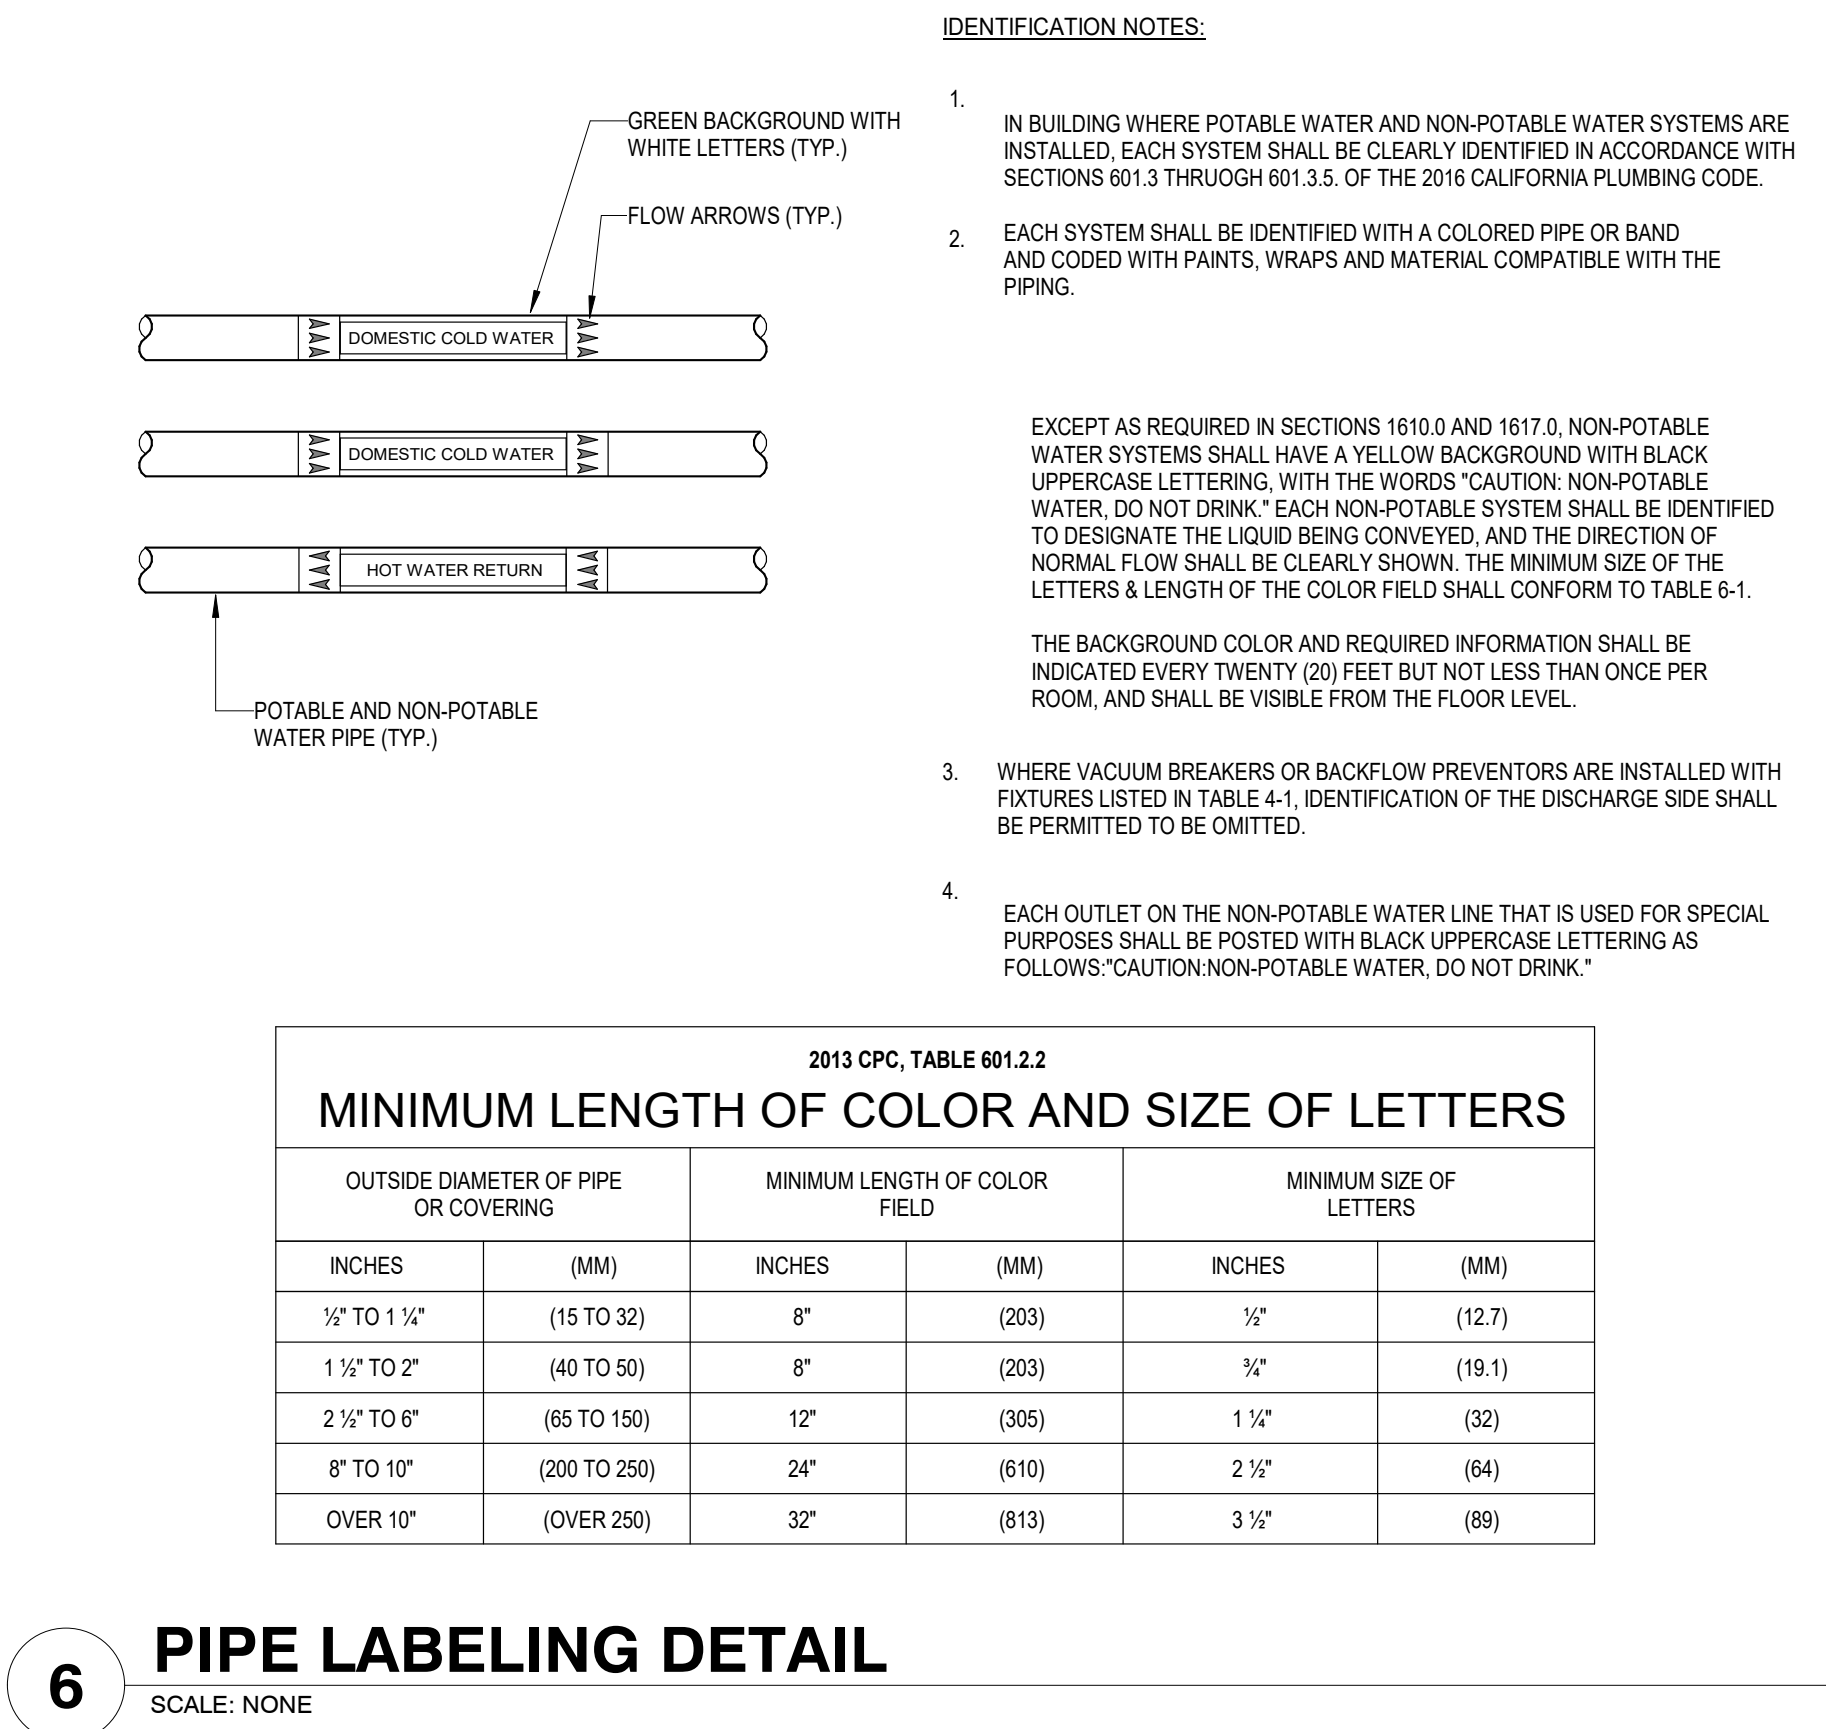

RESERVED FOR PERMIT STAMP

100 South Jackson St., Suite 600
Seattle, Washington 98101 USA
+1 206 834 6870 olsonkundig.com

Olson Kundig

PROJECT
Sommet Blanc - Bldg AB
DEER VALLEY, UTAH

Aspen Group USA, LLC
PO Box 980022
Park City, Utah 84098

Pool Consultant
Cloward H2O
2096 N University Ave., Suite 290
Provo, UT 84604

Landscape Architect
EPO Design
6949 South High Tech Drive, Suite 100
Midvale, Utah 84047

Specifications Writer
Friday Group
88 Marrett Road
Middlebury, VT

Code Consultant
Holmes
800 1st Avenue, Suite 200A
Seattle, WA 98104

Fire Protection Engineer
Jensen Hughes
One Research Drive, Suite 305C
Westborough, MA 01581

Vertical Transportation Consultant
Lerch Bates
19515 North Creek Parkway, Suite 304
Bellevue, WA 98011

Structural Engineer
Magnuson Hancock Associates
1301 6th Ave., Suite 3200
Seattle, WA 98101

Lighting Designer
O-
1319 SE MLK Blvd., Suite 210
Portland, Oregon 97219

Building Envelope Consultant
RDH
2101 N 34th St
Seattle, WA 98103

Accessibility Consultant
Studio Pacifica
2144 Westlake Ave N, Suite F
Seattle, WA 98109

MEP Engineer
WSP USA
1001 Fourth Ave., Suite 3100
Seattle, WA 98154

principal architect _____
project manager _____
drawn by _____
checked by _____
job no. 2021-0595
date 5/17/2024




revisions:

1 10/05/2022 PERMIT RESUBMITTAL

no. date by


IFC Set 2 of 3
5/17/2024

DETAILS
P6.02

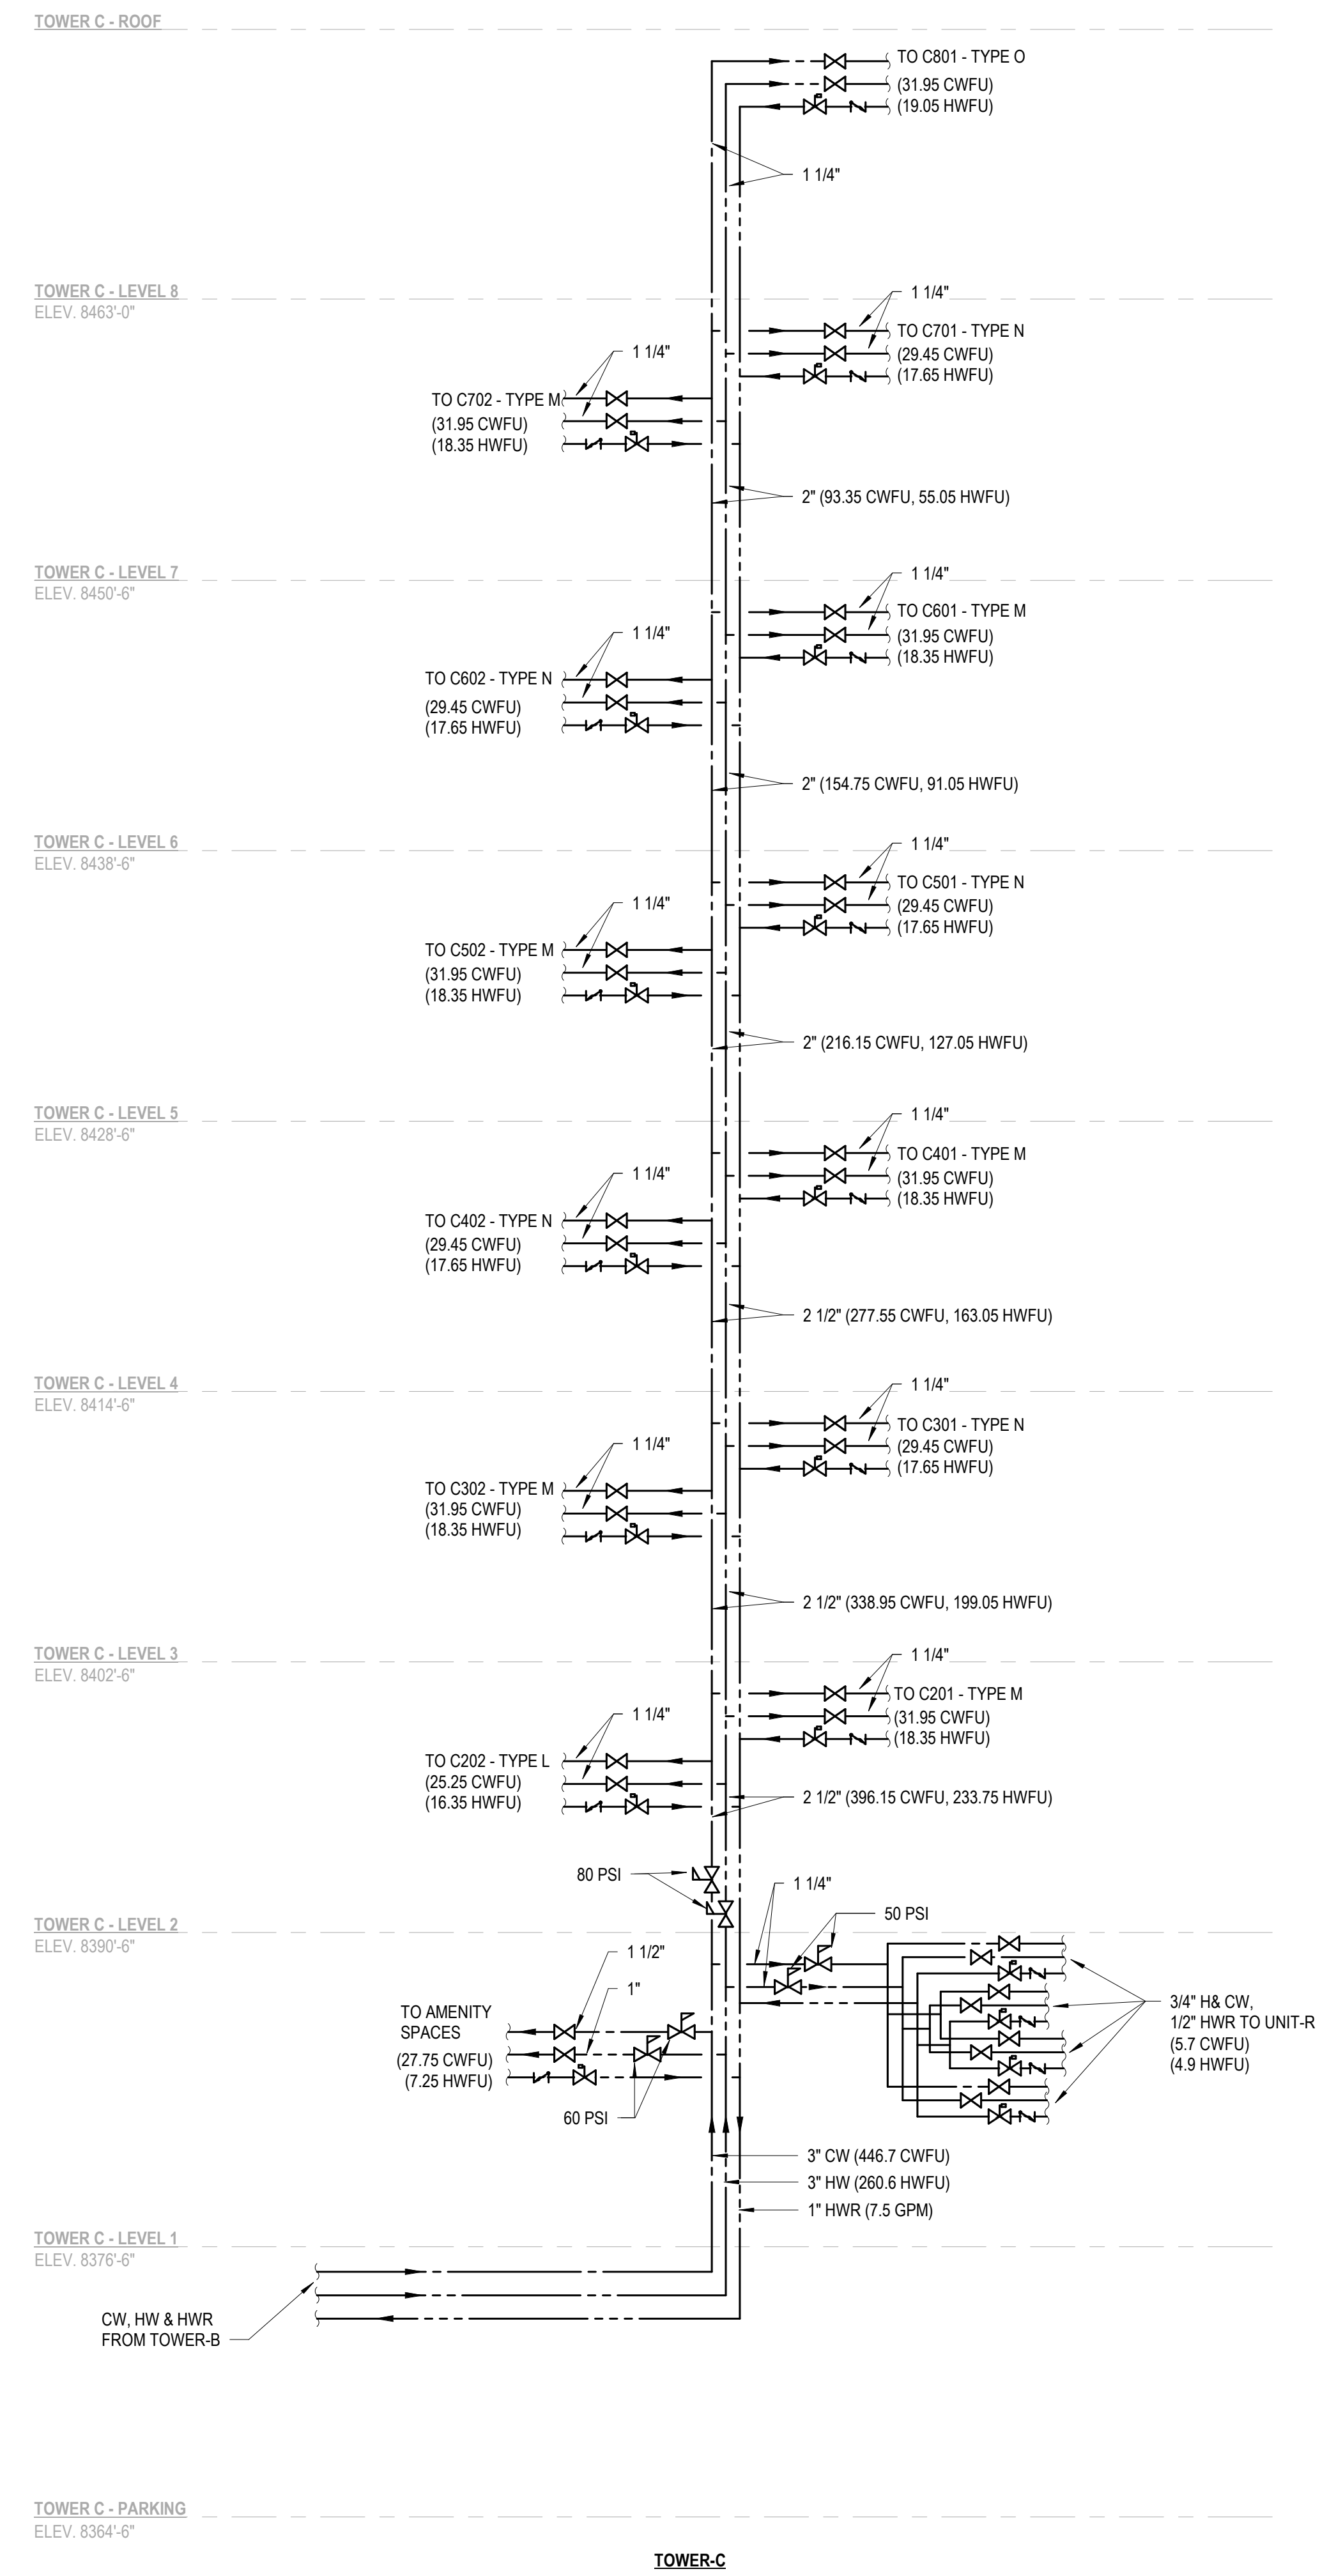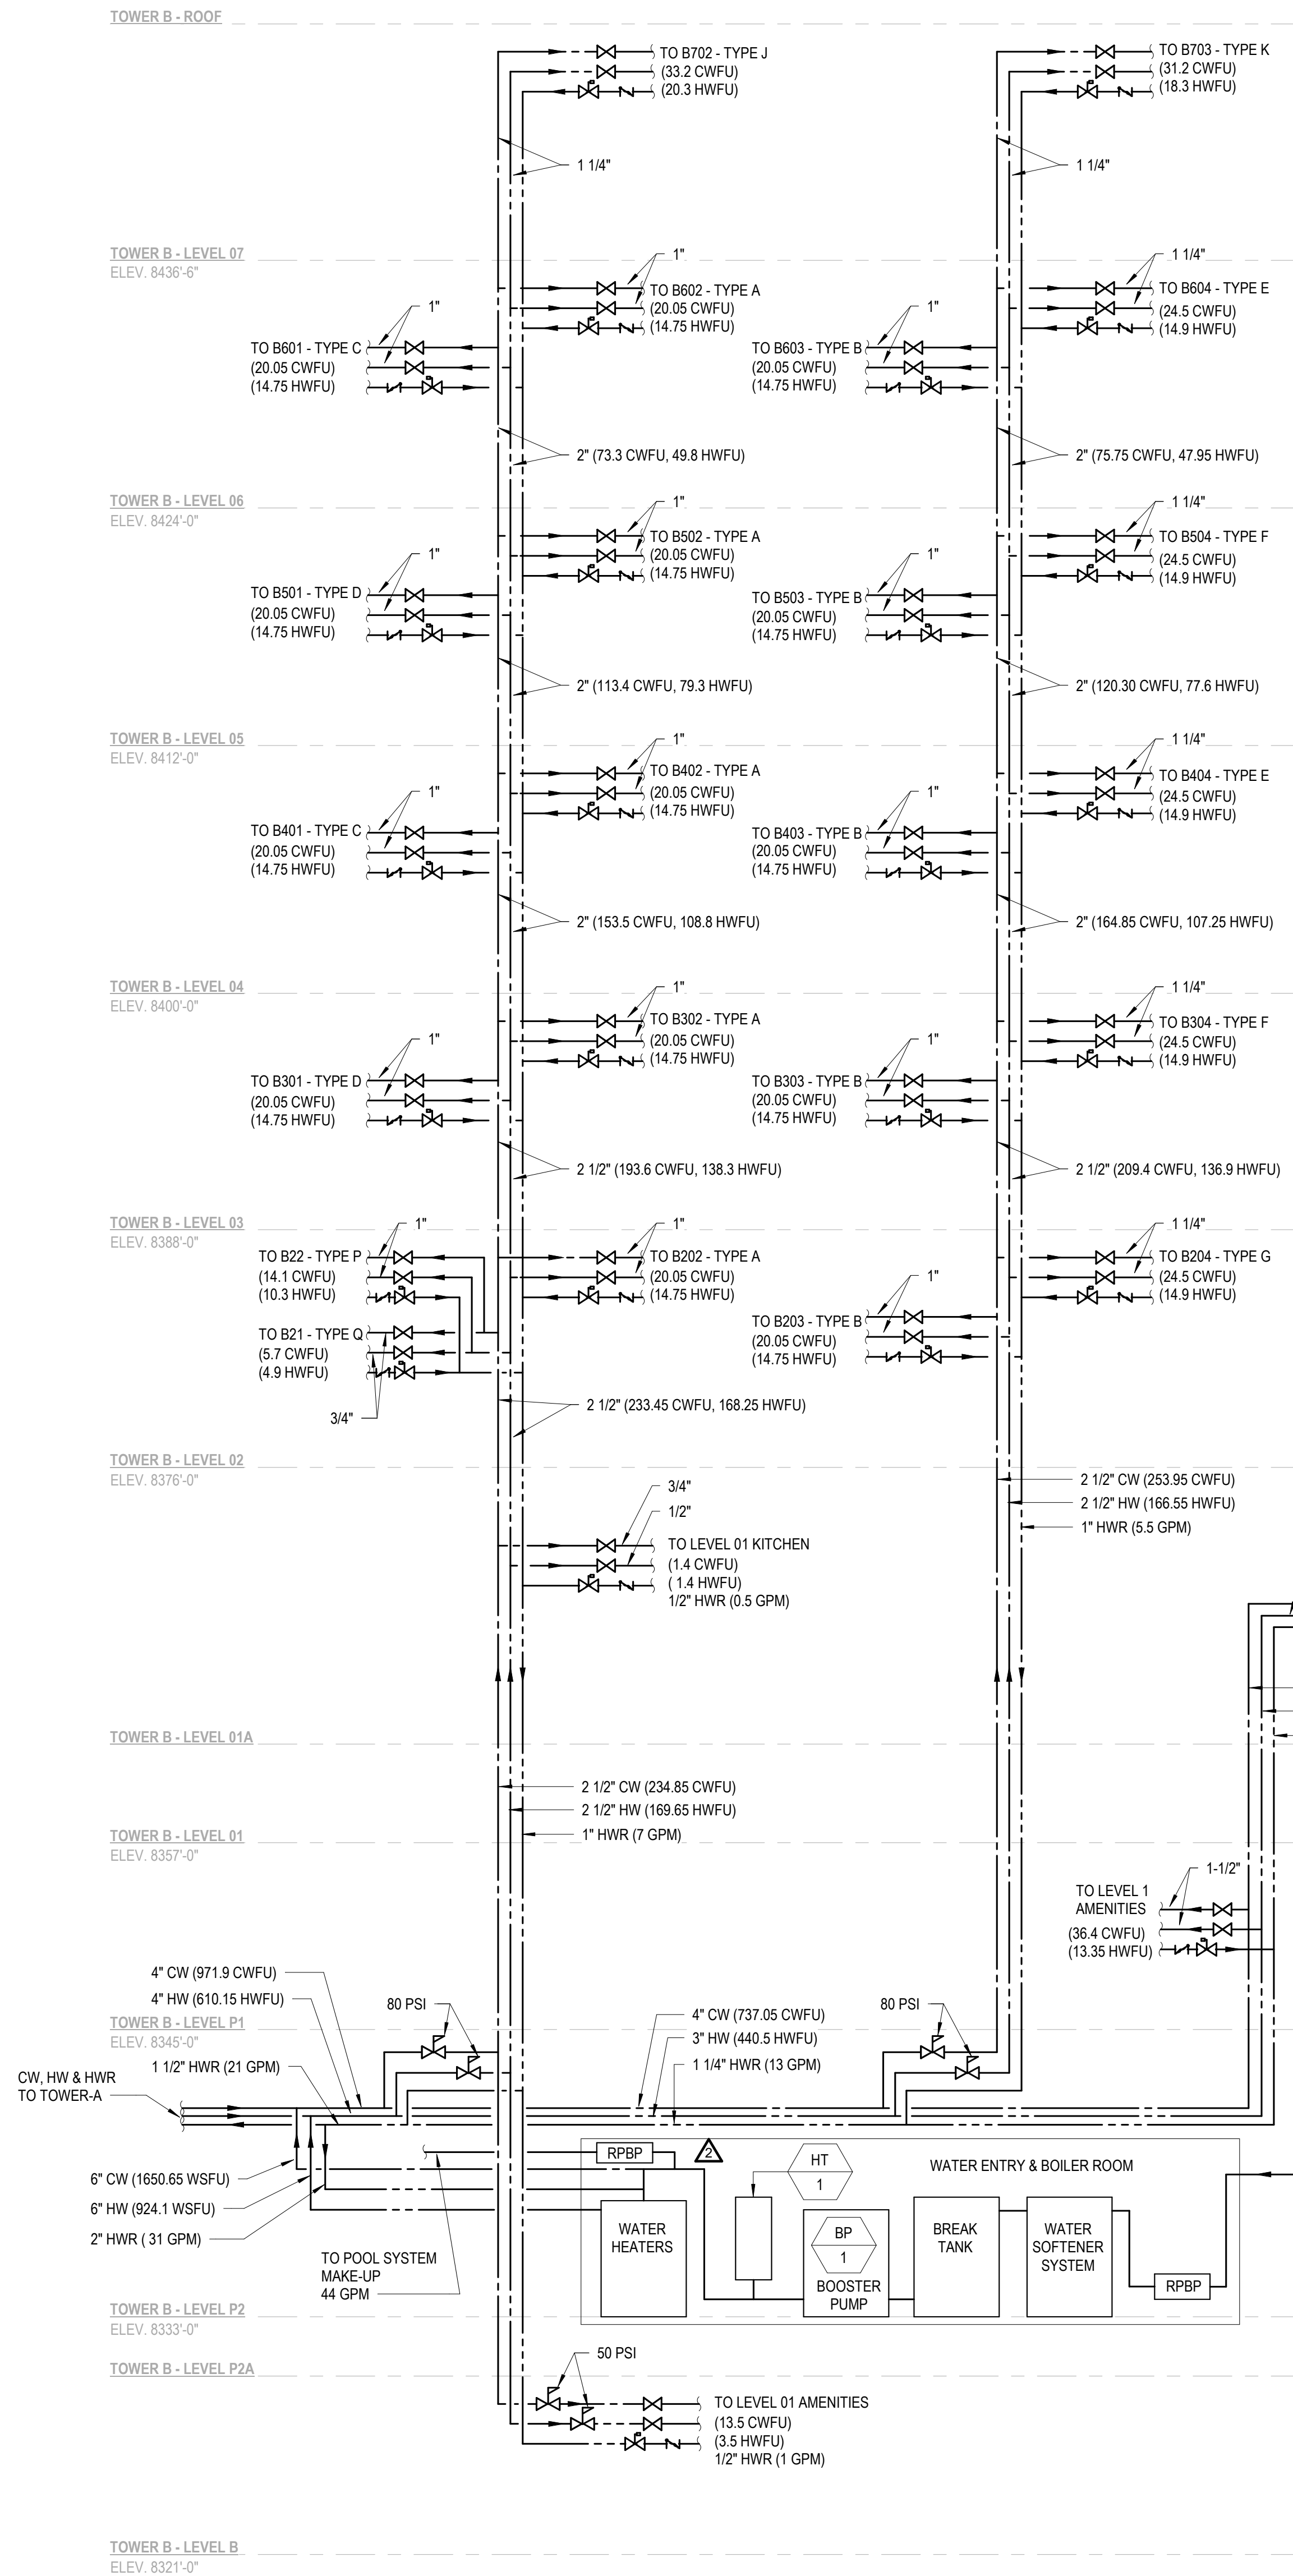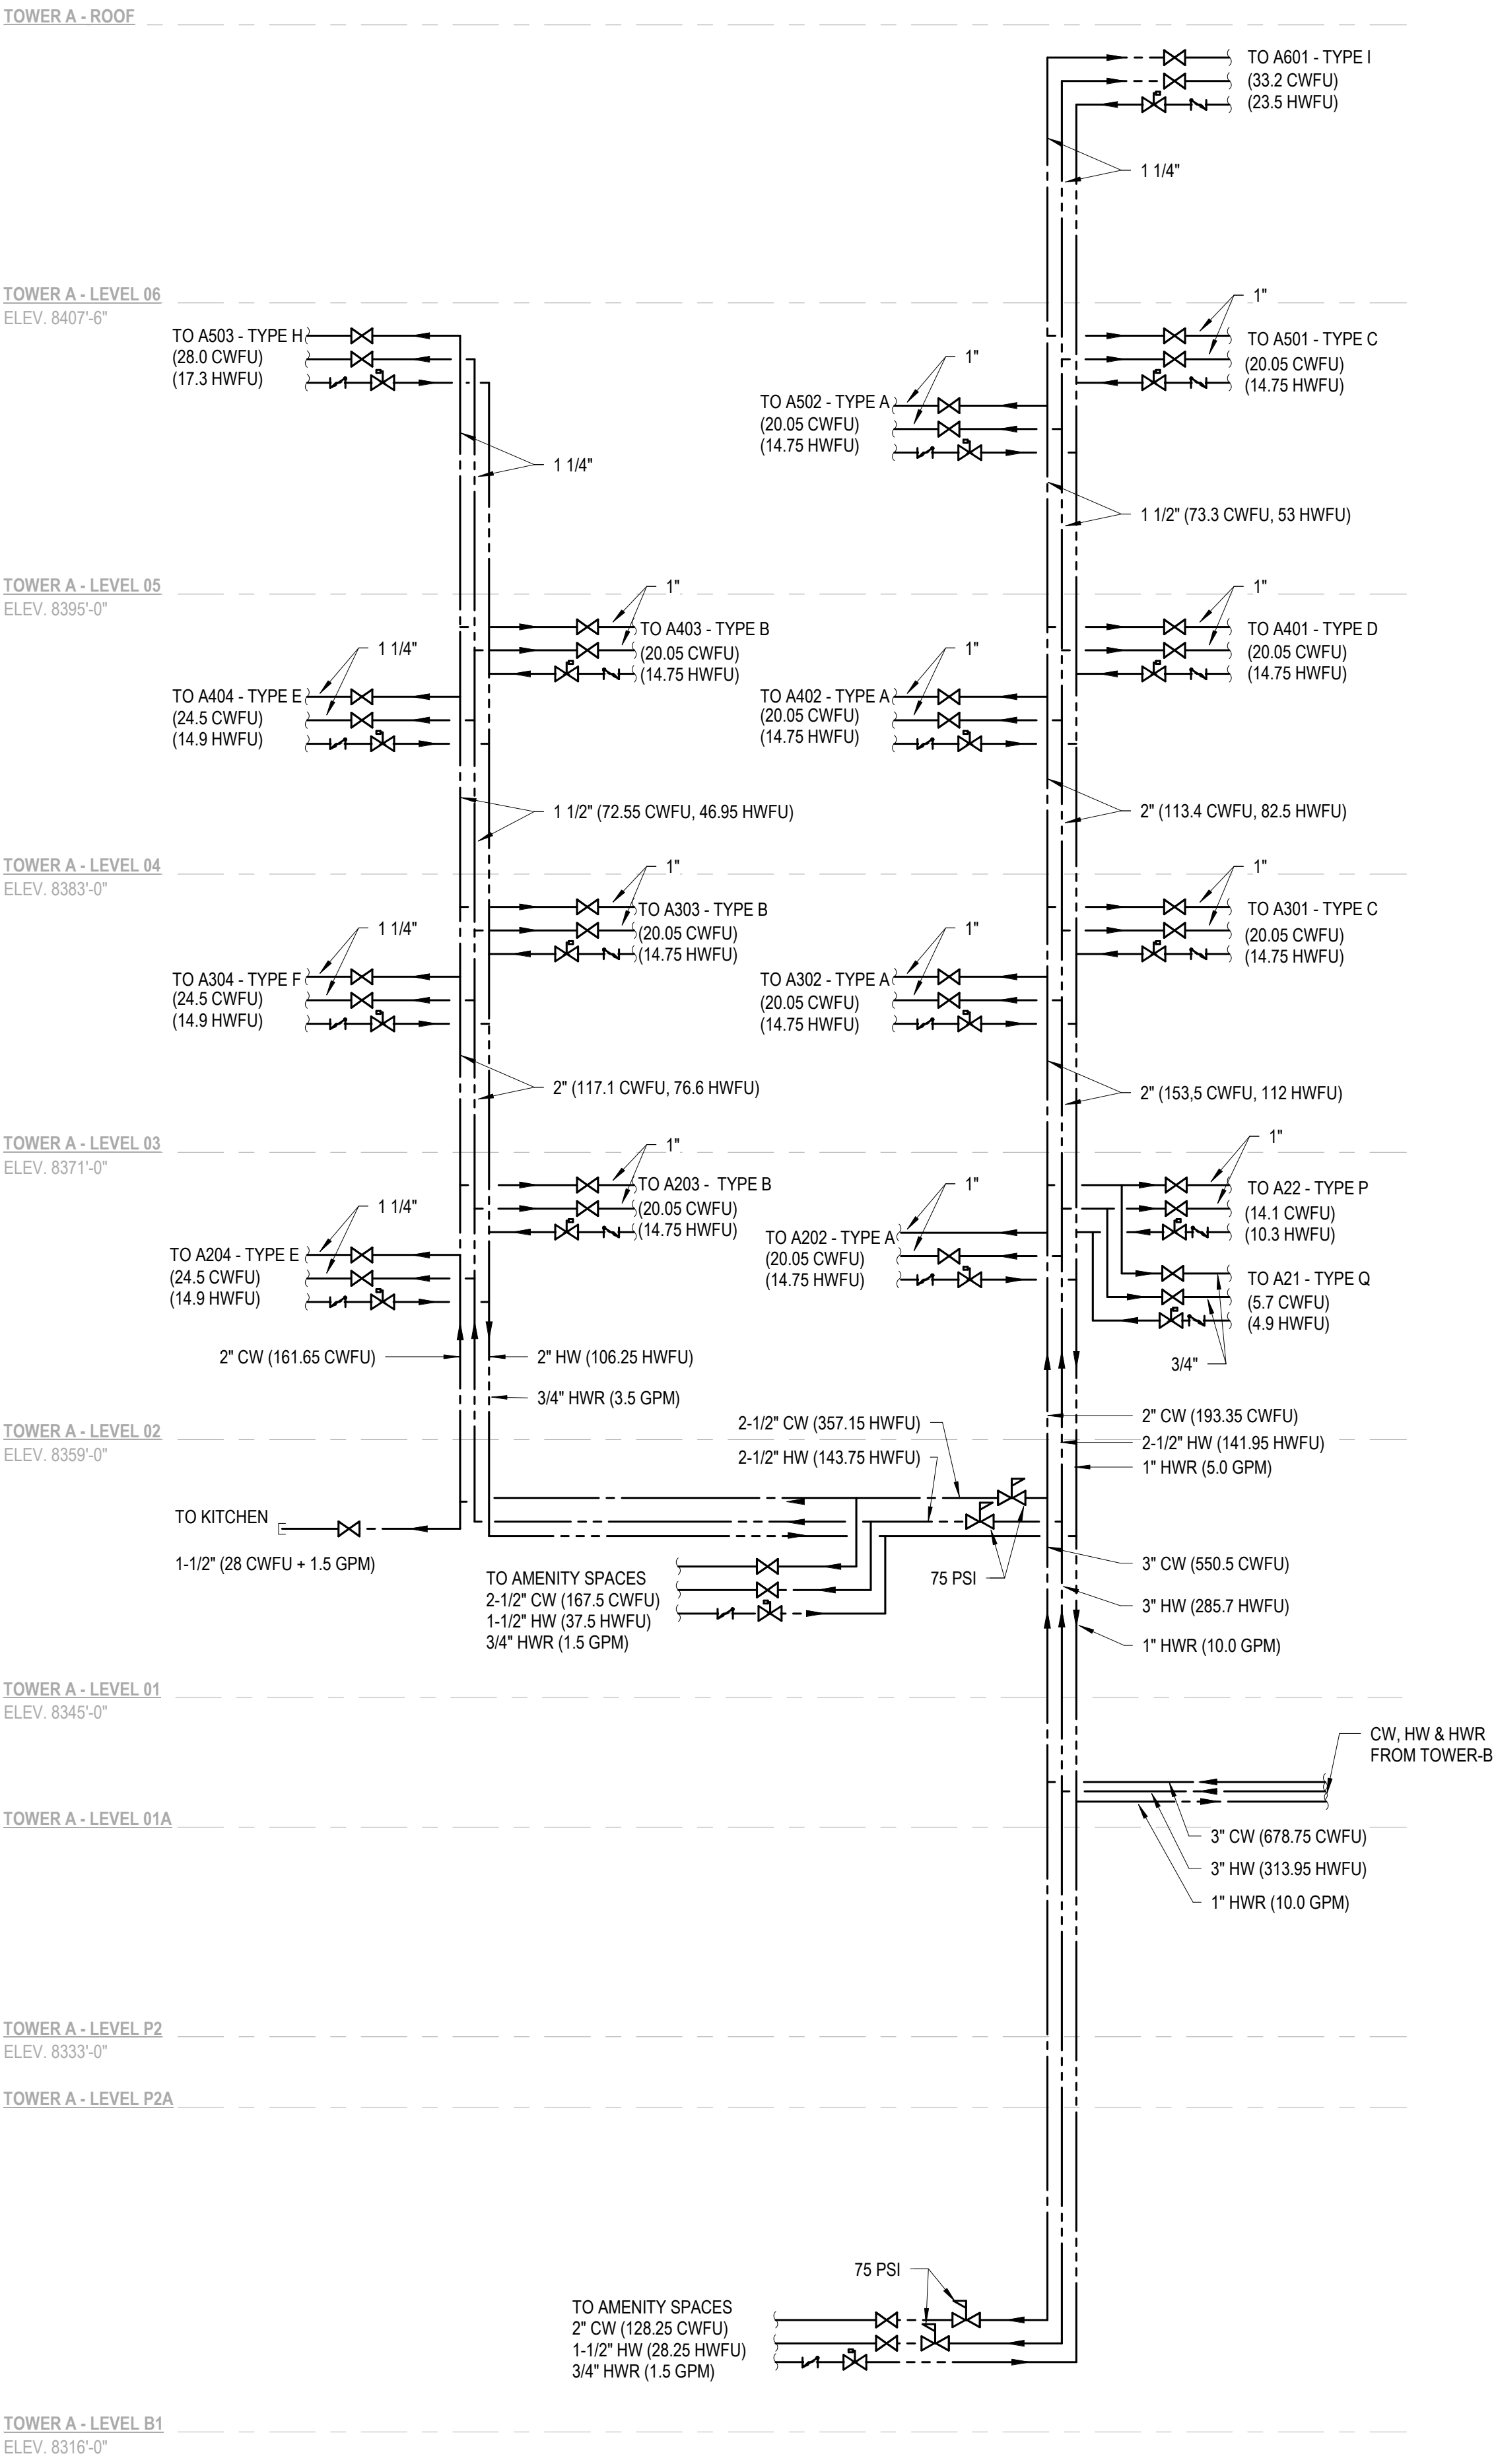

NOTES:
FOR CW, HW & HWR SIZES WITHIN INDIVIDUAL UNITS PLEASE REFER
TO UNIT PLANS.

1 DOMESTIC WATER RISER
SCALE: NTS

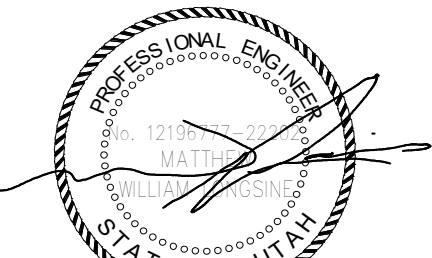

Reserved for permit stamp

100 South Jackson St., Suite 600
Seattle, Washington 98101 USA
+1 206 834 6070 olsonkundig.com

Olson Kundig

PROJECT
Sommet Blanc - Bldg AB
DEER VALLEY, UTAH



Aspen Group USA, LLC
PO Box 980022
Park City, Utah 84098

Pool Consultant
Cloward H2O
2096 N University Ave, Suite 290
Provo, UT 84604

Landscape Architect
EPG Design
6949 South High Tech Drive, Suite 100
Midvale, Utah 84047

Specifications Writer
Fridley Group
88 Marietti Road
Medford, VT

Code Consultant
Holmes
800 1st Avenue, Suite 200A
Seattle, WA 98104

Fire Protection Engineer
Jensen Hughes
One Research Drive, Suite 305C
Westborough, MA 01581

Vertical Transportation Consultant
Lerch Bates
19515 North Creek Parkway, Suite 304
Bellevue, WA 98011

Structural Engineer
Magnuson Homecare Associates
1301 6th Ave, Suite 3200
Seattle, WA 98101

Lighting Designer
O
1319 SE MLK Blvd, Suite 210
Portland, Oregon 97219

Building Envelope Consultant
RDH
2101 N 34th St
Seattle, WA 98103

Accessibility Consultant
Studio Pacifica
2144 Westlake Ave N, Suite F
Seattle, WA 98109

MEP Engineer
WSP USA
1001 Fourth Ave., Suite 3100
Seattle, WA 98154

principal architect _____
project manager _____
drawn by _____
checked by _____
job no. 2021-0595
date 5/17/2024

revisions:
2 5/05/2023 PERMIT COMMENT
RESPONSE


no. date by

IFC Set 2 of 3
5/17/2024


DOMESTIC WATER
RISER DIAGRAM

P7.01


NOTE: SANITARY AND VENT STACKS WILL UNDERGO DIVERSIONS IF THE TYPICAL UNIT PLANS ARE NOT STACKED BETWEEN CONSECUTIVE LEVELS.

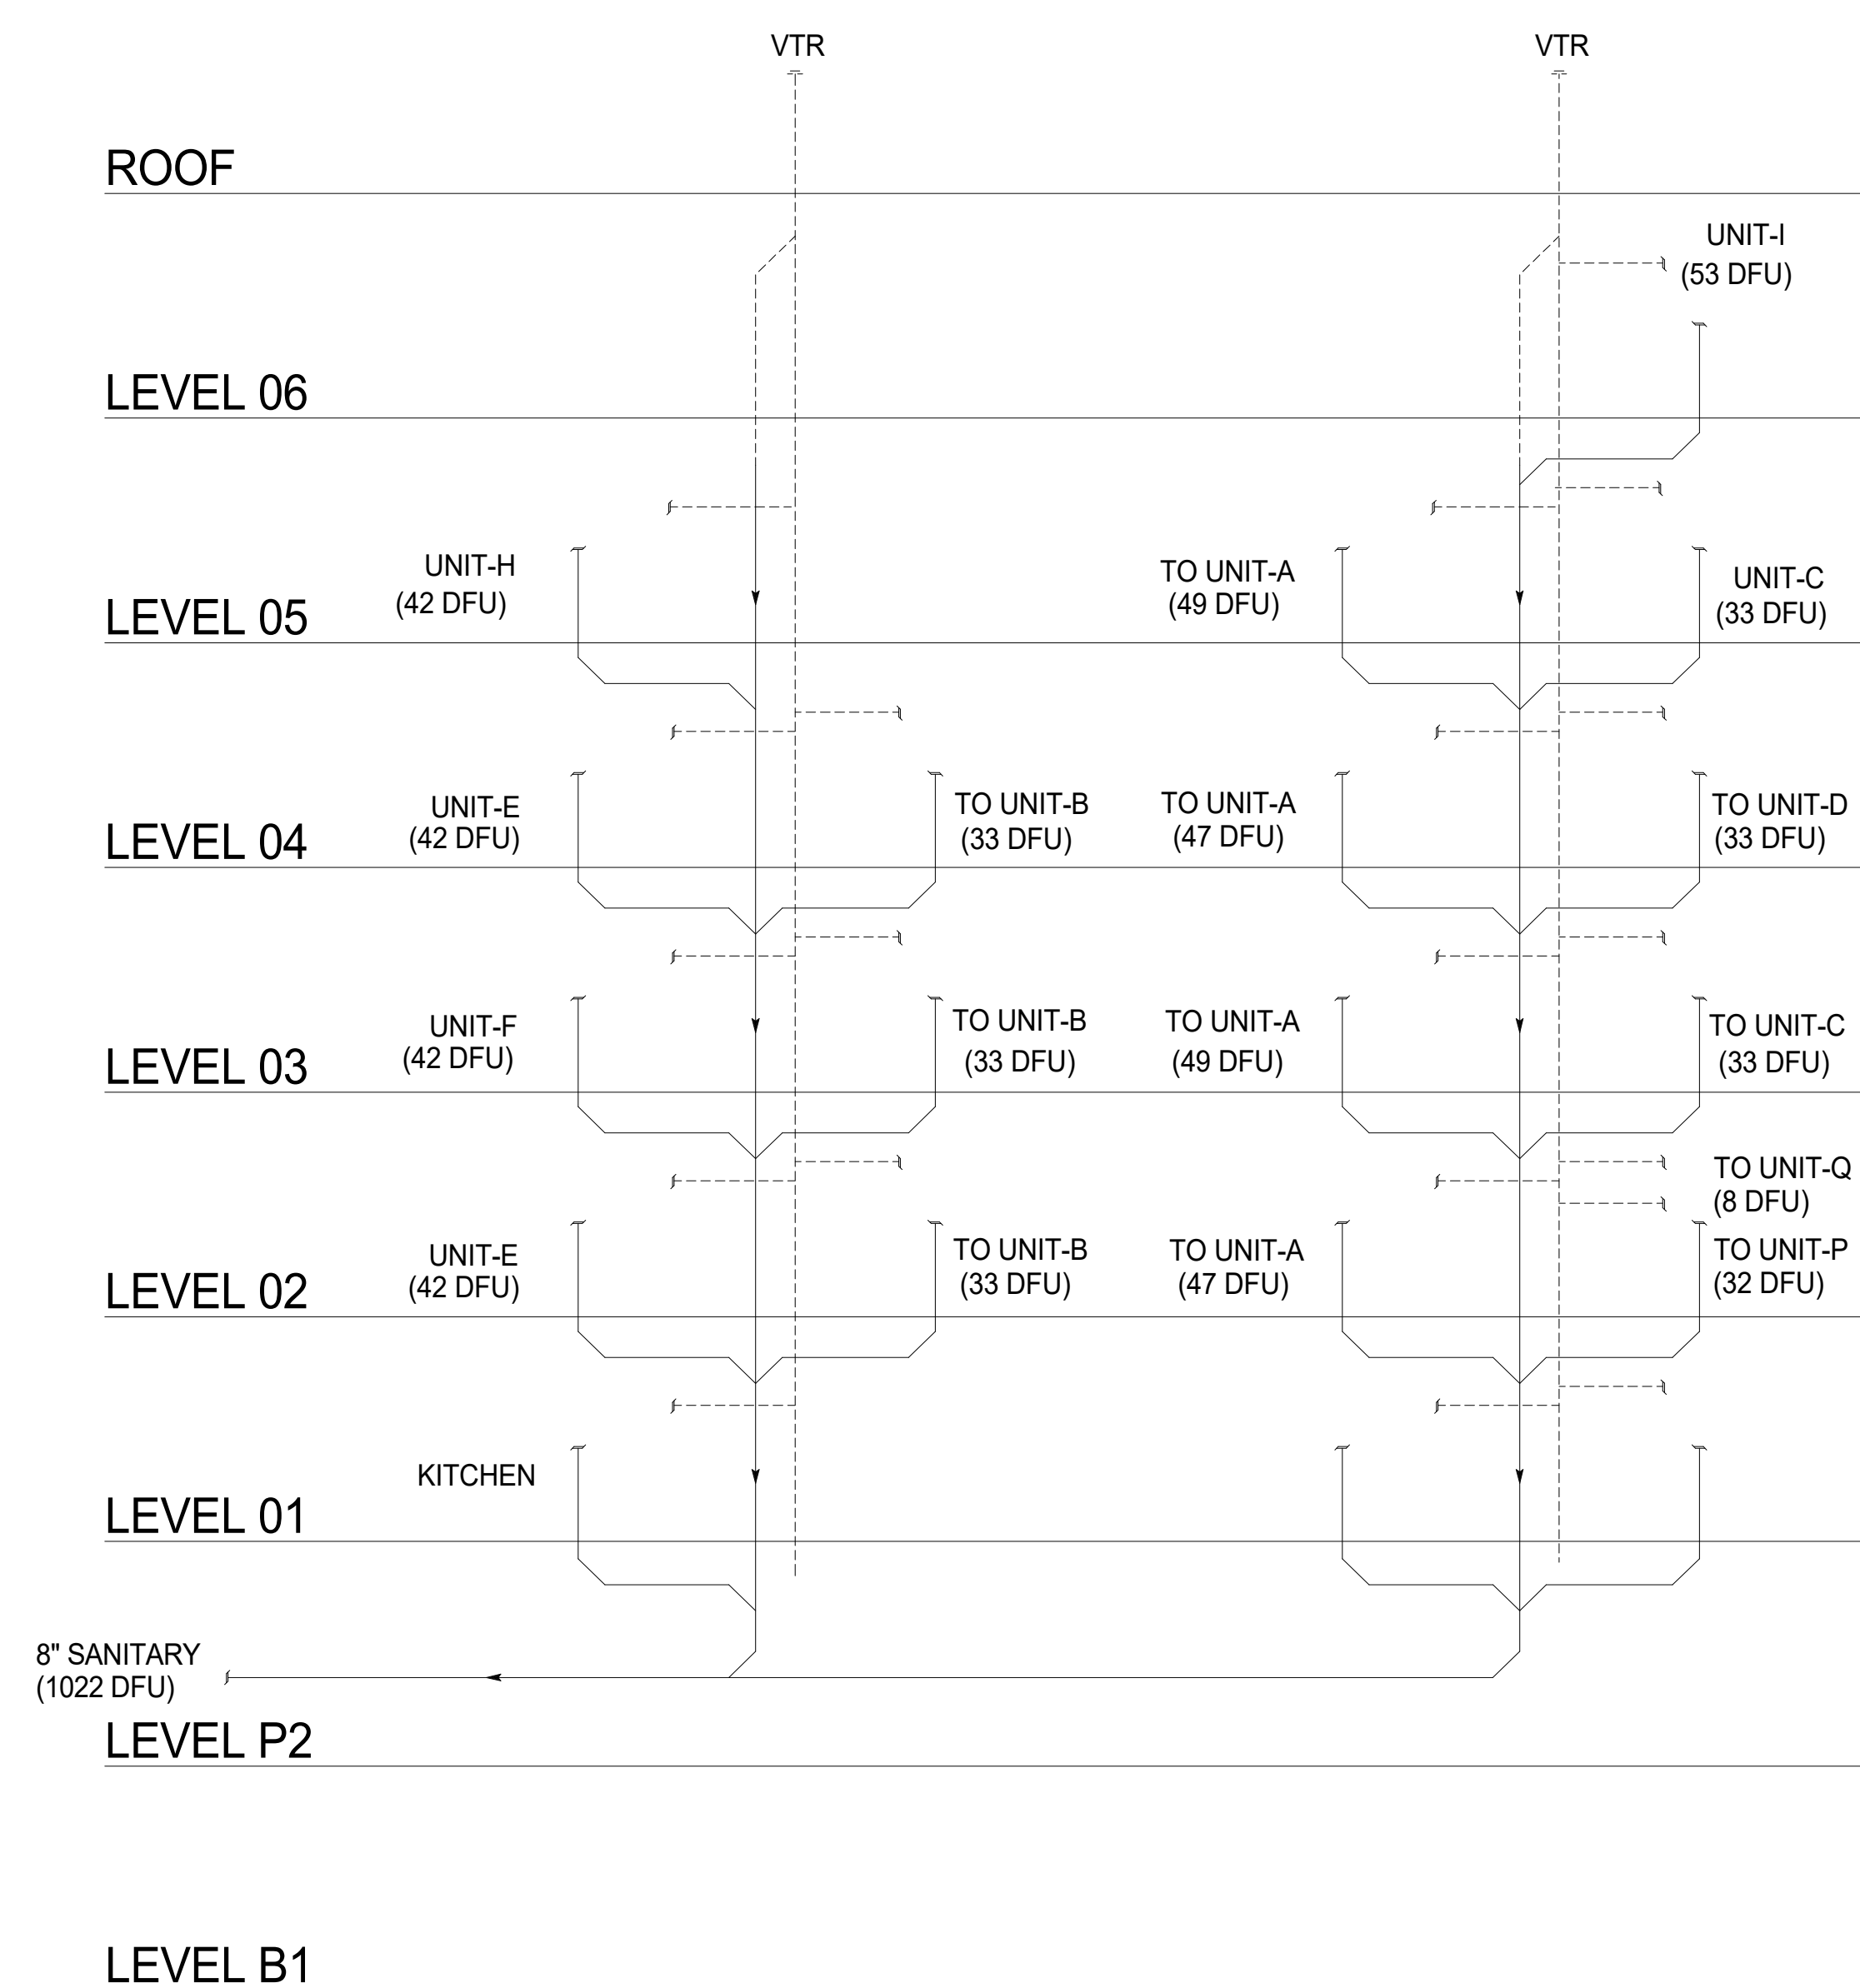

TOWER-A

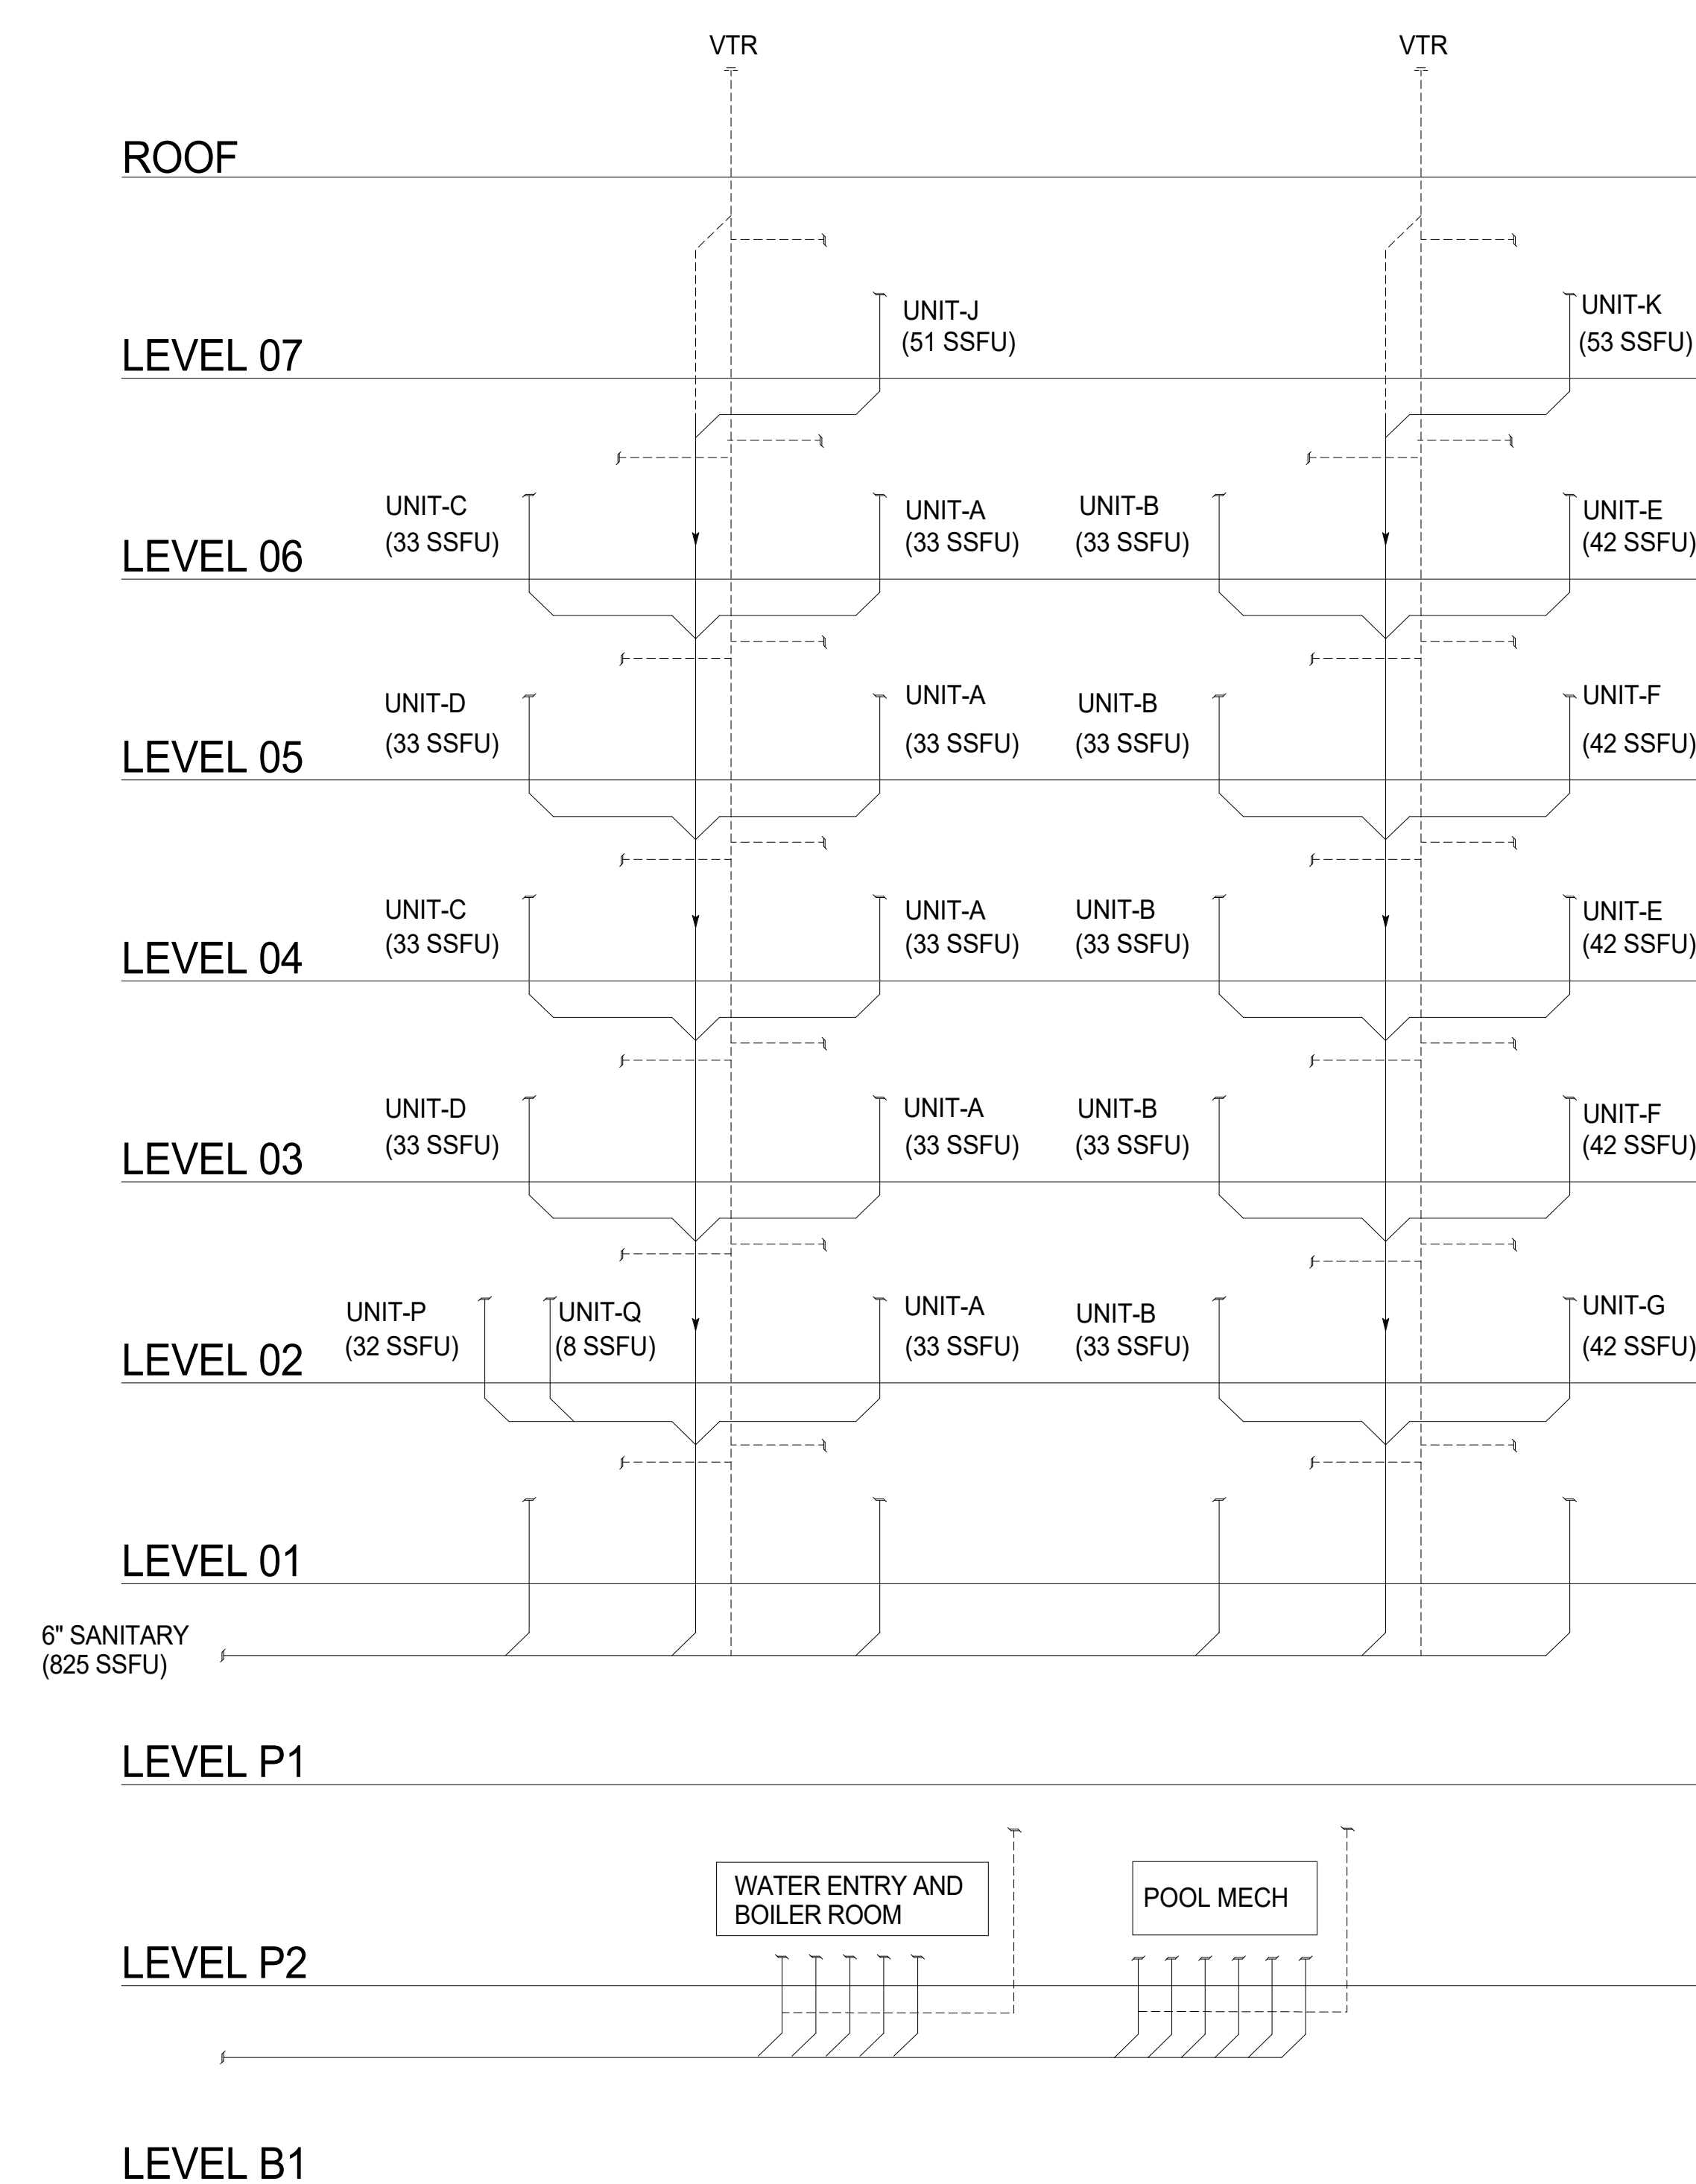


TOWER-B

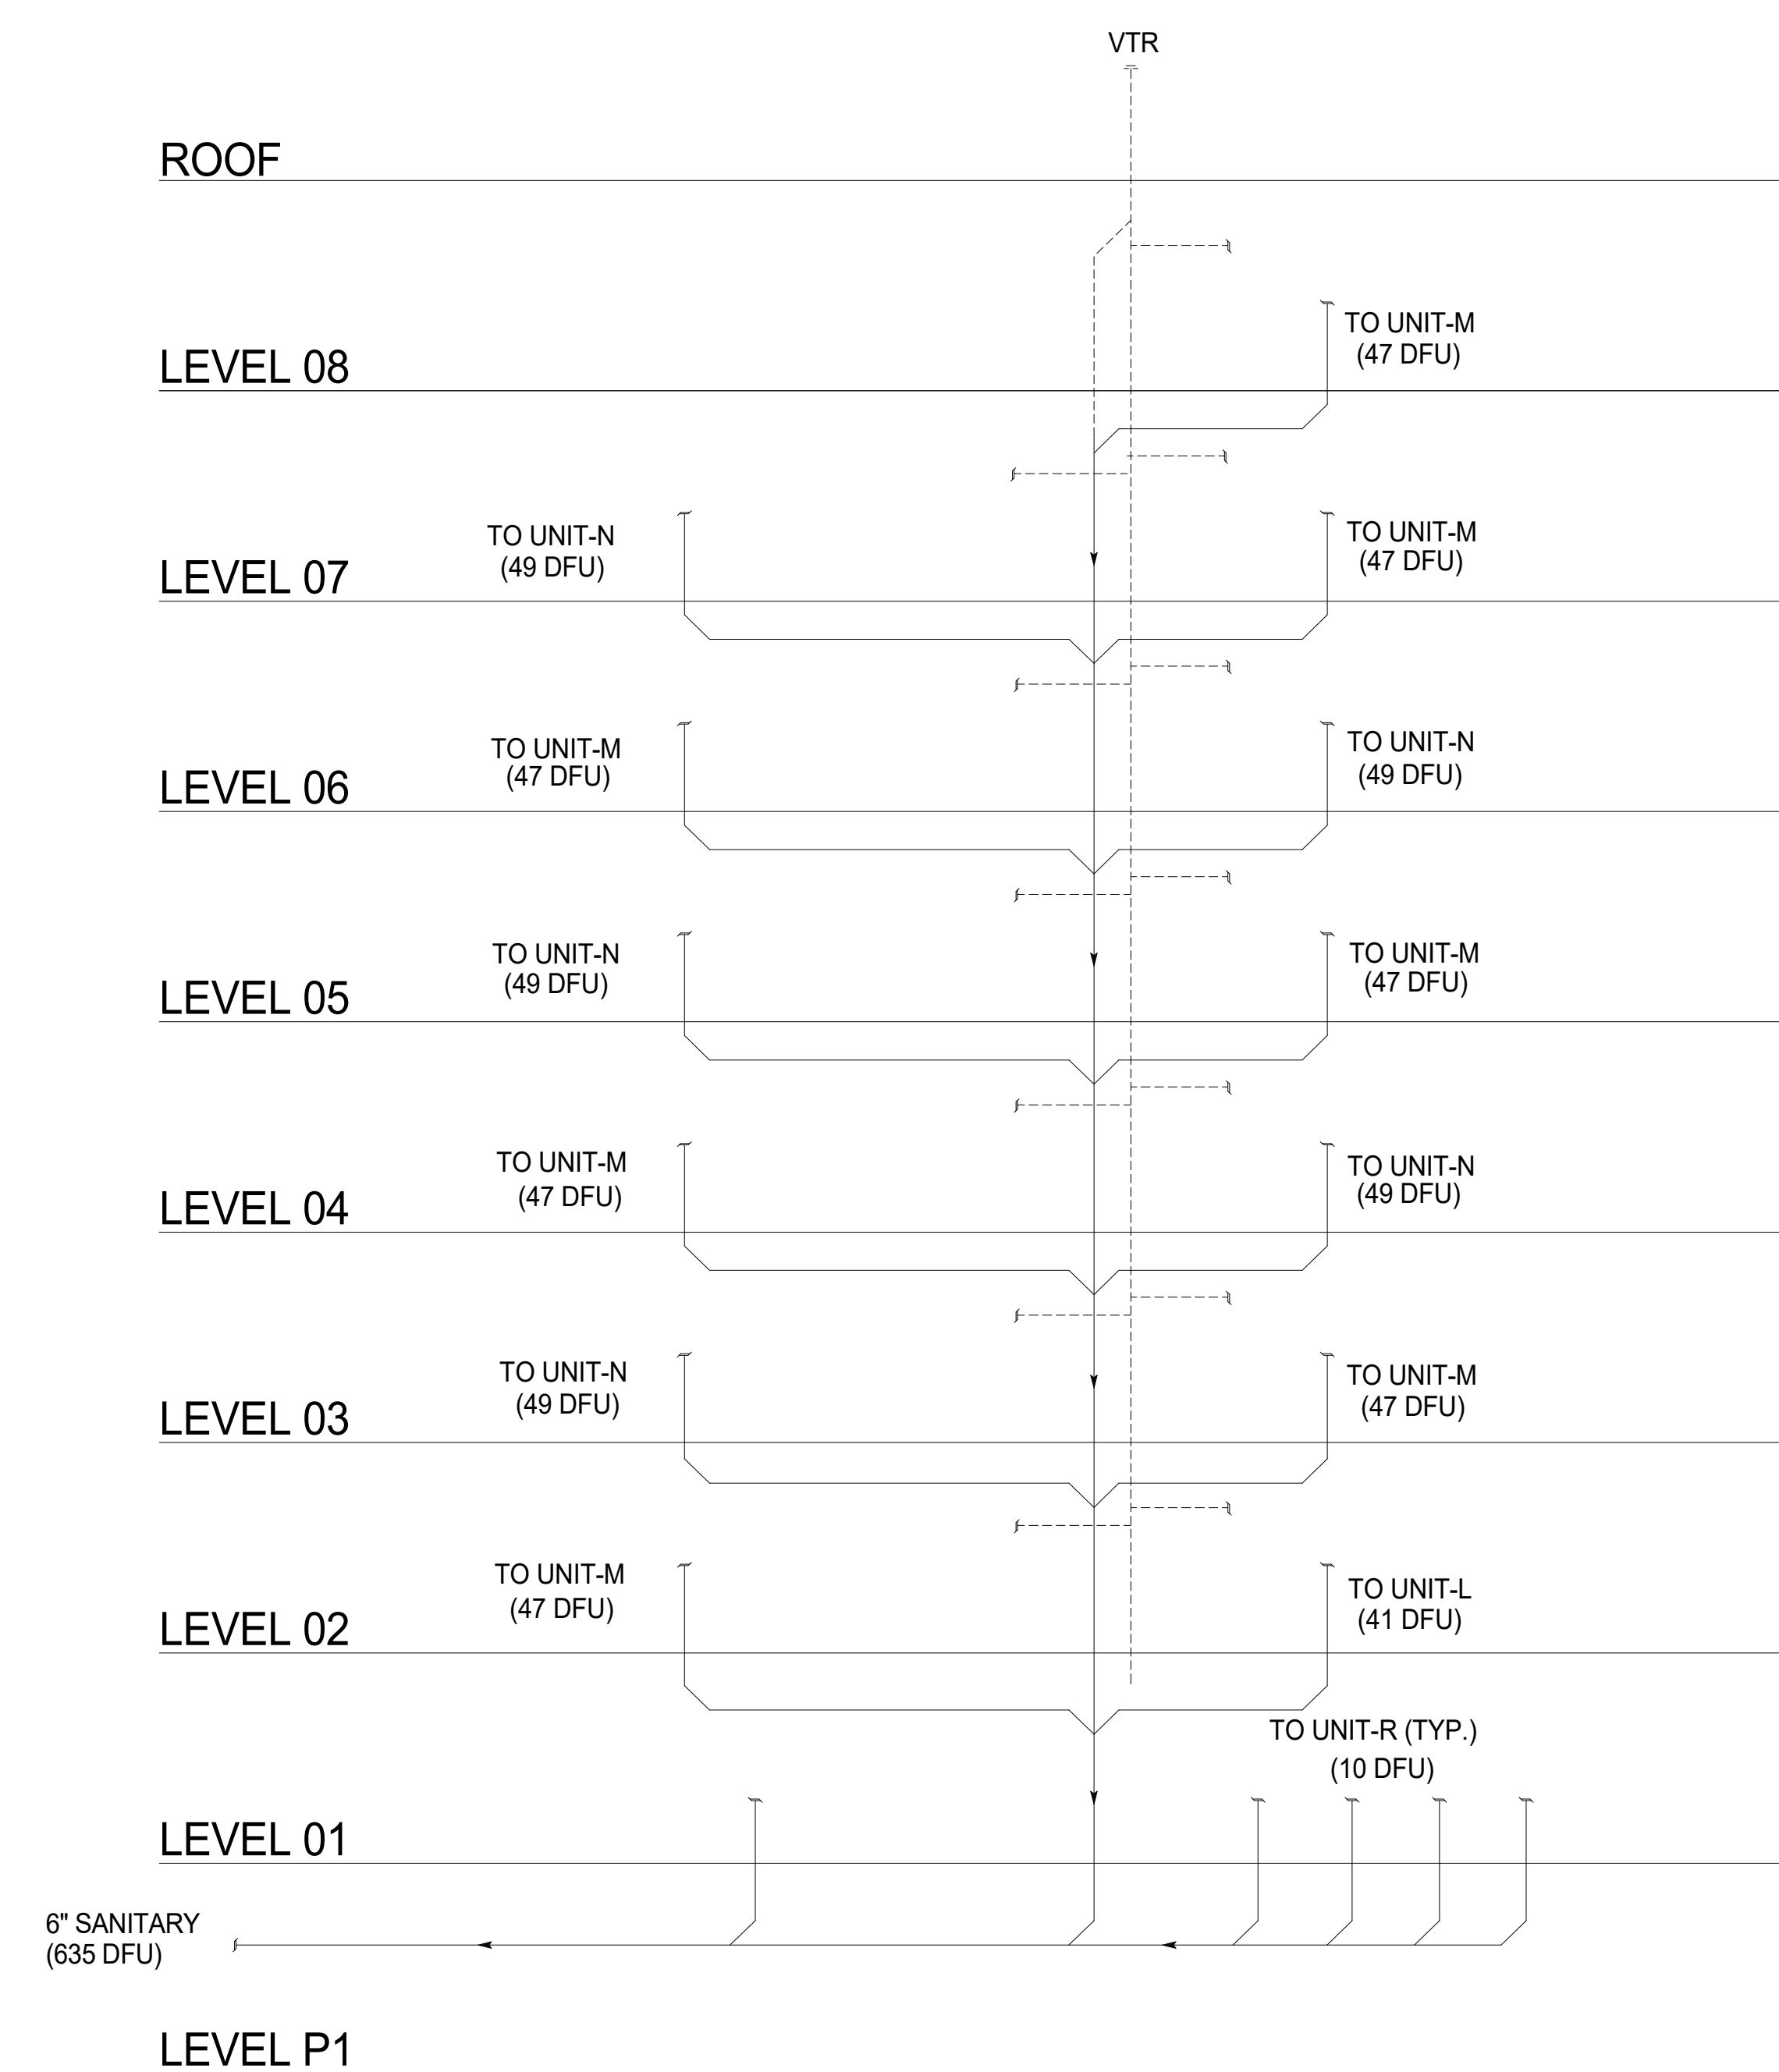

TOWER-C

1 SANITARY RISER
SCALE: 6" = 1'-0"

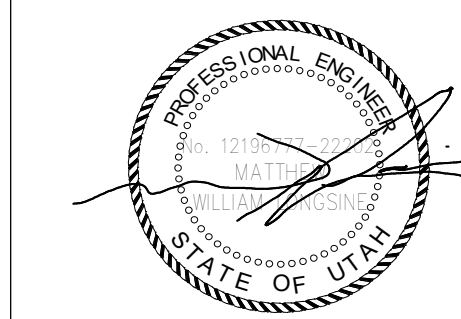

Reserved for permit stamp

159 South Jackson St, Suite 600
Seattle, Washington 98104 USA
+1 206 624 5670 olsonkundig.com

Olson Kundig

Project: **Sommet Blanc - Bldg AB**
DEER VALLEY, UTAH



Aspen Group USA, LLC
PO Box 980022
Park City, Utah 84098

Pool Consultant
Cloward H20
2896 N University Ave, Suite 290
Provo, UT 84604

Landscape Architect
EPG Design
6949 South High Tech Drive, Suite 100
Midvale, Utah 84047

Specifications Writer
Friday Group
88 Mainelli Road
Middlebury, VT

Code Consultant
Holmes
600 1st Avenue, Suite 200
Seattle, WA 98104

Fire Protection Engineer
Jensen Hughes
One Research Drive, Suite 305C
Westborough, MA 01581

Vertical Transportation Consultant
Lerch Bates
19515 North Creek Parkway, Suite 304
Bothell, WA 98011

Structural Engineer
Magnusson Klemencic Associates
1301 5th Ave, Suite 3200
Seattle, WA 98101

Lighting Designer
O-
1319 SE MLK Blvd, Suite 210
Portland, Oregon 97219

Building Envelope Consultants
RDH
2101 N 34th St
Seattle, WA 98103

Accessibility Consultant
Studio Pacifica
2144 Westlake Ave N, Suite F
Seattle, WA 98109

MFP Engineer
WSP USA
1001 Fourth Ave., Suite 3100
Seattle, WA 98154

principal architect _____
project manager _____
drawn by _____
checked by Checker
job no. 2021-0596
date 5/17/2024

no.	date
-----	------

IFC Set 2 of 3
5/17/2024

SANITARY RISER DIAGRAM

P7.02



P7.04





P7.06





(1

SCALE: 1/8" = 1'-0"

SANITARY RISER
DIAGRAM

P7.08