



**BUILDING A - FLOOR 5** 

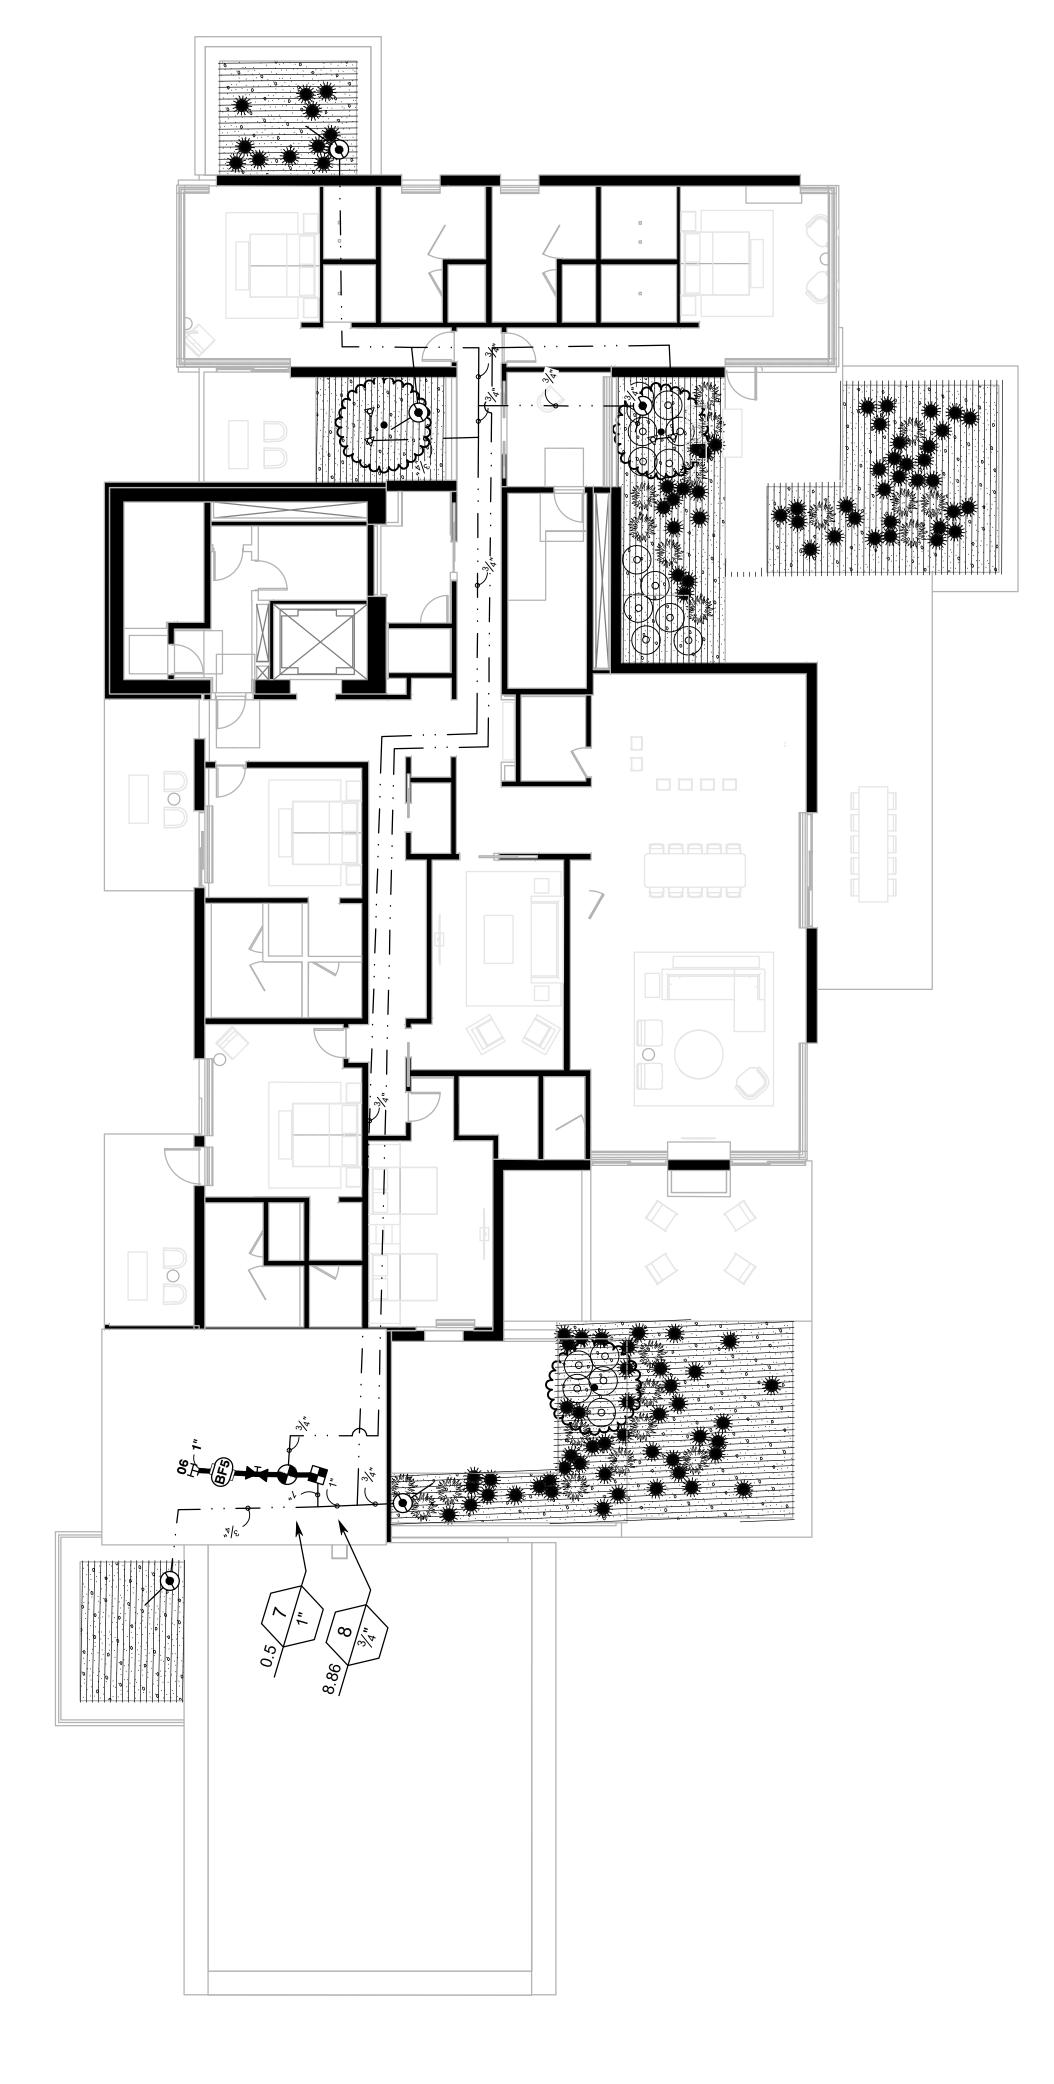

**2** BUILDING A - FLOOR 6

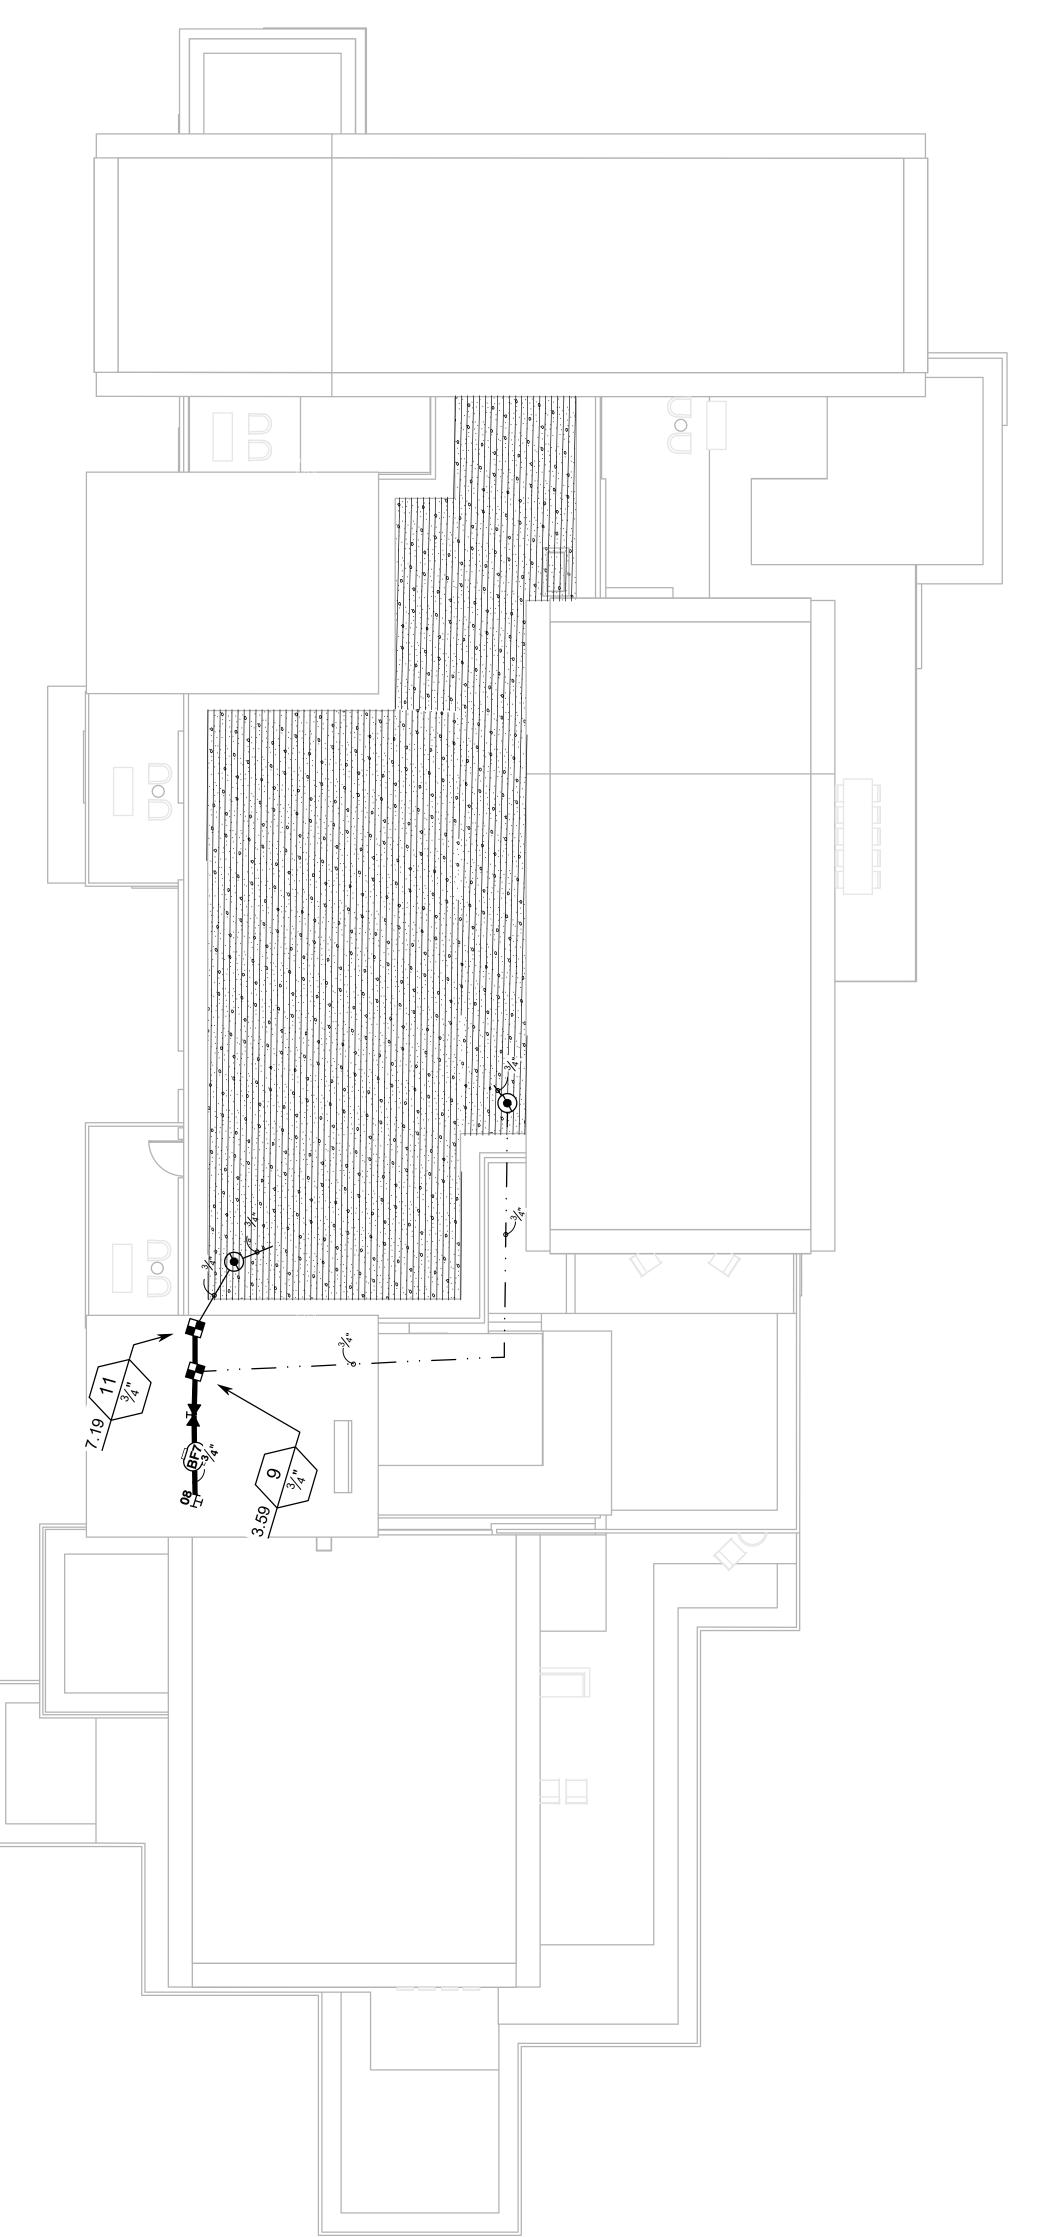

BUILDING A - FLOOR 8

## IRRIGATION SCHEDULE

SYMBOL

MANUFACTURER/MODEL/DESCRIPTION

RAIN BIRD RWS-M-B-C-P W/ RWS-SOCK 1401
MINI ROOT WATERING SYSTEM WITH 4" DIAMETER X 18"
LONG WITH LOCKING GRATE, SEMI-RIGID MESH TUBE AND RAIN BIRD 1401 0.25 GPM GPM BUBBLER AS INDICATED.
WITH CHECK VALVE, PURPLE GRATE, AND SAND SOCK FOR SANDY SOIL.

SYMBOL

MANUFACTURER/MODEL/DESCRIPTION

SYMBOL

MANUFACTURER/MODEL/DESCRIPTION

REMOTE CONTROL DRIP VALVE
RAINBIRD 100DV NPT W/ 30PSI PRESSURE REGULATOR
AND 30 MESH WYE STRAINER

PVC TO POLY TURING

AND 30 MESH WYE STRAINER

PVC TO POLY TUBING

PIPE TRANSITION POINT FROM PVC LATERAL TO DRIP

TUBING

AREA TO RECEIVE DRIPLINE

RAIN BIRD XFCV-06-18

XFCV ON-SURFACE LANDSCAPE DRIPLINE WITH A
HEAVY-DUTY 3.5 PSI CHECK VALVE. 0.6 GPH EMITTERS AT
18" O.C. DRIPLINE LATERALS SPACED AT 18" APART, WITH
EMITTERS OFFSET FOR TRIANGULAR PATTERN. GREAT
FOR ELEVATION CHANGE. SPECIFY XF INSERT FITTINGS.

MBOL

MANUFACTURER/MODEL/DESCRIPTION
RAIN BIRD PESB-PRS-D

1" PLASTIC INDUSTRIAL VALVES. LOW FLOW OPERATING CAPABILITY, GLOBE CONFIGURATION. WITH PRESSURE REGULATING MODULE, AND SCRUBBER TECHNOLOGY FOR RELIABLE PERFORMANCE IN DIRTY WATER IRRIGATION APPLICATIONS.

LEEMCO STAINLESS STEEL GATE VALVE LGT SIZE PER LINE SS, CLASS 125 304 STAINLESS STEEL,

ZURN WILKINS 375XLB 3/4"

REDUCED PRESSURE PRINCIPLE ASSEMBLY. SIZE PER PLAN SEE ARCHITECTURE MECHANICAL PLANS FOR FINAL LOCATION AND DETAILS

ZURN WILKINS 375XLB 3/4"

REDUCED PRESSURE PRINCIPLE ASSEMBLY. SIZE PER

PLAN SEE ARCHITECTURE MECHANICAL PLANS FOR FINAL LOCATION AND DETAILS

ZURN WILKINS 375XLB 3/4"

REDUCED PRESSURE PRINCIPLE ASSEMBLY. SIZE PER PLAN SEE ARCHITECTURE MECHANICAL PLANS FOR FINAL

LOCATION AND DETAILS

ZURN WILKINS 375XLB 3/4"

LOCATION AND DETAILS

ZURN WILKINS 375XLB 3/4"

REDUCED PRESSURE PRINCIPLE ASSEMBLY. SIZE PER
PLAN SEE ARCHITECTURE MECHANICAL PLANS FOR FINAL
LOCATION AND DETAILS

REDUCED PRESSURE PRINCIPLE ASSEMBLY. SIZE PER
PLAN SEE ARCHITECTURE MECHANICAL PLANS FOR FINAL
LOCATION AND DETAILS

ZURN WILKINS 375XLB 3/4"

REDUCED PRESSURE PRINCIPLE ASSEMBLY. SIZE PER

PLAN SEE ARCHITECTURE MECHANICAL PLANS FOR FINAL LOCATION AND DETAILS

ZURN WILKINS 375XLB 3/4"

REDUCED PRESSURE PRINCIPLE ASSEMBLY. SIZE PER PLAN SEE ARCHITECTURE MECHANICAL PLANS FOR FINAL

ZURN WILKINS 375XLB 3/4"

REDUCED PRESSURE PRINCIPLE ASSEMBLY. SIZE PER
PLAN SEE ARCHITECTURE MECHANICAL PLANS FOR FINAL
LOCATION AND DETAILS

REDUCED PRESSURE PRINCIPLE ASSEMBLY. SIZE PER

PLAN SEE ARCHITECTURE MECHANICAL PLANS FOR FINAL LOCATION AND DETAILS

HYDRO POINT WEATHER TRACK LC+ 18 STATION 2WIRE INSTALL CONTROLLER IN UTILITY ROOM SEE ARCHITECTURE PLANS FOR LOCATION

ZURN WILKINS 375XLB 3/4"

POINT OF CONNECTION 3/4"
BUILDING A - FLOOR 5 - SEE PLUMBING PLANS FOR POINT
OF CONNECTION AND BACKFLOW PREVENTER

YX
POINT OF CONNECTION 3/4"

LOBBY BUILDING - SEE PLUMBING PLANS FOR POC AND BACKFLOW PREVENTER

XX
POINT OF CONNECTION 3/4"
BUILDING B - FLOOR 3 - SEE PLUMBING PLANS

POINT OF CONNECTION 3/4"
BUILDING C - FLOOR 8 - SEE PLUMBING PLANS

YX
POINT OF CONNECTION 3/4"
BUILDING A - FLOOR 6 - SEE PLUBMING PLANS

YX
POINT OF CONNECTION 3/4"
BUILDING B - FLOOR 8 - SEE PLUMBING PLANS

BUILDING B - FLOOR 8 - SEE PLUMBING PLANS

XX
POINT OF CONNECTION 3/4"
BUILDING A - FLOOR 8 - SEE PLUMBING PLANS

XX
POINT OF CONNECTION 3/4"
BUILDING B - FLOOR 9 - SEE PLUBMING PLANS

POINT OF CONNECTION 3/4"
BUILDING C - FLOOR 9 - SEE PLUMBING PLANS

IRRIGATION LATERAL LINE: PVC SCHEDULE 40

--- --- IRRIGATION MAINLINE: PVC SCHEDULE 40

Valve Callout

Valve Number

Valve Flow

Valve Size



Reserved for permit stamp

SOMMET BLANC RESIDENCE 1
ADDRESS

White Summit Development, LLC

Park City, Utah 84098

PO Box 980022

Acoustic Consultant
BRC Acoustics
1932 1st Ave, Suite 620
Seattle, WA 98101

Pool Consultant
Cloward H20

2696 N University Ave, Suite 290
Provo, UT 84604

Landscape Architect
EPG Design
6949 South High Tech Drive, Suite 100

6949 South High Tech Drive, Suite 100
Midvale, Utah 84047

Specifications Writer
Friday Group
88 Mainelli Road

Code Consultant
Holmes
600 1st Avenue, Suite 200A
Seattle, WA 98104

Fire Protection Engineer
Jensen Hughes

Middlebury, VT

One Research Drive, Suite 305C
Westborough, MA 01581

Vertical Transportation Consulatant
Lerch Bates

Lerch Bates
19515 North Creek Parkway, Suite 304
Bothell, WA 98011

Structural Engineer

Magnusson Klemencic Associates
1301 5th Ave, Suite 3200
Seattle, WA 98101

Lighting Designer
O1319 SE MLK Blvd, Suite 210
Portland, Oregon 97219

Building Envelope Consultant RDH
2101 N 34th St
Seattle, WA 98103

Studio Pacifica 2144 Westlake Ave N, Suite F Seattle, WA 98109

WSP USA
1001 Fourth Ave., Suite 3100
Seattle, WA 98154

principal architect David Harris

project manager Grant Hardy

drawn by Grant Hardy

checked by Michael Park

job no. 20052

date June 10, 2024

visions:

revisions:

IFC 2 5/17/2024

WUI Updates 7/29/2024

no. date by


IFC SET 2 OF 3

June 10, 2024

BUILDING A

ROOF IRRIGATION PLAN

L705

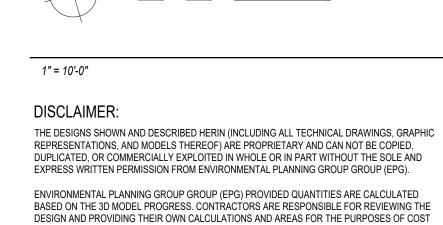

THE CLIENT, AND/OR THE CLIENT'S CONTRACTOR, IS RESPONSIBLE FOR ATTAINING OR PROVIDING THE NECESSARY CONSTRUCTION PERMIT FOR CITY CODE COMPLIANCE.

ESTIMATING / BIDDING.