




BUILDING C - FLOOR 9

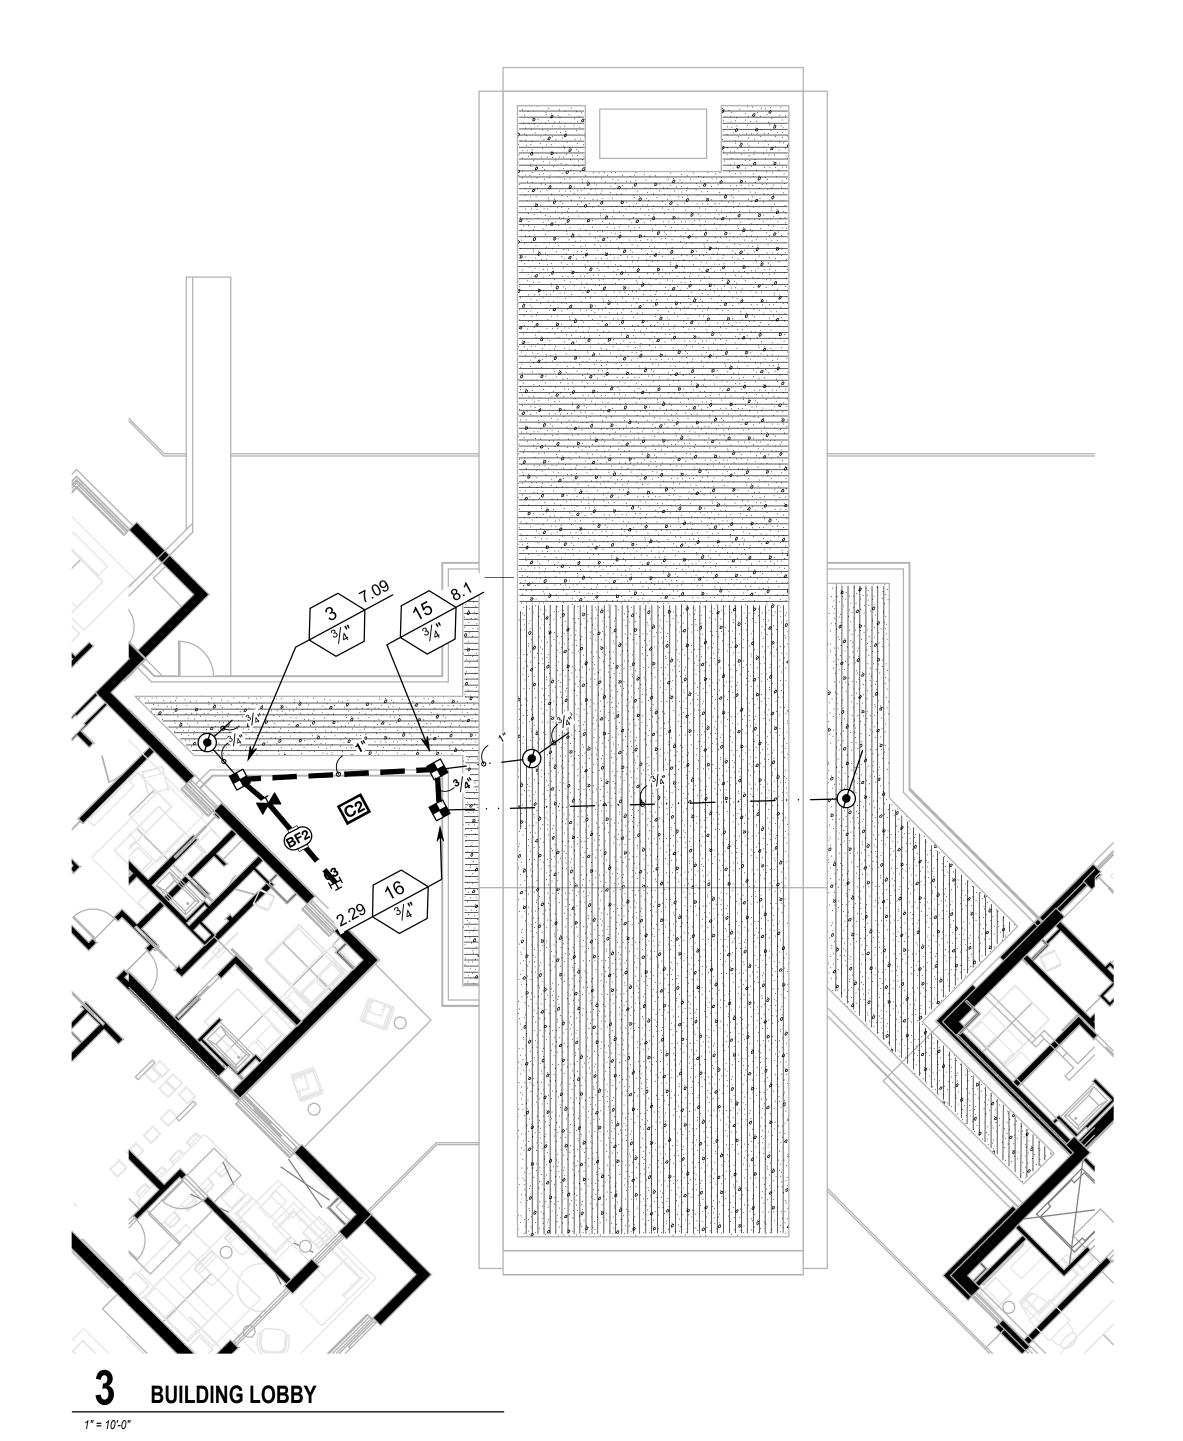

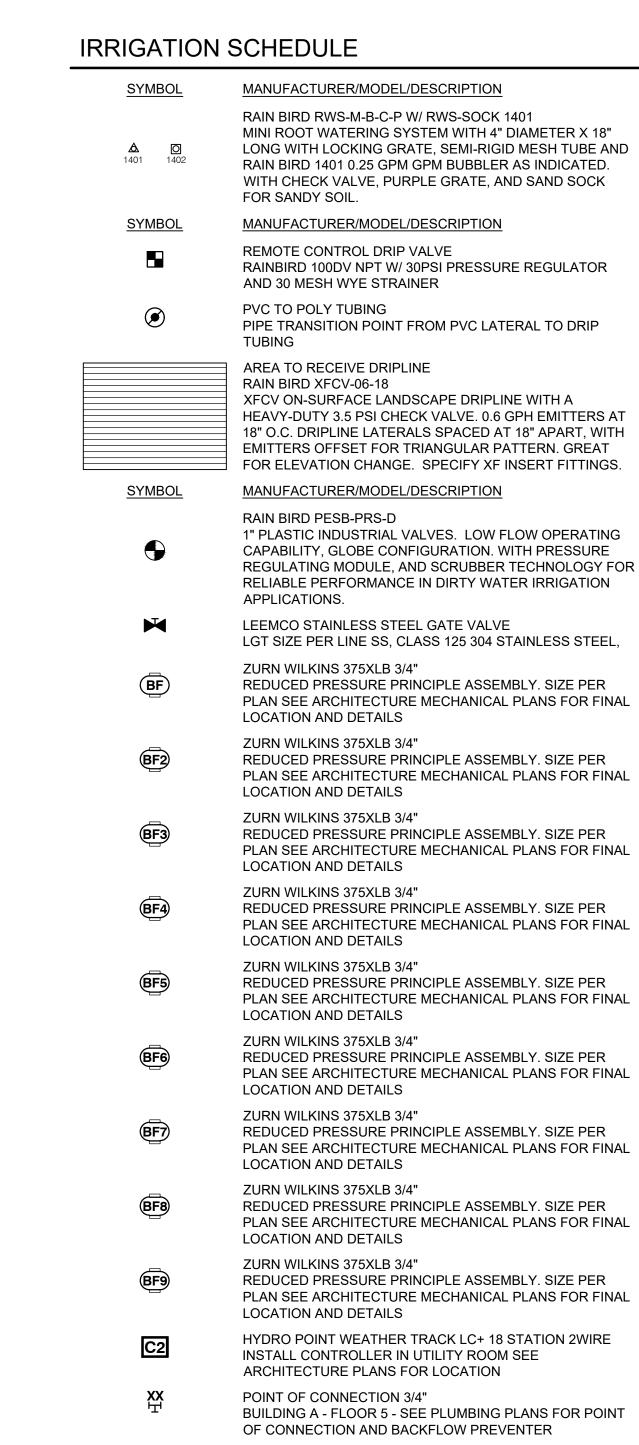

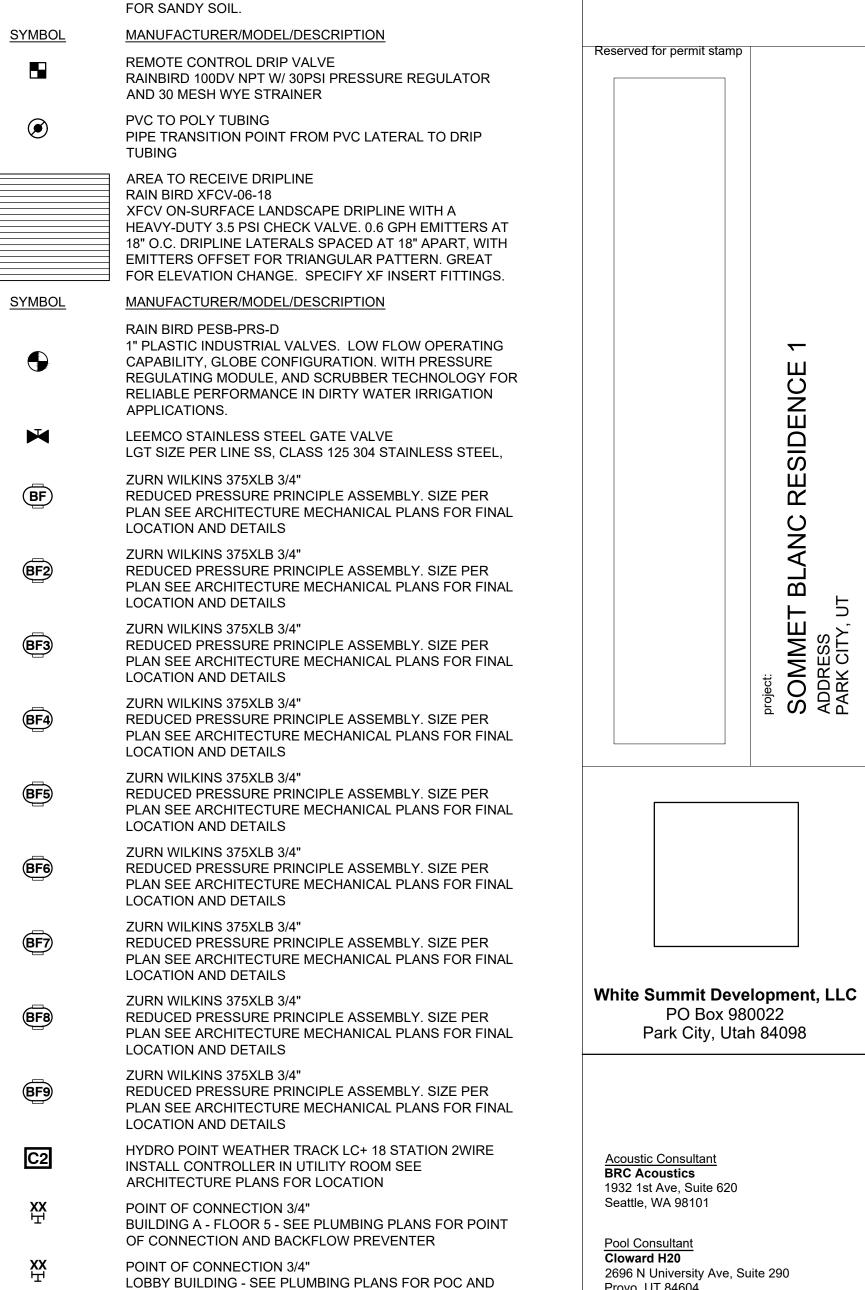

BACKFLOW PREVENTER

POINT OF CONNECTION 3/4"

POINT OF CONNECTION 3/4"

POINT OF CONNECTION 3/4"

--- --- IRRIGATION MAINLINE: PVC SCHEDULE 40

Valve Callout Valve Number

Valve Flow

BUILDING B - FLOOR 3 - SEE PLUMBING PLANS

BUILDING C - FLOOR 8 - SEE PLUMBING PLANS

BUILDING A - FLOOR 6 - SEE PLUBMING PLANS

POINT OF CONNECTION 3/4" Middlebury, VT BUILDING B - FLOOR 8 - SEE PLUMBING PLANS POINT OF CONNECTION 3/4" Code Consultant BUILDING A - FLOOR 8 - SEE PLUMBING PLANS 600 1st Avenue, Suite 200A POINT OF CONNECTION 3/4" Seattle, WA 98104 BUILDING B - FLOOR 9 - SEE PLUBMING PLANS POINT OF CONNECTION 3/4" Fire Protection Engineer BUILDING C - FLOOR 9 - SEE PLUMBING PLANS One Research Drive, Suite 305C

Westborough, MA 01581 Vertical Transportation Consulatant Lerch Bates 19515 North Creek Parkway, Suite 304 Bothell, WA 98011

Provo, UT 84604

Landscape Architect
EPG Design

Midvale, Utah 84047

Specifications Writer Friday Group

88 Mainelli Road

6949 South High Tech Drive, Suite 100

PO Box 980022

Structural Engineer
Magnusson Klemencic Associates 1301 5th Ave, Suite 3200 Seattle, WA 98101 <u>Lighting Designer</u>

Building Envelope Consultant 2101 N 34th St Seattle, WA 98103

revisions:

no. date

1FC 2 5/17/2024


★ WUI Updates 7/29/2024

principal architect David Harris project manager<u>Grant Hardy</u>

drawn by Grant Hardy

checked by Michael Park job no. 20052

date June 10, 2024

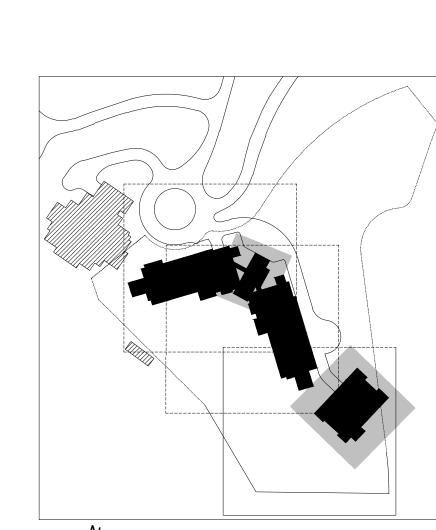

1" = 10'-0" DISCLAIMER:

June 10, 2024 LOBBY & BUILDING C ROOF IRRIGATION PLAN

L707

PERMIT SET IFC SET 2 OF 3

THE DESIGNS SHOWN AND DESCRIBED HERIN (INCLUDING ALL TECHNICAL DRAWINGS, GRAPHIC REPRESENTATIONS, AND MODELS THEREOF) ARE PROPRIETARY AND CAN NOT BE COPIED, DUPLICATED, OR COMMERCIALLY EXPLOITED IN WHOLE OR IN PART WITHOUT THE SOLE AND EXPRESS WRITTEN PERMISSION FROM ENVIRONMENTAL PLANNING GROUP GROUP (EPG). ENVIRONMENTAL PLANNING GROUP GROUP (EPG) PROVIDED QUANTITIES ARE CALCULATED BASED ON THE 3D MODEL PROGRESS. CONTRACTORS ARE RESPONSIBLE FOR REVIEWING THE DESIGN AND PROVIDING THEIR OWN CALCULATIONS AND AREAS FOR THE PURPOSES OF COST ESTIMATING / BIDDING. THE CLIENT, AND/OR THE CLIENT'S CONTRACTOR, IS RESPONSIBLE FOR ATTAINING OR PROVIDING THE NECESSARY CONSTRUCTION PERMIT FOR CITY CODE COMPLIANCE.

Reserved for permit stamp

1319 SE MLK Blvd, Suite 210 Portland, Oregon 97219 Accessibility Consultant Studio Pacifica 2144 Westlake Ave N, Suite F Seattle, WA 98109 1001 Fourth Ave., Suite 3100 Seattle, WA 98154