


## NOTES:

- . ROOM FOR FUTURE BOILER FOR RADIANT HYDRONIC SNOWMELT
- SYSTEM TO BE DESIGN BUILD BY OTHERS
- 2. BOILER ROOM TO BE HEATED FOR FREEZE PROTECTION &
- 3. ACCESS DOORS TO BOILER ROOM AT MEP ROOF TO BE
- SPRINKLER SYSTEM. VENTILATED, TYP.

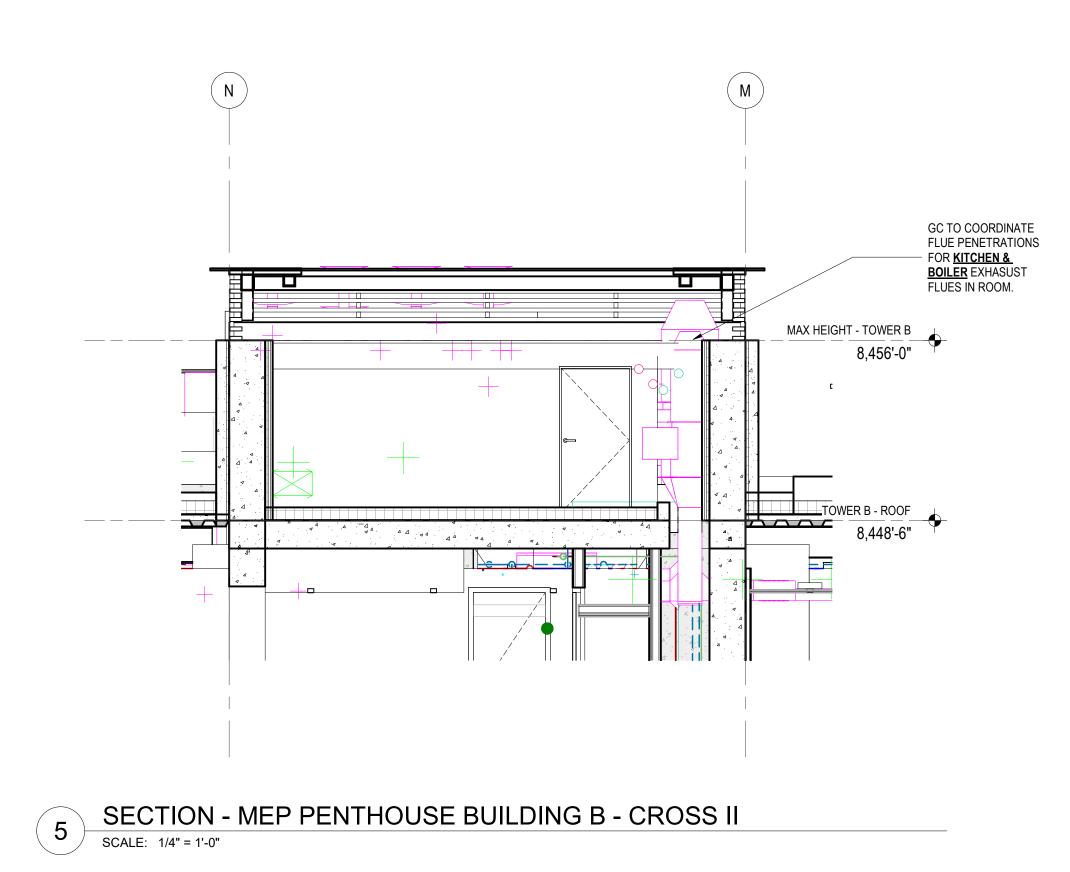


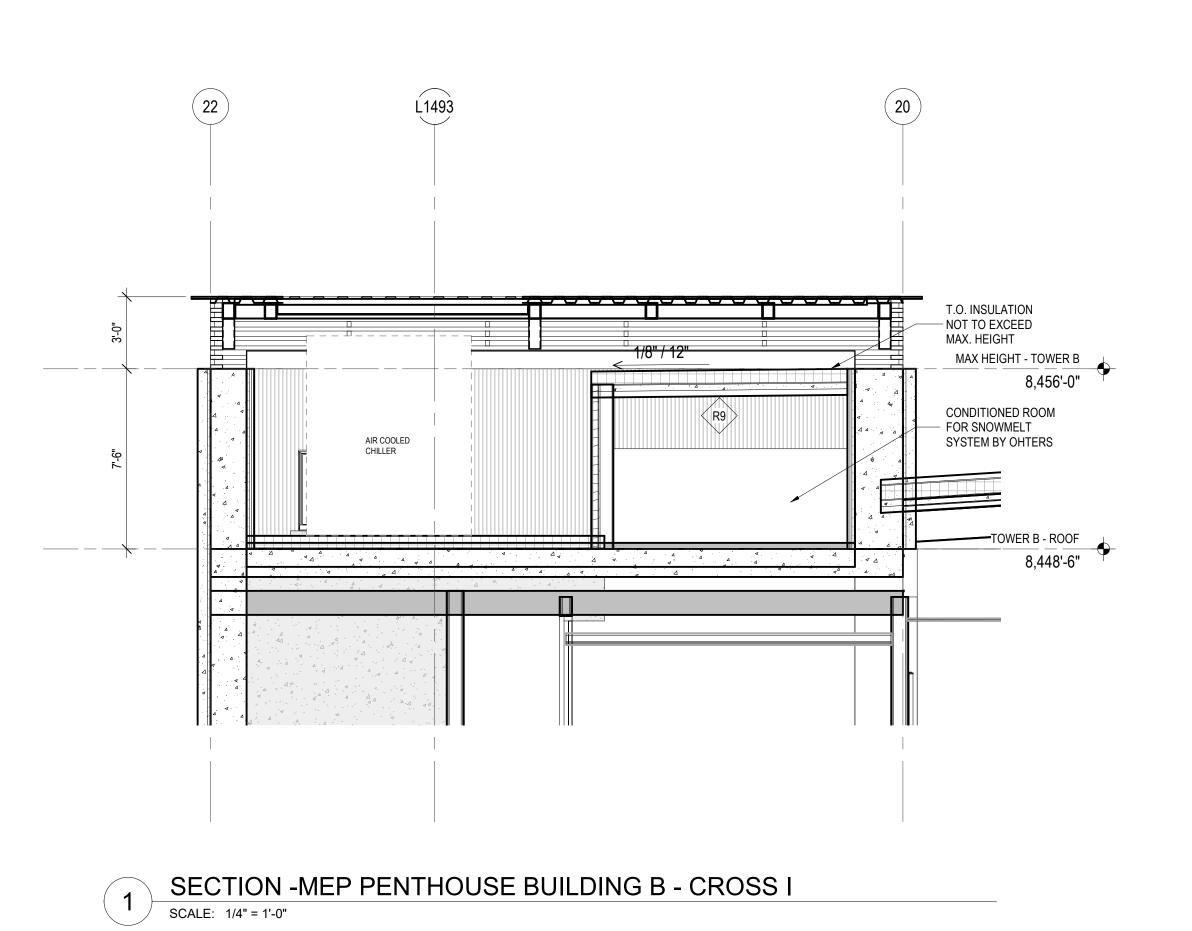

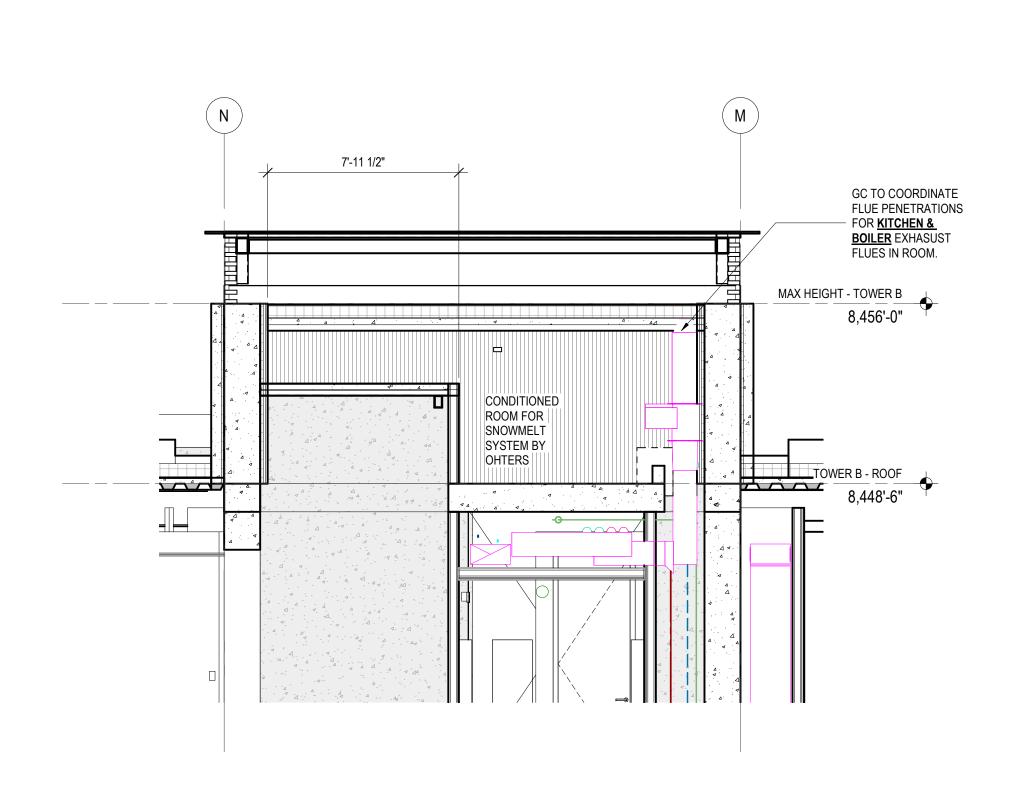


SECTION - MEP PENTHOUSE BUILDING B - LONGITUDINAL

SCALE: 1/4" = 1'-0"

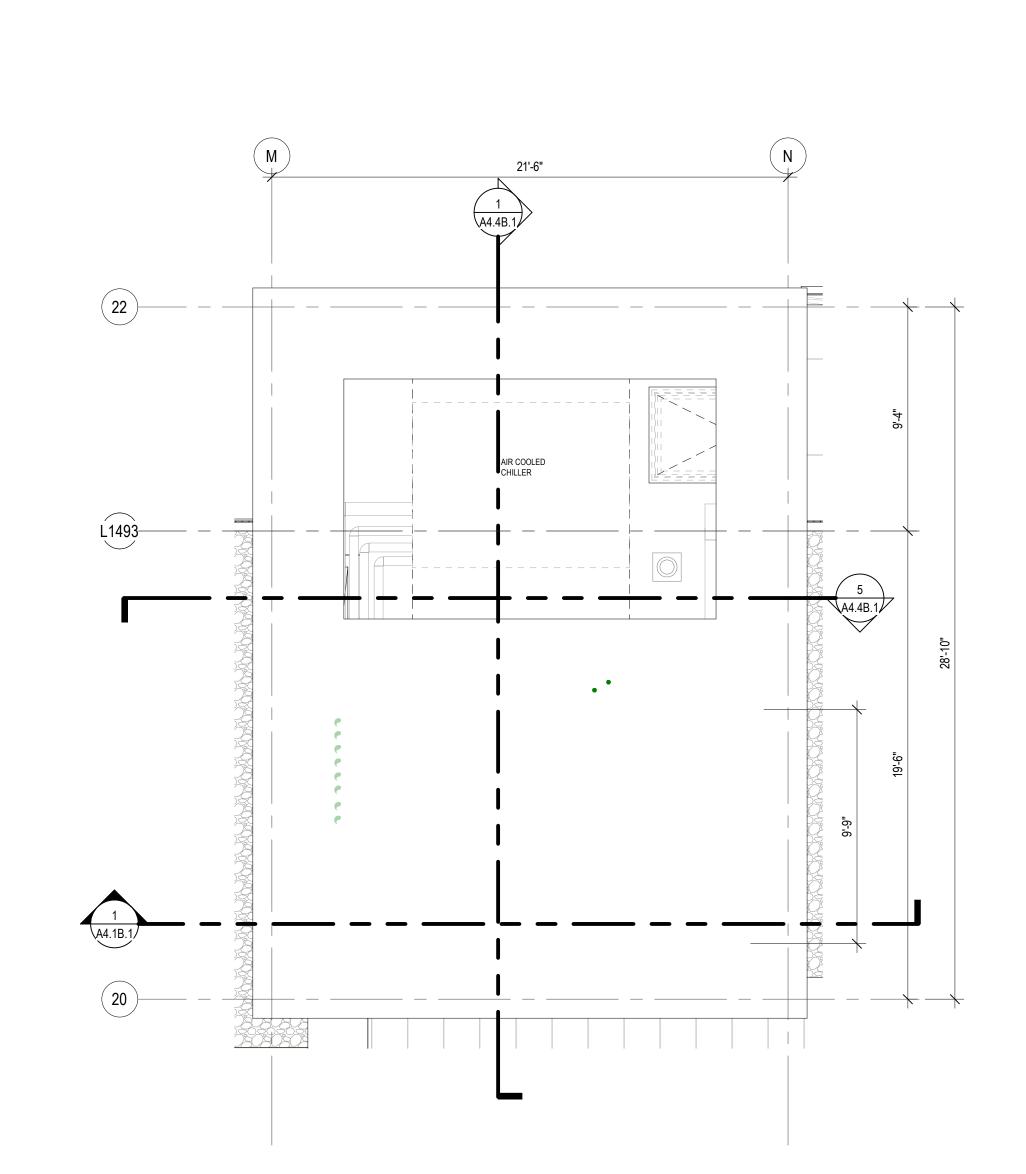

7 TOWER B - ENLARGED ROOF PLAN AT MEP PENTHOUSE


SCALE: 1/4" = 1'-0"

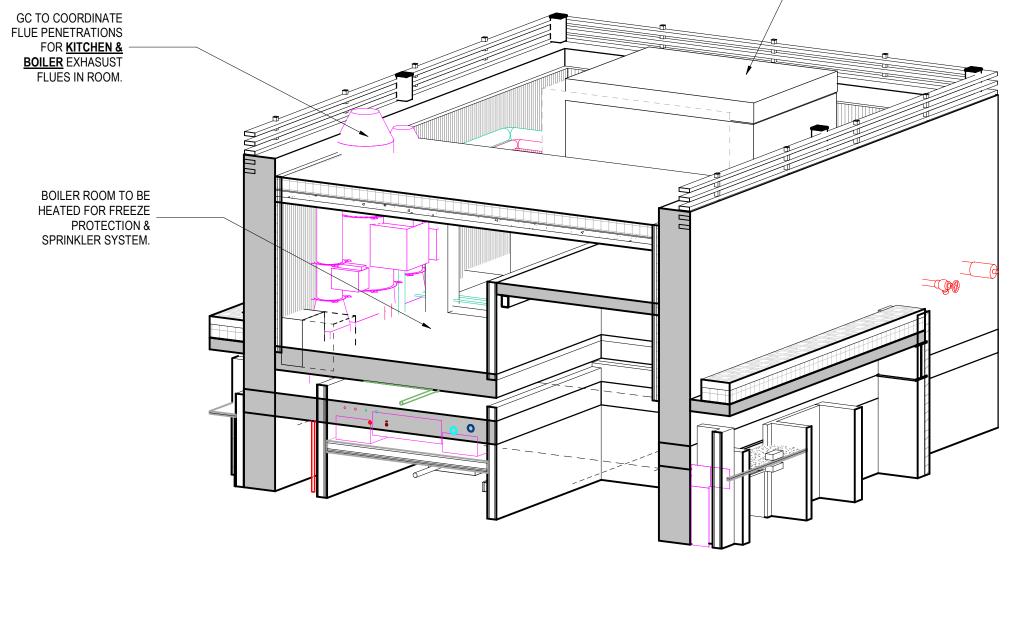

- AIR COOLED CHILLER


TOWER B - MEP PENTHOUSE AXO

SCALE:

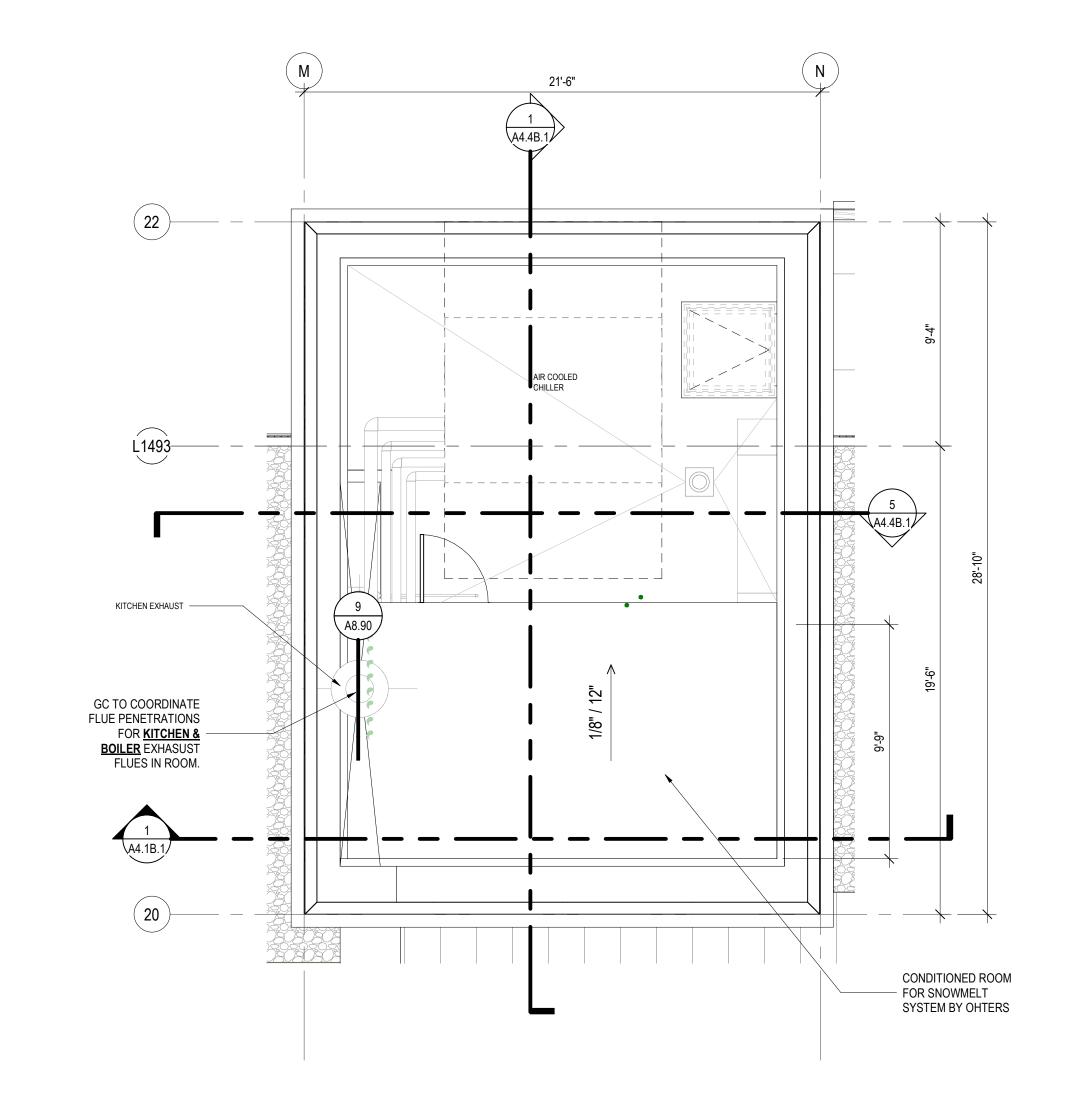

6 TOWER B - ENLARGED PLAN AT MEP PENTHOUSE LEVEL

SCALE: 1/4" = 1'-0"

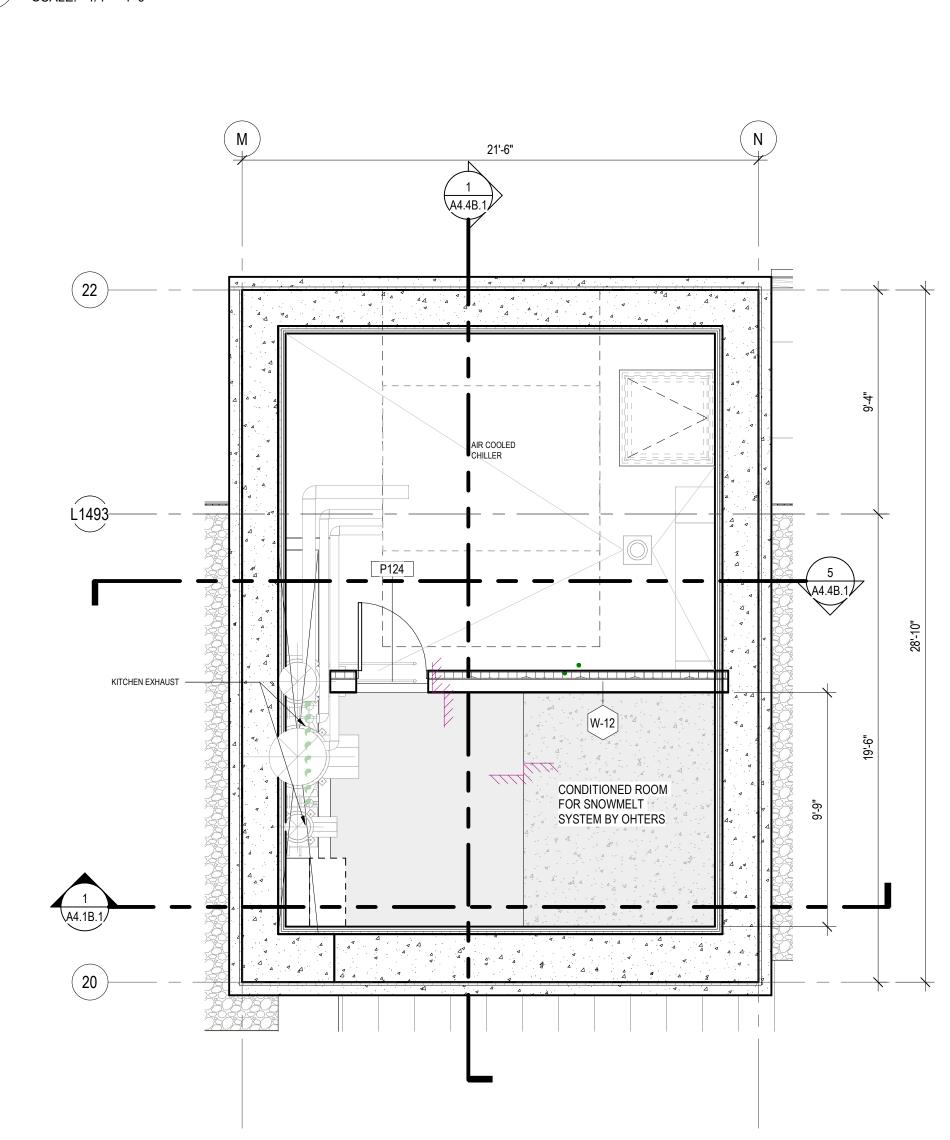

3 TOWER B - ENLARGED MEP ROOM PLAN AT MEP PENTHOUSE LEVEL

SCALE: 1/4" = 1'-0"



**ASPEN** GROUP Aspen Group USA, LLC PO Box 980022 Park City, Utah 84098

Pool Consultant
Cloward H20 2696 N University Ave, Suite 290 Provo, UT 84604 <u>Landscape Architect</u> **EPG Design**6949 South High Tech Drive, Suite 100
Midvale, Utah 84047 Specifications Writer
Friday Group
88 Mainelli Road Middlebury, VT Code Consultant Holmes 600 1st Avenue, Suite 200A Seattle, WA 98104 <u>Fire Protection Engineer</u> **Jensen Hughes** One Research Drive, Suite 305C Westborough, MA 01581

Vertical Transportation Consulatant Lerch Bates 19515 North Creek Parkway, Suite 304 Bothell, WA 98011

Structural Engineer

Magnusson Klemencic Associates
1301 5th Ave, Suite 3200 Seattle, WA 98101 <u>Lighting Designer</u> 1319 SE MLK Blvd, Suite 210 Portland, Oregon 97219 Building Envelope Consultant RDH

2101 N 34th St Seattle, WA 98103 Accessibility Consultant
Studio Pacifica 2144 Westlake Ave N, Suite F

Seattle, WA 98109 MEP Engineer
WSP USA
1001 Fourth Ave., Suite 3100
Seattle, WA 98154

principal architect <u>TK, KM</u> project manager TM, JB, SL, MD

drawn by SK, SS, JR, CP, EA,

JF, BD checked by Checker

	job no.	20052
	date	01/15/2025
revisions:		
-		
K 02/05/25	ASI 00	ne 1

IFC SET 3 OF 3 01/15/2025

no. date

TOWER B - ENLARGED PLAN & SECTION AT ROOF A4.4B.1